

CITY OF HARRISBURG


SMITH, MACY, & 2ND STREET

REHABILITATION

SMITH STREET BETWEEN FIRST STREET & 3RD/HWY. 99E

MACY STREET BETWEEN 2ND & 3RD/HWY. 99E

2ND STREET BETWEEN SMITH & MACY

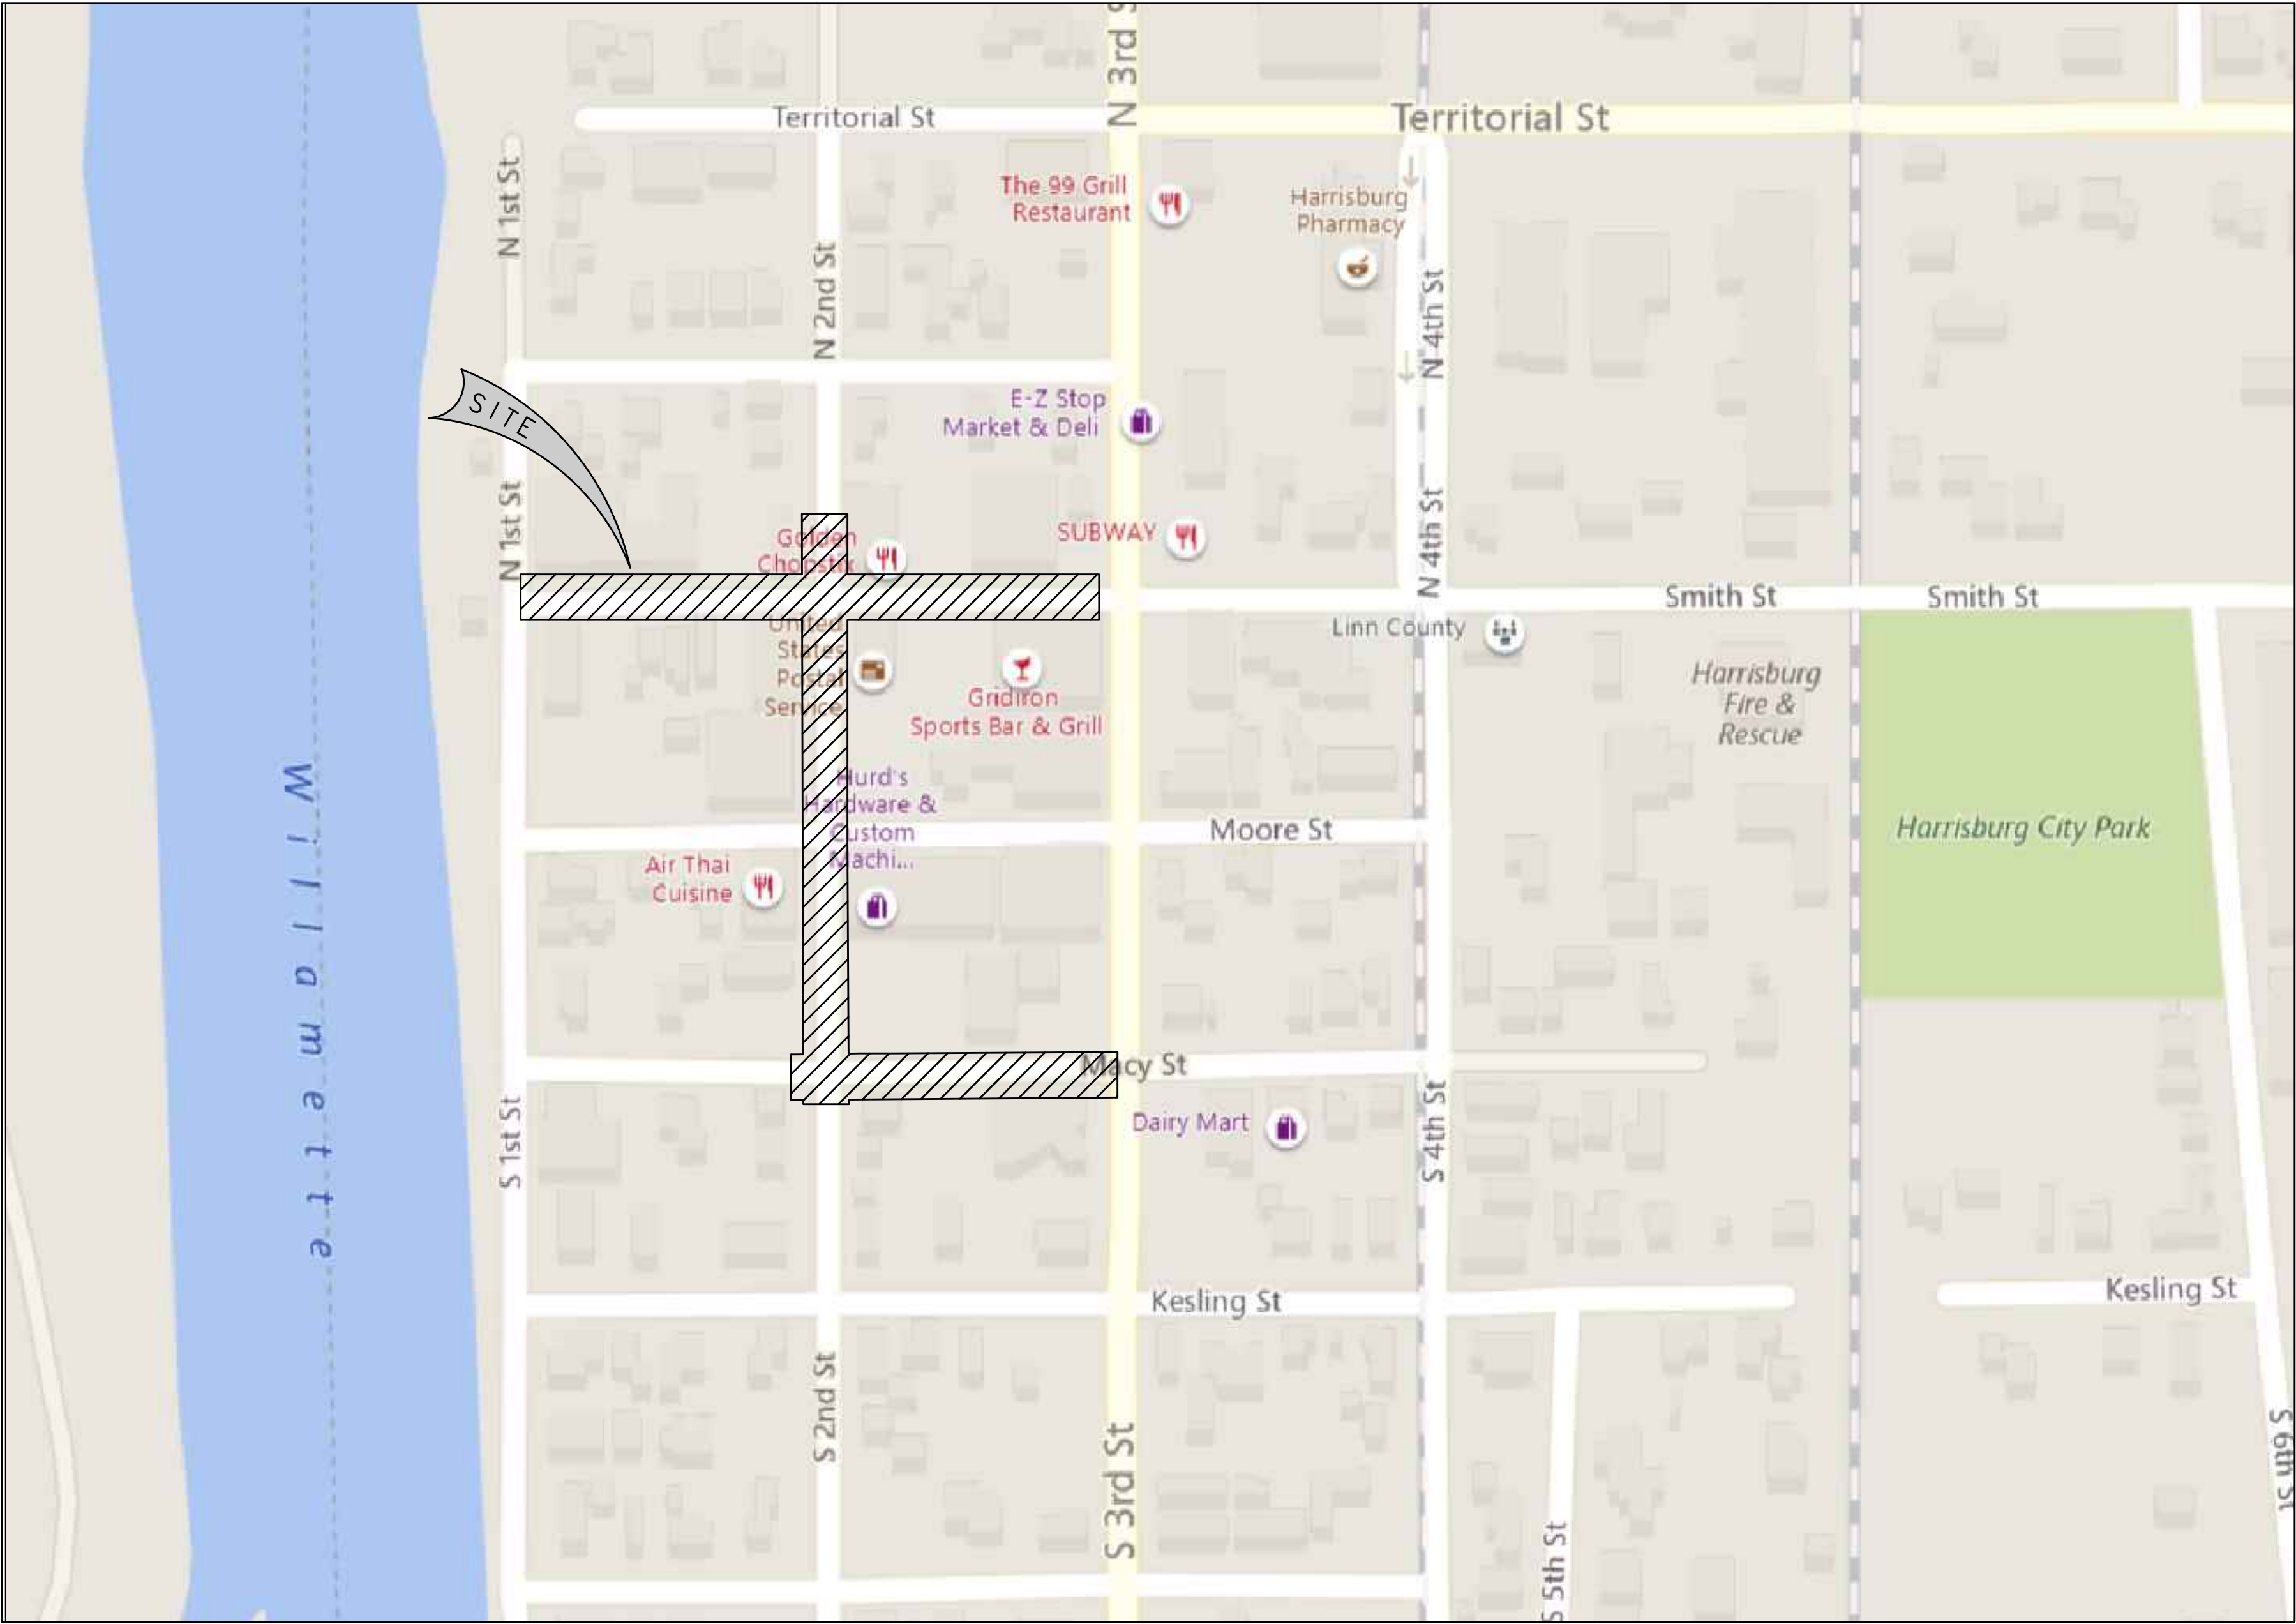

SHEET #	SHEET TITLE
C1	COVER SHEET
C2	TYPICAL SECTIONS AND GENERAL NOTES
C3	SMITH STREET – EXISTING CONDITIONS AND DEMOLITION PLAN
C4	2ND STREET – EXISTING CONDITIONS AND DEMOLITION PLAN
C5	MACY STREET – EXISTING CONDITIONS AND DEMOLITION PLAN
C6	SMITH STREET – STREET AND STORM PLAN AND PROFILE
C7	SMITH STREET – STREET AND STORM PLAN AND PROFILE
C8	2ND STREET – STREET AND STORM PLAN AND PROFILE
C9	2ND STREET – STREET AND STORM PLAN AND PROFILE
C10	MACY STREET – STREET AND STORM PLAN AND PROFILE
C11	CURB RETURN ADA RAMP DETAILS
C12	CURB RETURN ADA RAMP DETAILS
C13	CURB RETURN ADA RAMP DETAILS
C14	CURB RETURN ADA RAMP DETAILS
C15	CURB RETURN ADA RAMP DETAILS
C16	CURB RETURN ADA RAMP DETAILS
C17	MACY KEY BANK EX. RAMP & HANDRAIL DETAILS
C18	MACY KEY BANK ENTRANCE STAIRS & HANDRAIL DETAILS
C19	SMITH STREET – WATERLINE PLAN AND PROFILE
C20	SMITH STREET – WATERLINE PLAN AND PROFILE
C21	MACY STREET – WATERLINE PLAN AND PROFILE
C22	SMITH STREET – ELECTRICAL, STREET LIGHTING, SIGNING, & PAVEMENT STRIPING PLAN
C23	2ND STREET – ELECTRICAL, STREET LIGHTING, SIGNING, & PAVEMENT STRIPING PLAN
C24	MACY STREET – ELECTRICAL, STREET LIGHTING, SIGNING, & PAVEMENT STRIPING PLAN
C25	RRFB DETAIL SHEET
C26	DETAILS
C27	DETAILS
C28	DETAILS
C29	DETAILS

UTILITY PROVIDERS		
UTILITY	PROVIDER	PHONE NUMBER
WATER	CITY OF HARRISBURG	541-995-6655
SEWER	CITY OF HARRISBURG	541-995-6655
STORM	CITY OF HARRISBURG	541-995-6655
ELECTRIC	PACIFIC POWER	503-255-4634
GAS	NW NATURAL	503-220-2415
TELEPHONE	CENTURY LINK	800-283-4237
TELEVISION	COMCAST	541-230-0079

BranchENGINEERING, INC.

Since 1977

civil • transportation
structural • geotechnical
SURVEYING

310 5th Street
Springfield, OR 97477
p: 541.746.0637

www.BranchEngineering.com
Springfield OR | Albany OR

REGISTERED PROFESSIONAL
ENGINEER
#53,800
DIGITALLY SIGNED
BY
GREGORY A. HOWE
REGON 43908
EXPIRES: DECEMBER 31, 2020

project title:

CITY OF HARRISBURG

Smith, Macy, & 2nd Street Rehabilitation

Smith - 1st To 3rd, Macy - 2nd To 3rd, 2nd - Smith To Macy
HARRISBURG, OREGON

revisions:


date: JANUARY 28, 2020
drawn by: GAM
designer: GAM
project no: 17-009F

Cover Sheet

sheet:


C1

Z:\2017\17-009F Harrisburg Smith Street Improvements.dwg 2/28/2020 9:01 AM JLL/E

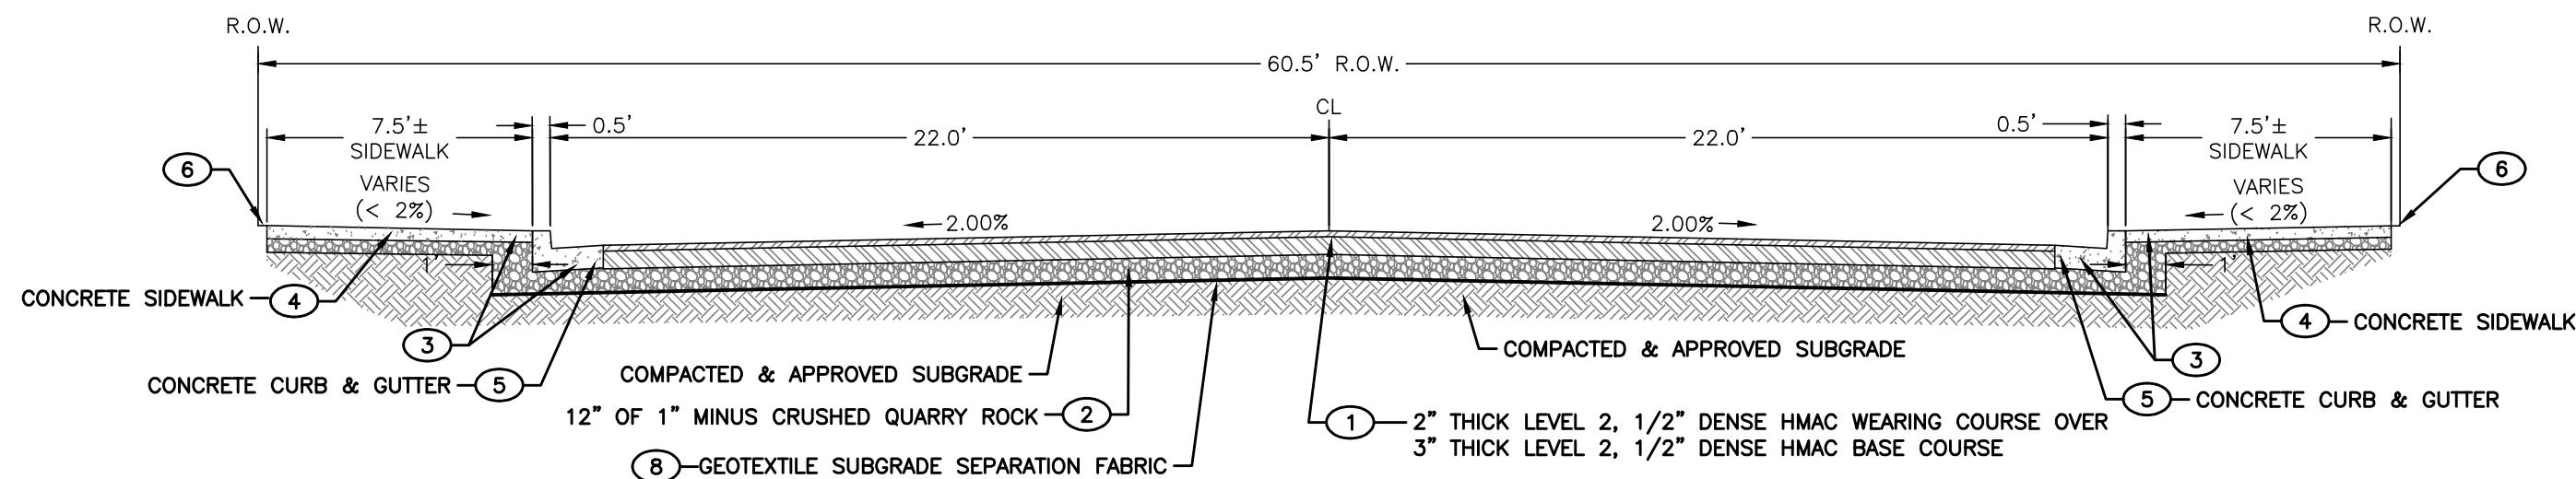


2ND STREET — TYPICAL SECTION

STA 5+85 TO STA 5+93.64
(NOT TO SCALE)

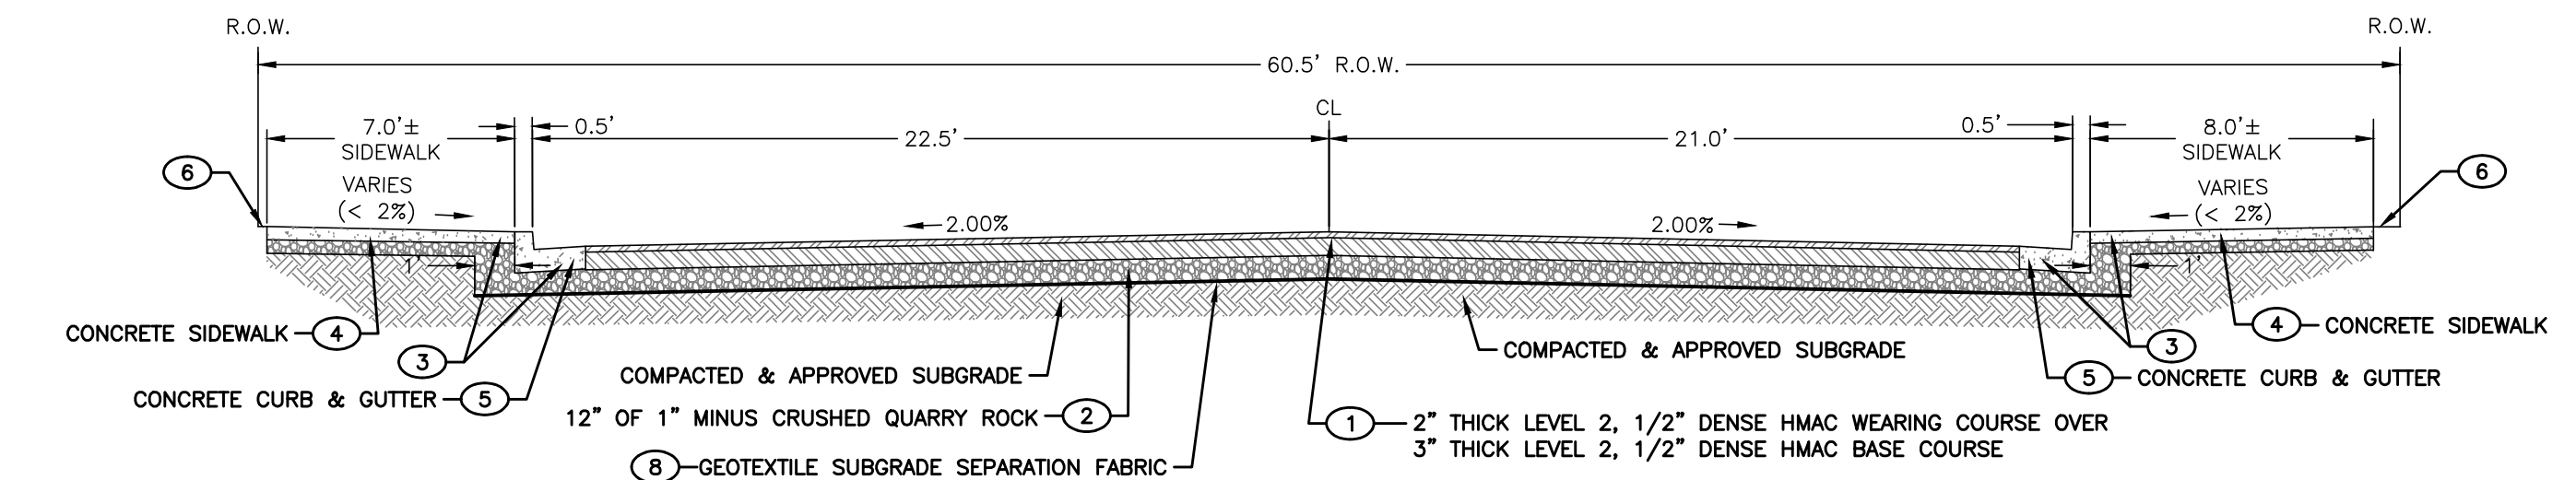


2ND STREET — TYPICAL SECTION

STA 7+05.56 TO STA 8+88.00
(NOT TO SCALE)

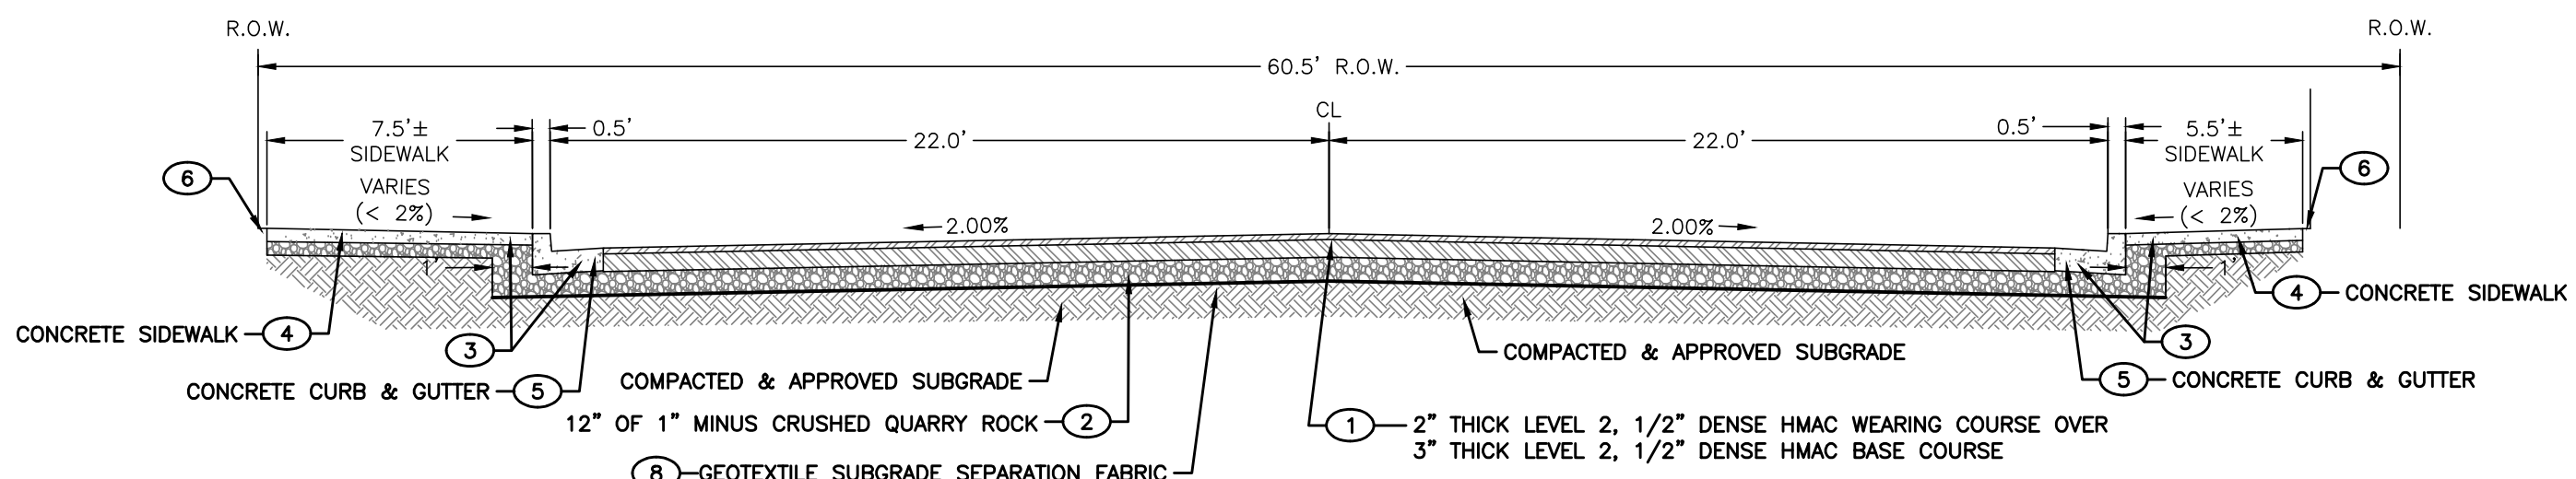


2ND STREET — TYPICAL SECTION

STA 9+71.33 TO STA 10+57.00
(NOT TO SCALE)

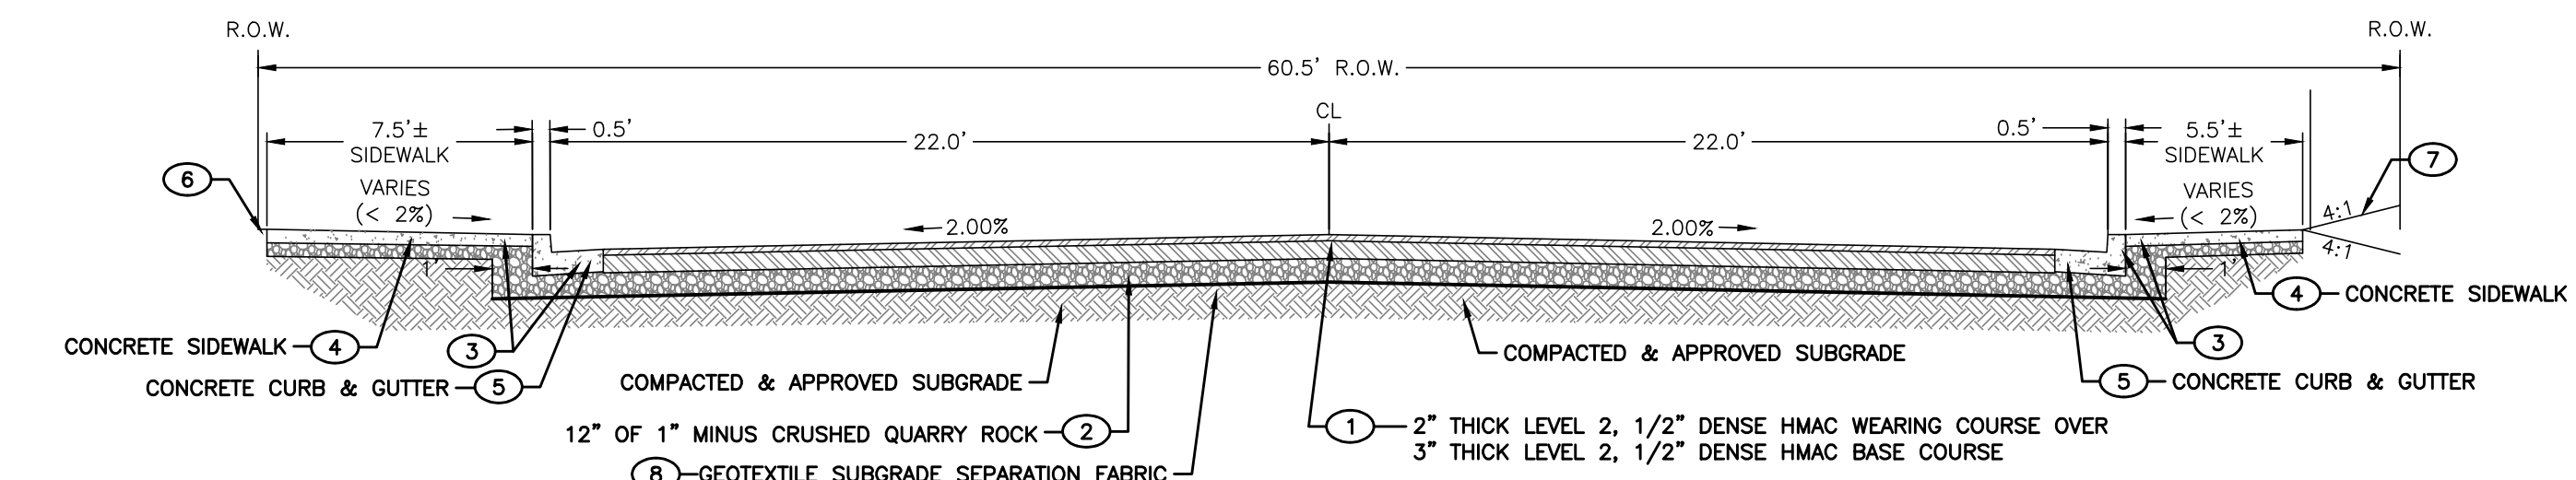


2ND STREET — TYPICAL SECTION

STA 10+57.00 TO STA 11+47.26
(NOT TO SCALE)

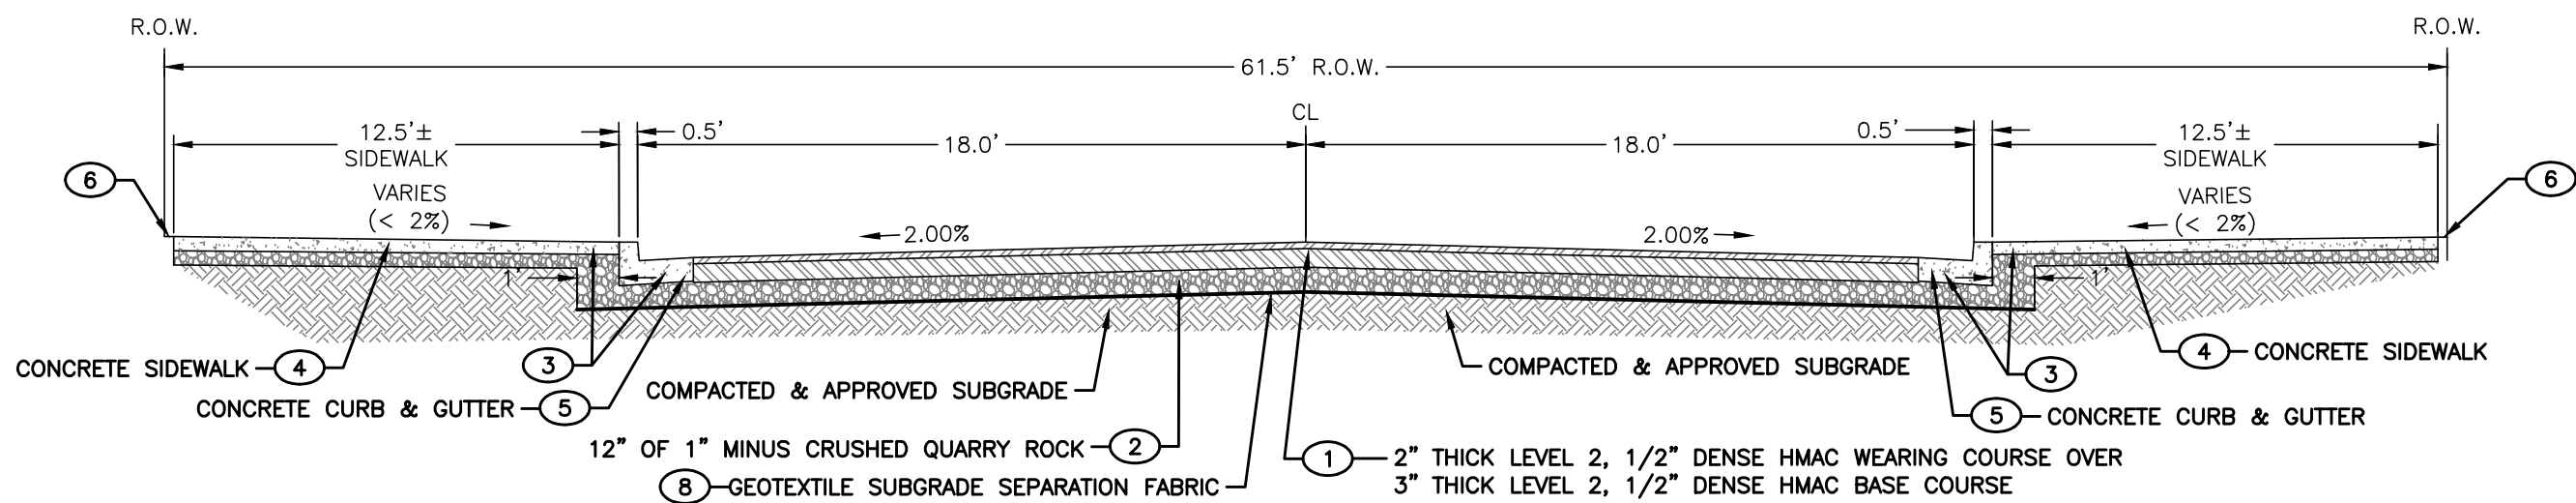

SMITH STREET — TYPICAL SECTION

STA 0+91.38 TO STA 4+06.93
(NOT TO SCALE)

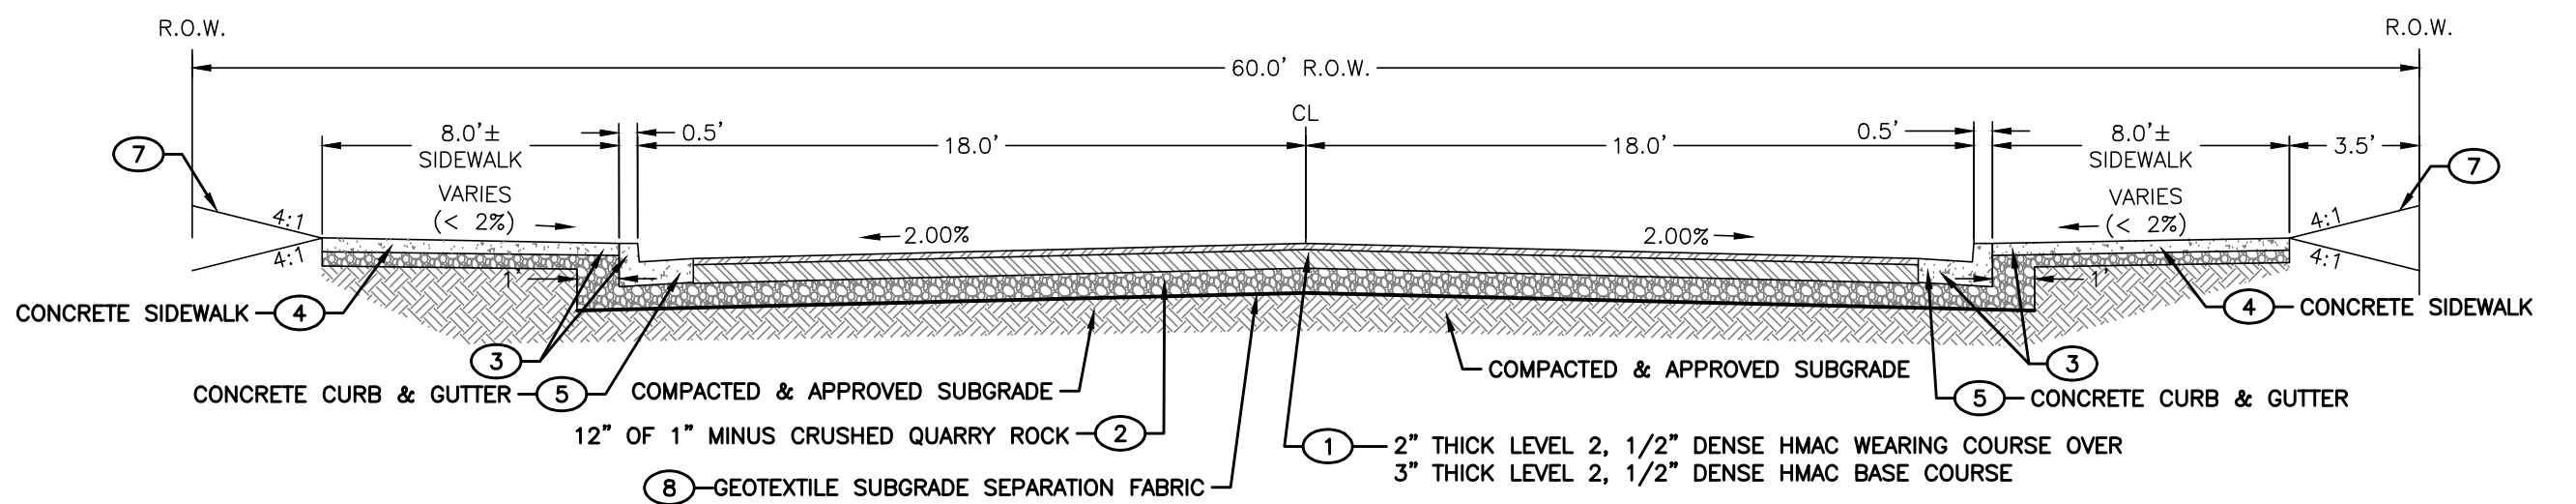

MACY STREET — TYPICAL SECTION

STA 4+02.68 TO STA 7+92.83
(NOT TO SCALE)

CONSTRUCTION NOTES

- PAVEMENT BASE COURSE SHALL BE ONE 3" LIFT OF LEVEL 2, 1/2" DENSE GRADED HMAC. WEARING COURSE SHALL BE ONE 2" LIFT OF LEVEL 2, 1/2" DENSE GRADED HMAC. FOLLOW 2018 OREGON STANDARD SPECIFICATIONS FOR CONSTRUCTION.
- BASE ROCK SHALL BE 10" MIN. 1"-0" CRUSHED QUARRY ROCK AGGREGATE. AGGREGATE SHALL BE COMPACTED TO 95% RELATIVE MAXIMUM DENSITY AS DETERMINED BY AASHTO T-180. FOLLOW 2018 OREGON STANDARD SPECIFICATIONS FOR CONSTRUCTION.
- PORTLAND CEMENT CONCRETE SHALL ATTAIN A MINIMUM COMPRESSIVE STRENGTH OF 3000 PSI WITHIN 28 DAYS. FOLLOW 2018 OREGON STANDARD SPECIFICATIONS FOR CONSTRUCTION.
- CONCRETE SIDEWALK TO BE 4" THICK PER OREGON STANDARD DRAWING RD720 OVER 4" OF 1"-0" CRUSHED QUARRY ROCK.
- CONCRETE CURB & GUTTER PER OREGON STANDARD DRAWING RD700. 6" CURB EXPOSURE AND 4% GUTTER PAN SLOPE.
- EXTEND PROPOSED SIDEWALK TO EXISTING BUILDING. PLACE EXPANSION JOINT MATERIAL BETWEEN PROPOSED SIDEWALK AND EXISTING BUILDING OR STRUCTURE.
- RESTORE LANDSCAPING TO ORIGINAL OR BETTER CONDITION. COORDINATE WITH OWNER FOR LANDSCAPE RESTORATION.
- GEOTEXTILE SUBGRADE SEPARATION FABRIC TO BE PROPEX GEO-SOLUTIONS GEOTEX 200ST.

LEGEND

EXISTING

- APPROX. PROPERTY LINE (SEE SURVEY)
- CURB
- TOP OF SLOPE
- BOTTOM OF SLOPE
- BOTTOM OF SWALE
- FENCE
- WASTE WATER SEWER
- STORM WATER SEWER
- WATER LINE
- GAS LINE
- SIGN
- FIRE HYDRANT
- WATER VALVE
- WATER METER
- ELECTRIC BOX
- ELECTRIC VAULT
- FENCE POST

- POWER POLE
- STREET LIGHT
- TELEPHONE VAULT
- TELEPHONE RISER
- CURB INLET
- STORMWATER MANHOLE
- WASTEWATER MANHOLE
- CONCRETE SIDEWALK
- GRAVEL
- BUILDING
- DECIDUOUS TREE
- CONIFEROUS TREE

DEMOLITION

- SAWCUT LINE
- TREE TO BE REMOVED

IMPROVEMENTS

- NEW CONCRETE SIDEWALK
- NEW CONCRETE CURB
- CONCRETE DRIVEWAY
- NEW WATER LINE
- NEW STORMWATER LINE
- NEW STORMWATER MANHOLE
- NEW SIGN
- NEW FIRE HYDRANT
- NEW WATER VALVE
- NEW WATER METER
- NEW DECIDUOUS STREET TRE
- NEW STREET LIGHT

project title:

CITY OF HARRISBURG Smith, Macy, & 2nd Street Rehabilitation

Smith - 1st To 3rd, Macy - 2nd To 3rd, 2nd - Smith To Macy
HARRISBURG, OREGON

revisions:

date: JANUARY 28, 2020
drawn by: GAM
designer: GAM
project no: 17-009F


Typical Sections
and General
Notes

sheet:

C2



Z:\2017\17-009F Harrisburg Smith Street\Drawing\17-009F Street Improvements.dwg / 2/25/2020 2:01 PM JLL/E

copyright © 2016 Branch Engineering, Inc.

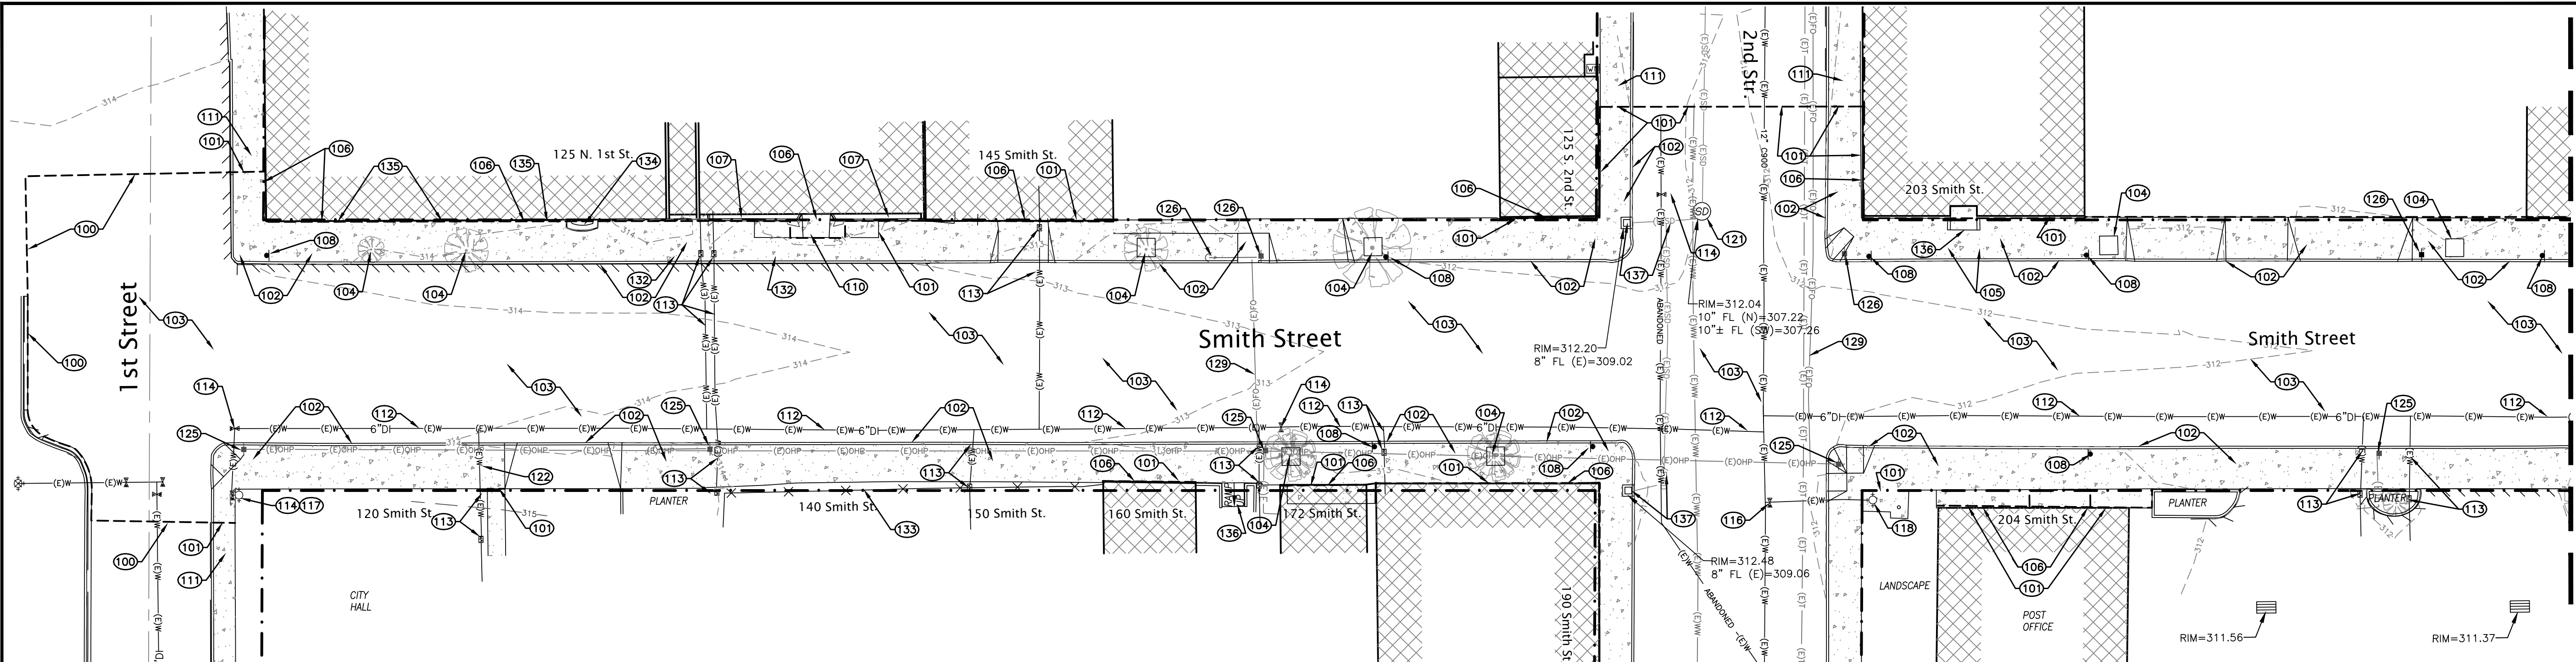

CONSTRUCTION NOTES

- 100 → SAWCUT EXISTING AC PAVEMENT. PROTECT SAWCUT EDGE FROM DAMAGE.
- 101 → SAWCUT EXISTING CONCRETE. PROTECT SAWCUT EDGE FROM DAMAGE. SAWCUT AS CLOSE TO BUILDING AS POSSIBLE WITHOUT DAMAGING BUILDING TO REMOVE EXISTING SIDEWALK.
- 102 → REMOVE EXISTING CONCRETE SIDEWALK (AND RAMPS) AND CONCRETE CURB & GUTTER.
- 103 → REMOVE EXISTING ASPHALT PAVEMENT. REMOVE EXISTING BASE ROCK AND SUBGRADE AS REQUIRED FOR NEW PAVEMENT SECTION FINISHED GRADE.
- 104 → REMOVE EXISTING TREE/VEGETATION (ROOT BALLS AND STUMPS ALSO) AND ASSOCIATED SOIL.
- 105 → REMOVE EXISTING CANOPY. COORDINATE WITH OWNER FOR REMOVAL AND REINSTALLATION.
- 106 → PROTECT EXISTING BUILDING.
- 107 → PROTECT EXISTING BRICK PLANTER.
- 108 → REMOVE EXISTING SIGN AND POLE. INSTALL NEW SIGN, POST AND FOUNDATION TO LOCATION SHOWN ON STREET IMPROVEMENT PLANS.
- 109 → REMOVE EXISTING BIKE RACK AND RETURN TO CITY.
- 110 → PROTECT EXISTING CONCRETE RAMP.
- 111 → PROTECT EXISTING CONCRETE SIDEWALK.
- 112 → EXISTING PUBLIC WATER MAIN TO REMAIN IN SERVICE UNTIL NEW PUBLIC WATER MAIN IS CONSTRUCTED AND APPROVED FOR USE.
- 113 → PROTECT EXISTING WATER METER AND BOX AND KEEP IN SERVICE UNTIL NEW WATER SERVICE AND METER ARE CONSTRUCTED. SEE WATERLINE PLAN SHEET C19 FOR MORE INFORMATION.
- 114 → REMOVE WATER VALVE BOXES ONCE NEW WATERLINE IS INSTALLED. ONCE NEW WATERLINE IS APPROVED, ABANDON EXISTING WATERLINE.
- 116 → PROTECT EXISTING WATER VALVES. ADJUST VALVE BOXES AS REQUIRED FOR FINAL PAVING.
- 117 → PROTECT EXISTING FIRE HYDRANT. EXISTING FIRE HYDRANT TO REMAIN IN PLACE UNTIL NEW HYDRANT IS CONSTRUCTED AND APPROVED.
- 118 → PROTECT EXISTING FIRE HYDRANT.
- 119 → REMOVE EXISTING CATCH BASIN. PROTECT EX. STORM PIPE FOR RE-USE.
- 121 → PROTECT EXISTING STORM MANHOLE RIM. ADJUST AS REQUIRED. REGROUT IF REQUIRED.
- 122 → REMOVE EXISTING DOWNSPOUT PIPING BACK TO DOWNSPOUT. SEE STREET IMPROVEMENT PLANS FOR INSTALLATION OF NEW DOWNSPOUT PIPING.
- 123 → PROTECT EXISTING CATCH BASIN AND STORM LINE.
- 124 → EXISTING POWER POLE TO BE RELOCATED. COORDINATE WORK WITH PACIFIC POWER (ELKE VATH 541-967-6160).
- 125 → EXISTING POWER POLE TO REMAIN. COORDINATE WORK WITH PACIFIC POWER (ELKE VATH 541-967-6160).
- 126 → EXISTING POWER POLE TO BE REMOVED. COORDINATE WORK WITH PACIFIC POWER (ELKE VATH 541-967-6160).
- 127 → PROTECT EXISTING GAS LINE.
- 129 → PROTECT EXISTING FIBER OPTIC LINE.
- 130 → REMOVE EXISTING SIGN AND POLE.
- 131 → PROTECT EXISTING BOLLARDS.
- 132 → REMOVE EXISTING UTILITY BOX AND ABANDON EXISTING UTILITY.
- 133 → PROTECT EXISTING FENCE.
- 134 → REMOVE EXISTING CONCRETE STEPS.
- 135 → PROTECT EXISTING FOUNDATION VENTS.
- 136 → SAWCUT CONCRETE RAMP AND REMOVE.
- 137 → REMOVE EXISTING CATCH BASIN AND STORM LINE BACK TO MANHOLE.

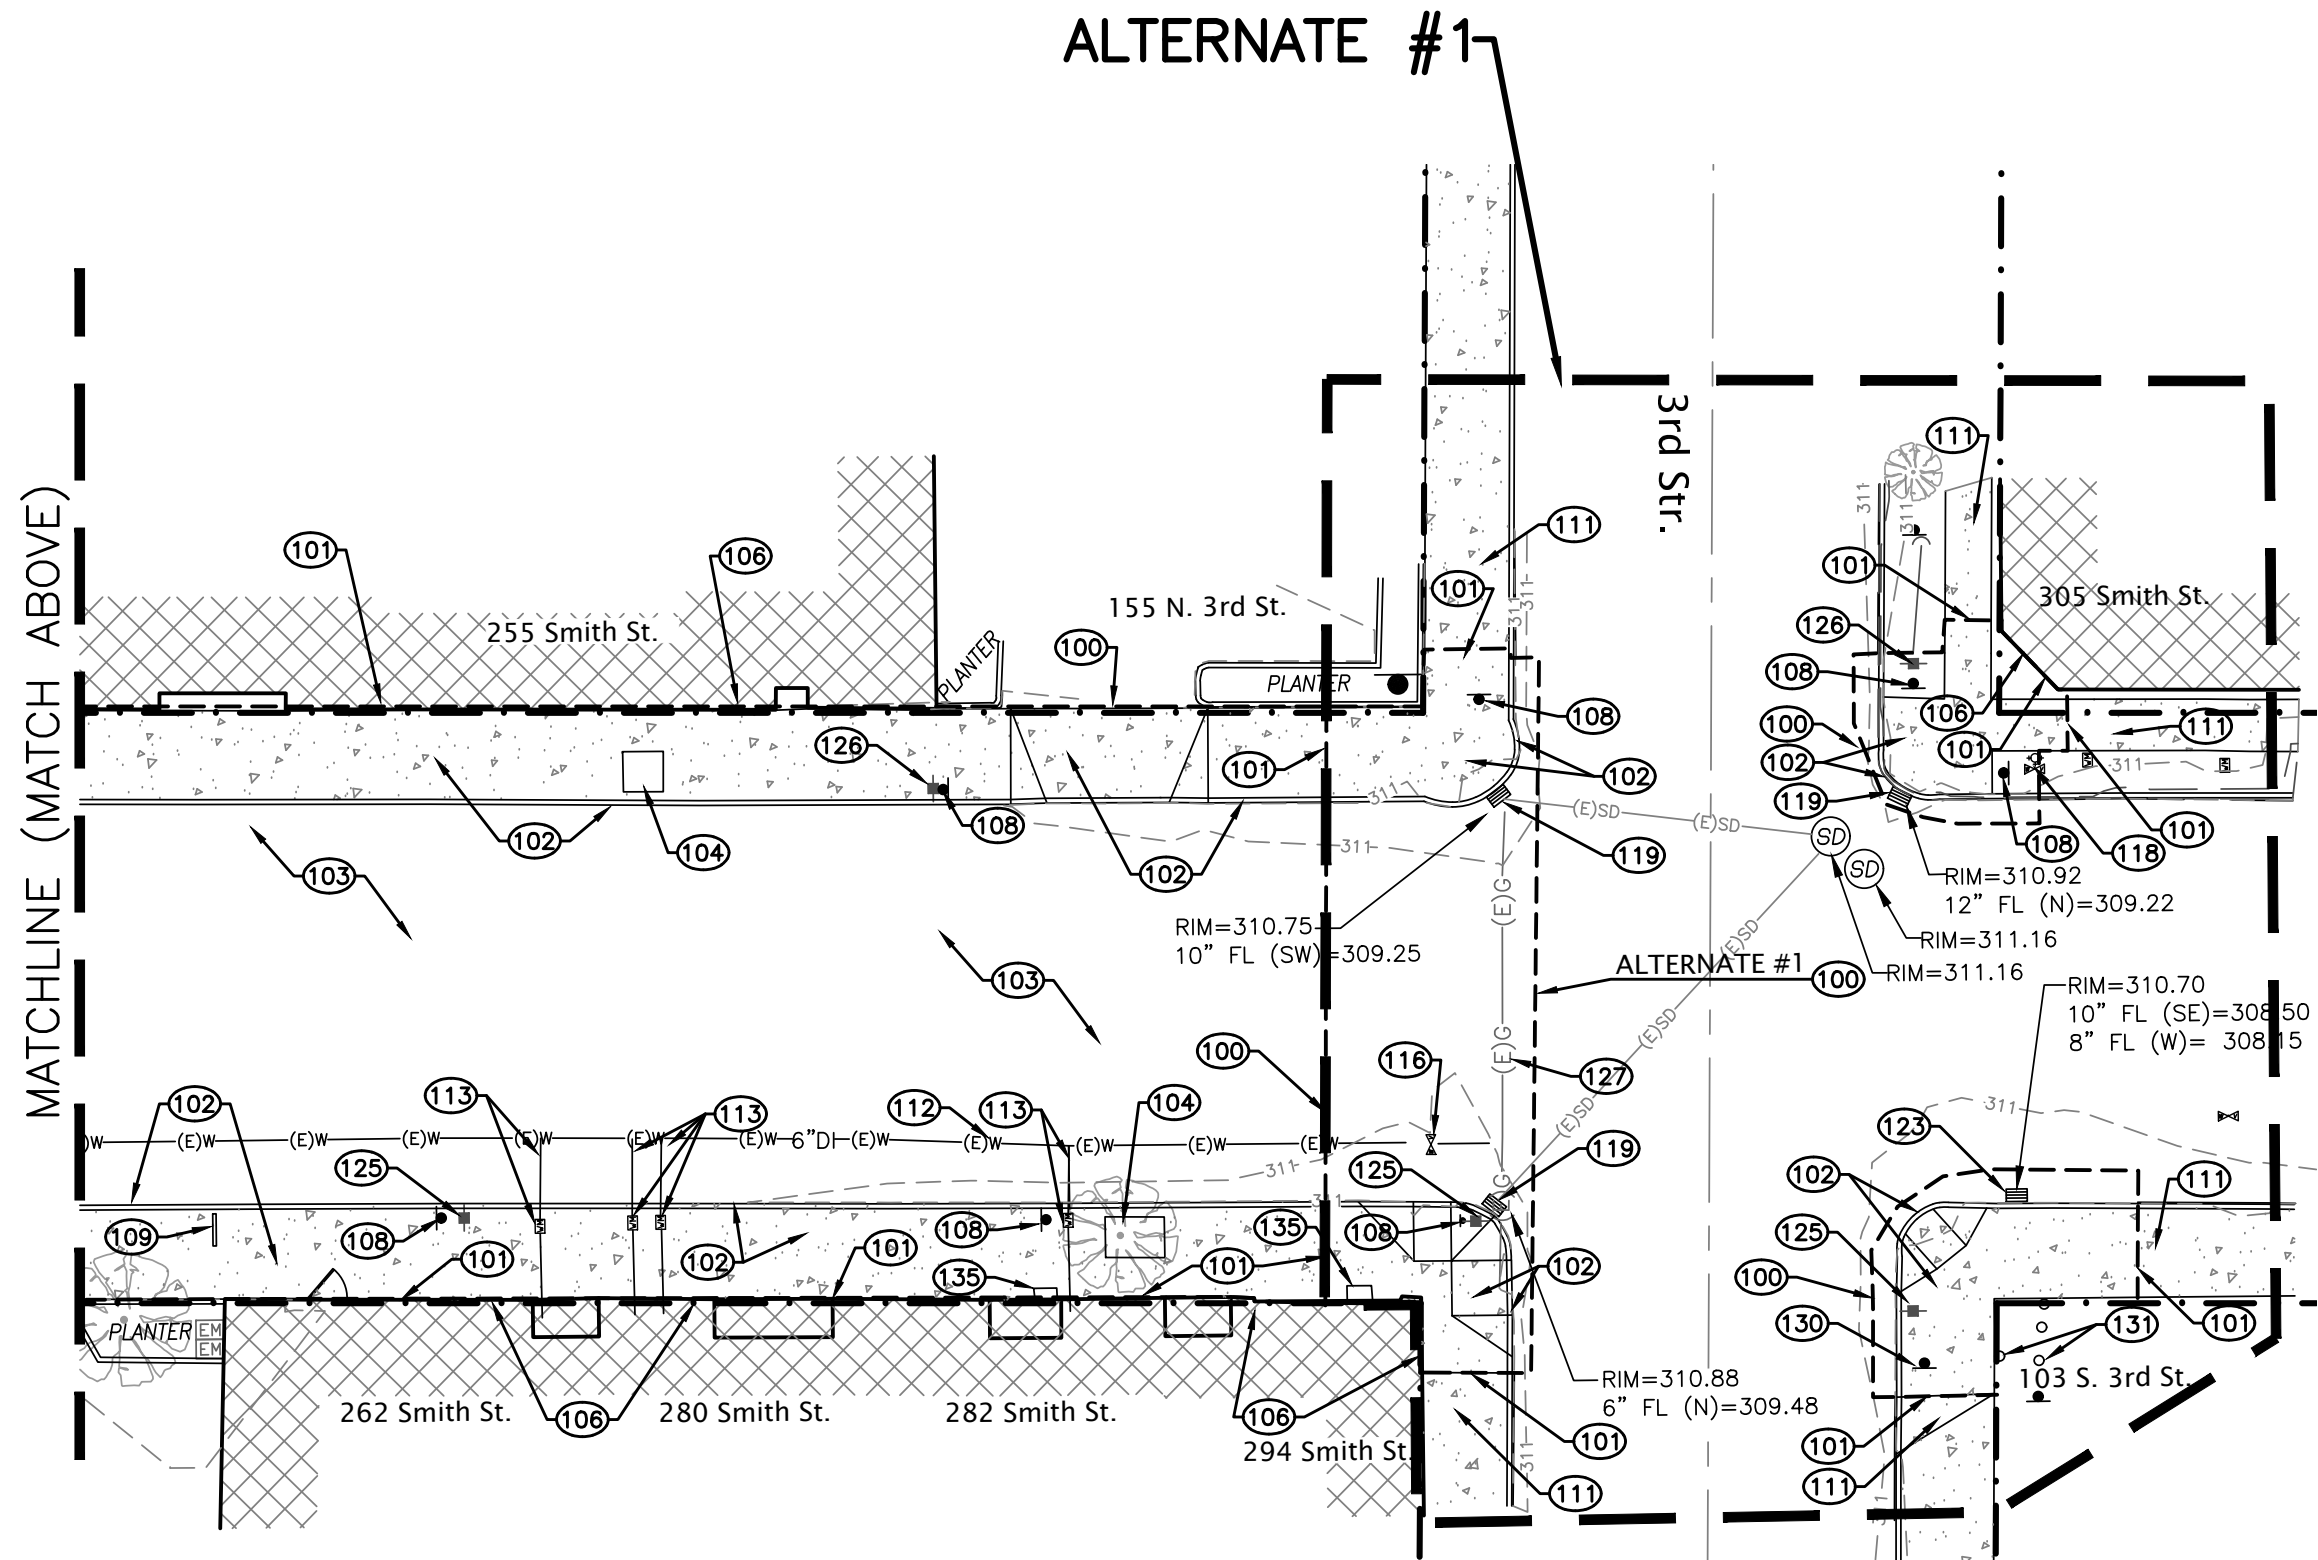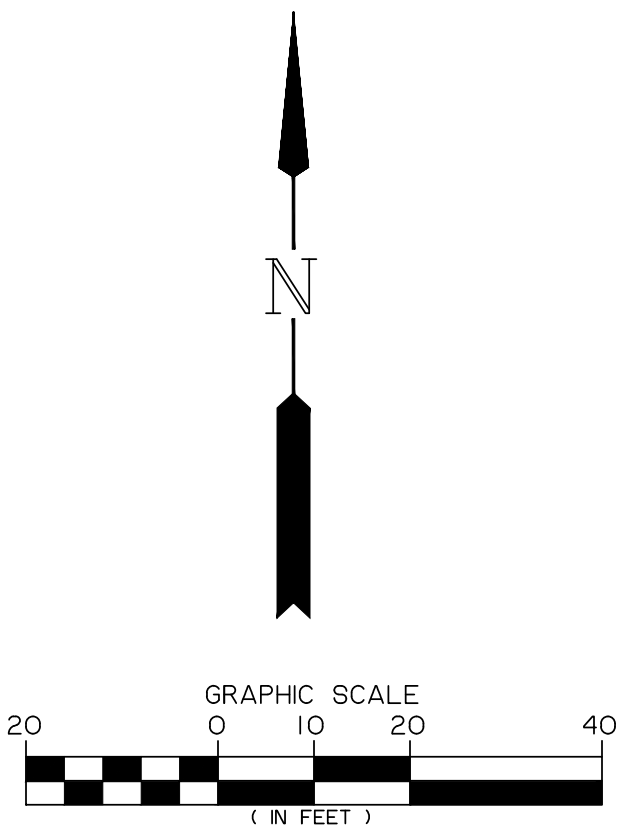

EXPIRES: DECEMBER 31, 2020

project title:

CITY OF HARRISBURG Smith, Macy, & 2nd Street Rehabilitation

Smith - 1st To 3rd, Macy - 2nd To 3rd, 2nd - Smith To Macy
HARRISBURG, OREGON


revisions:

date: JANUARY 28, 2020
drawn by: GAM
designer: GAM
project no: 17-009F

Smith Street
Ex. Conditions
& Demolition
Plan


sheet:

C3

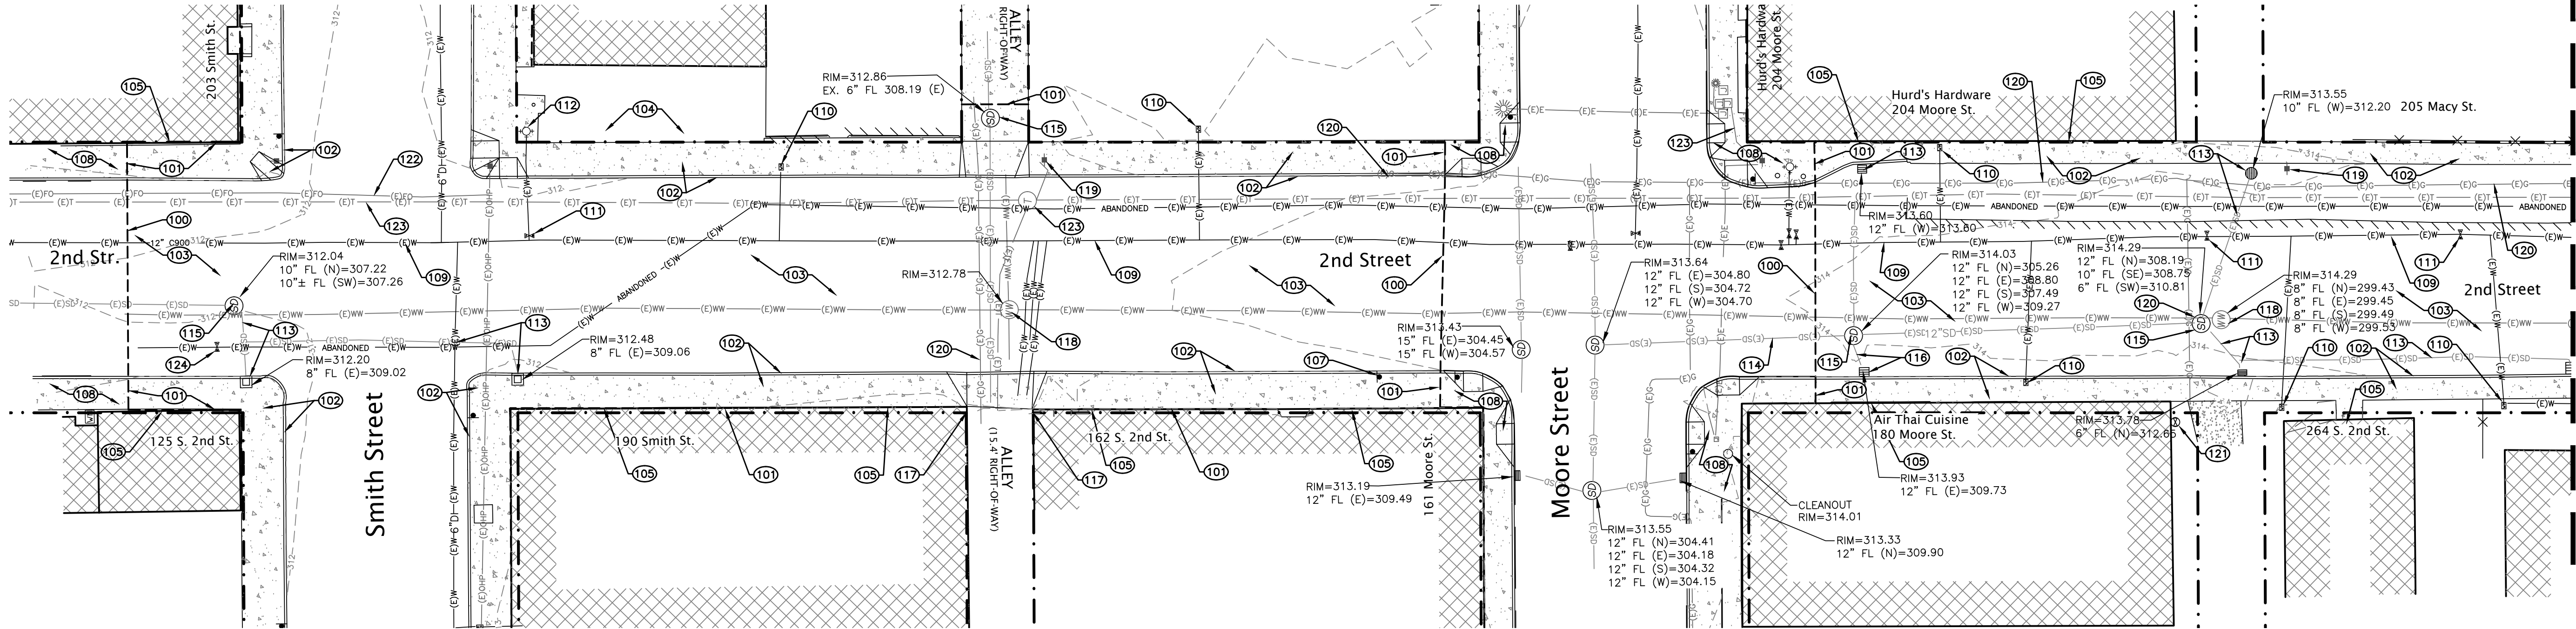

CONSTRUCTION NOTES

- 100 → SAWCUT EXISTING AC PAVEMENT. PROTECT SAWCUT EDGE FROM DAMAGE.
- 101 → SAWCUT EXISTING CONCRETE. PROTECT SAWCUT EDGE FROM DAMAGE.
- 102 → REMOVE EXISTING CONCRETE SIDEWALK (AND RAMPS) AND CONCRETE CURB & GUTTER.
- 103 → REMOVE EXISTING ASPHALT PAVEMENT. REMOVE EXISTING BASE ROCK AND SUBGRADE AS REQUIRED FOR NEW PAVEMENT SECTION FINISHED GRADE.
- 104 → PROTECT EXISTING LANDSCAPING.
- 105 → PROTECT EXISTING BUILDING.
- 106 → PROTECT EXISTING BRICK PLANTER
- 107 → REMOVE EXISTING SIGN AND POLE. INSTALL NEW SIGN, POST AND FOUNDATION TO LOCATION SHOWN ON STREET IMPROVEMENT PLAN.
- 108 → PROTECT EXISTING CONCRETE SIDEWALK.
- 109 → PROTECT EXISTING PUBLIC WATER MAIN.
- 110 → PROTECT EXISTING WATER METER AND BOX. ADJUST TO FINISHED GRADE AS NECESSARY.
- 111 → PROTECT EXISTING WATER VALVES. ADJUST VALVE BOXES AS REQUIRED FOR FINAL PAVING.
- 112 → PROTECT EXISTING FIRE HYDRANT.
- 113 → REMOVE EXISTING CATCH BASIN AND STORM LINE BACK TO MANHOLE.
- 114 → EXISTING STORM PIPE TO BE PROTECTED.
- 115 → PROTECT EXISTING STORM MANHOLE RIM. ADJUST AS REQUIRED. REGROUT IF REQUIRED.
- 116 → PROTECT EXISTING STORM CATCH BASIN AND STORM LINE. ADJUST AS REQUIRED. REGROUT IF REQUIRED.
- 117 → REMOVE EXISTING DOWNSPOUT PIPING BACK TO DOWNSPOUT. SEE STREET IMPROVEMENT PLANS FOR INSTALLATION OF NEW DOWNSPOUT PIPING.
- 118 → PROTECT EXISTING WASTEWATER MANHOLE RIM. ADJUST AS REQUIRED. REGROUT IF REQUIRED.
- 119 → EXISTING POWER POLE TO REMAIN. COORDINATE WORK WITH PACIFIC POWER (ELKE VATH 541-967-6160).
- 120 → PROTECT EXISTING GAS LINE.
- 121 → PROTECT EXISTING GAS VALVE. ADJUST VALVE BOXES AS REQUIRED FOR FINAL PAVING.
- 122 → PROTECT EXISTING FIBER OPTIC LINE.
- 123 → PROTECT EXISTING TELEPHONE LINE.
- 124 → REMOVE EXISTING VALVE BOX OF ABANDONED WATERLINE.

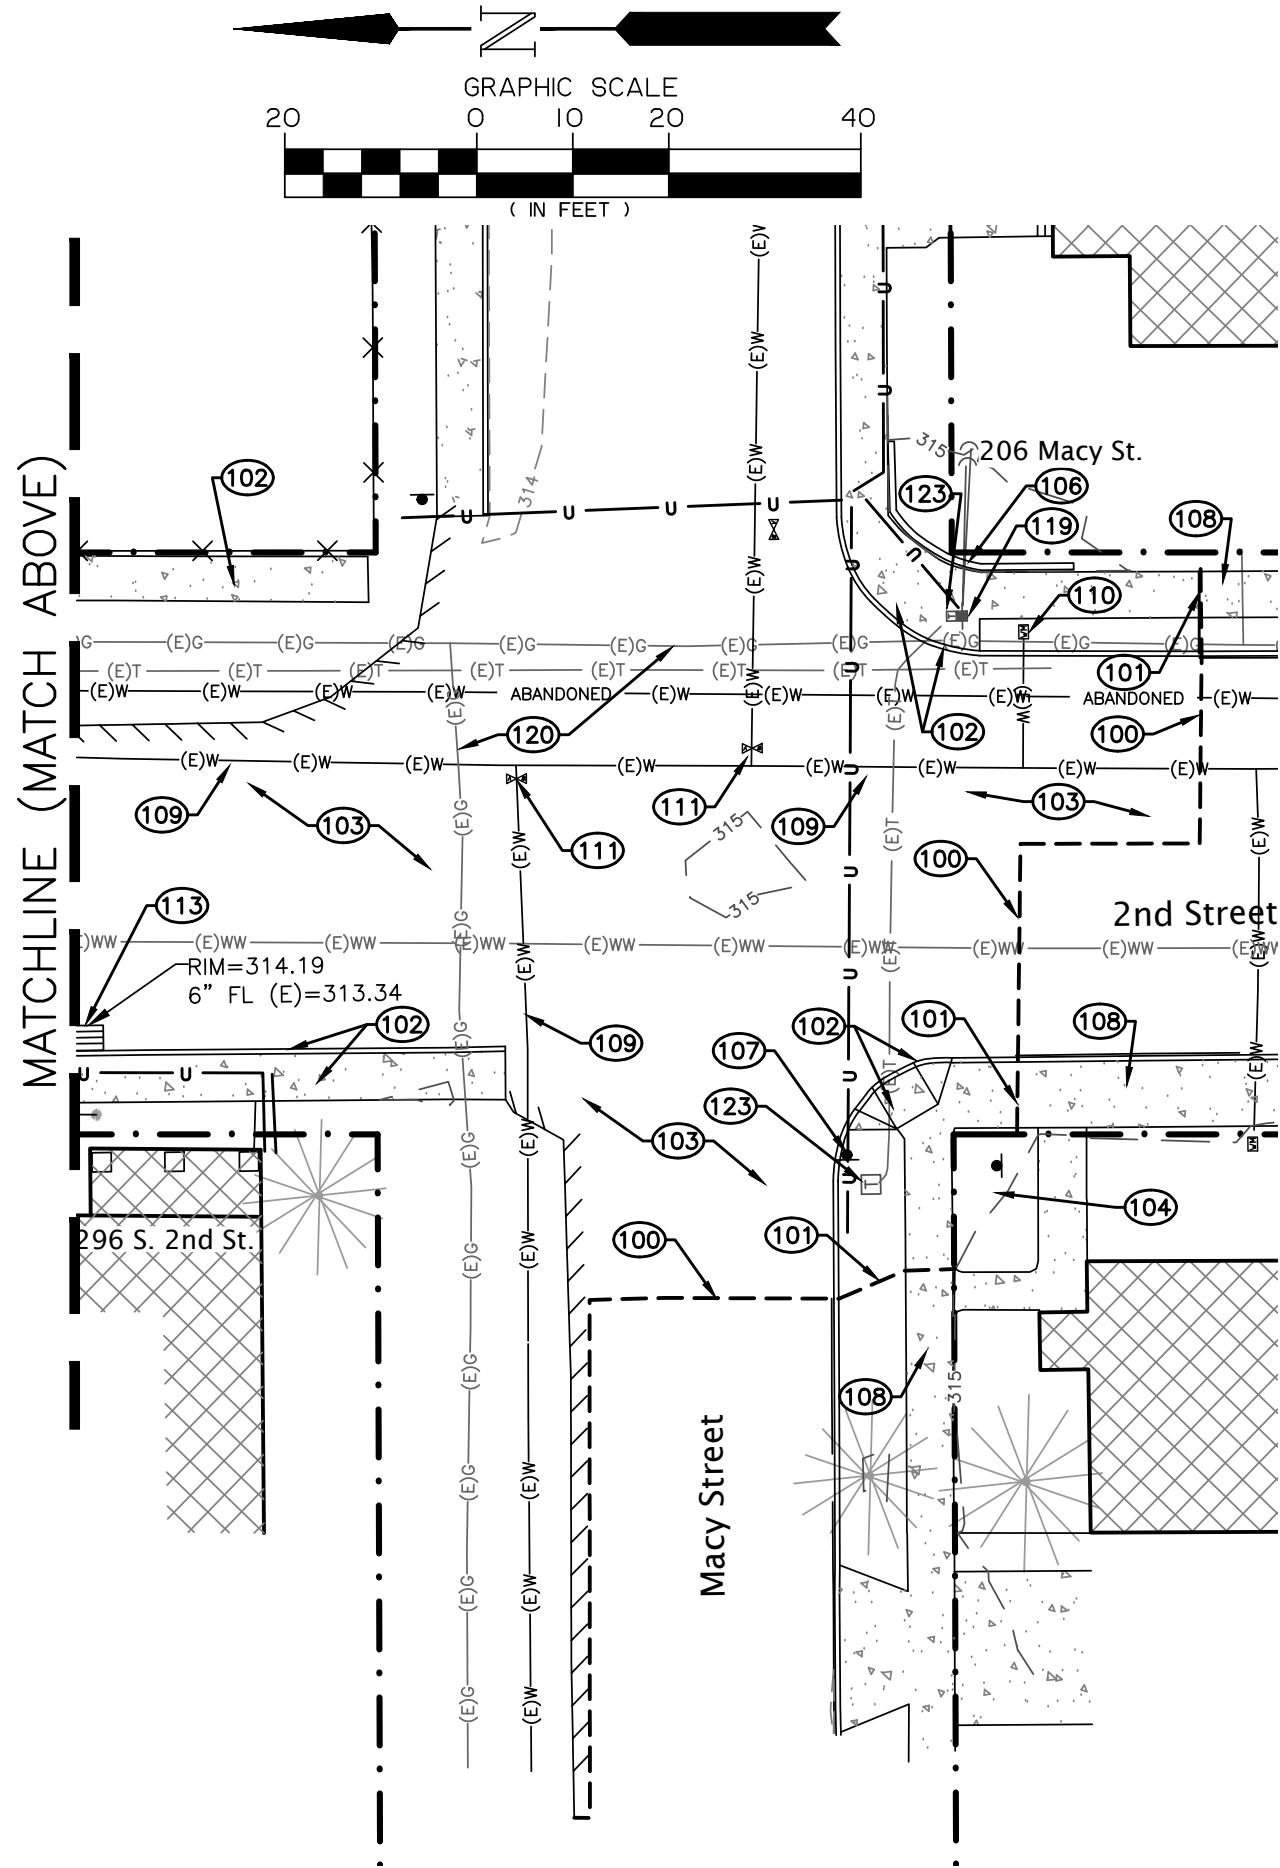

project title:

CITY OF HARRISBURG
Smith, Macy, & 2nd Street Rehabilitation
Smith - 1st To 3rd, Macy - 2nd To 3rd, 2nd - Smith To Macy
HARRISBURG, OREGON


revisions:

date: JANUARY 28, 2020
drawn by: GAM
designer: GAM
project no: 17-009F

2nd Street
Ex. Conditions
& Demolition
Plan

sheet:

C4

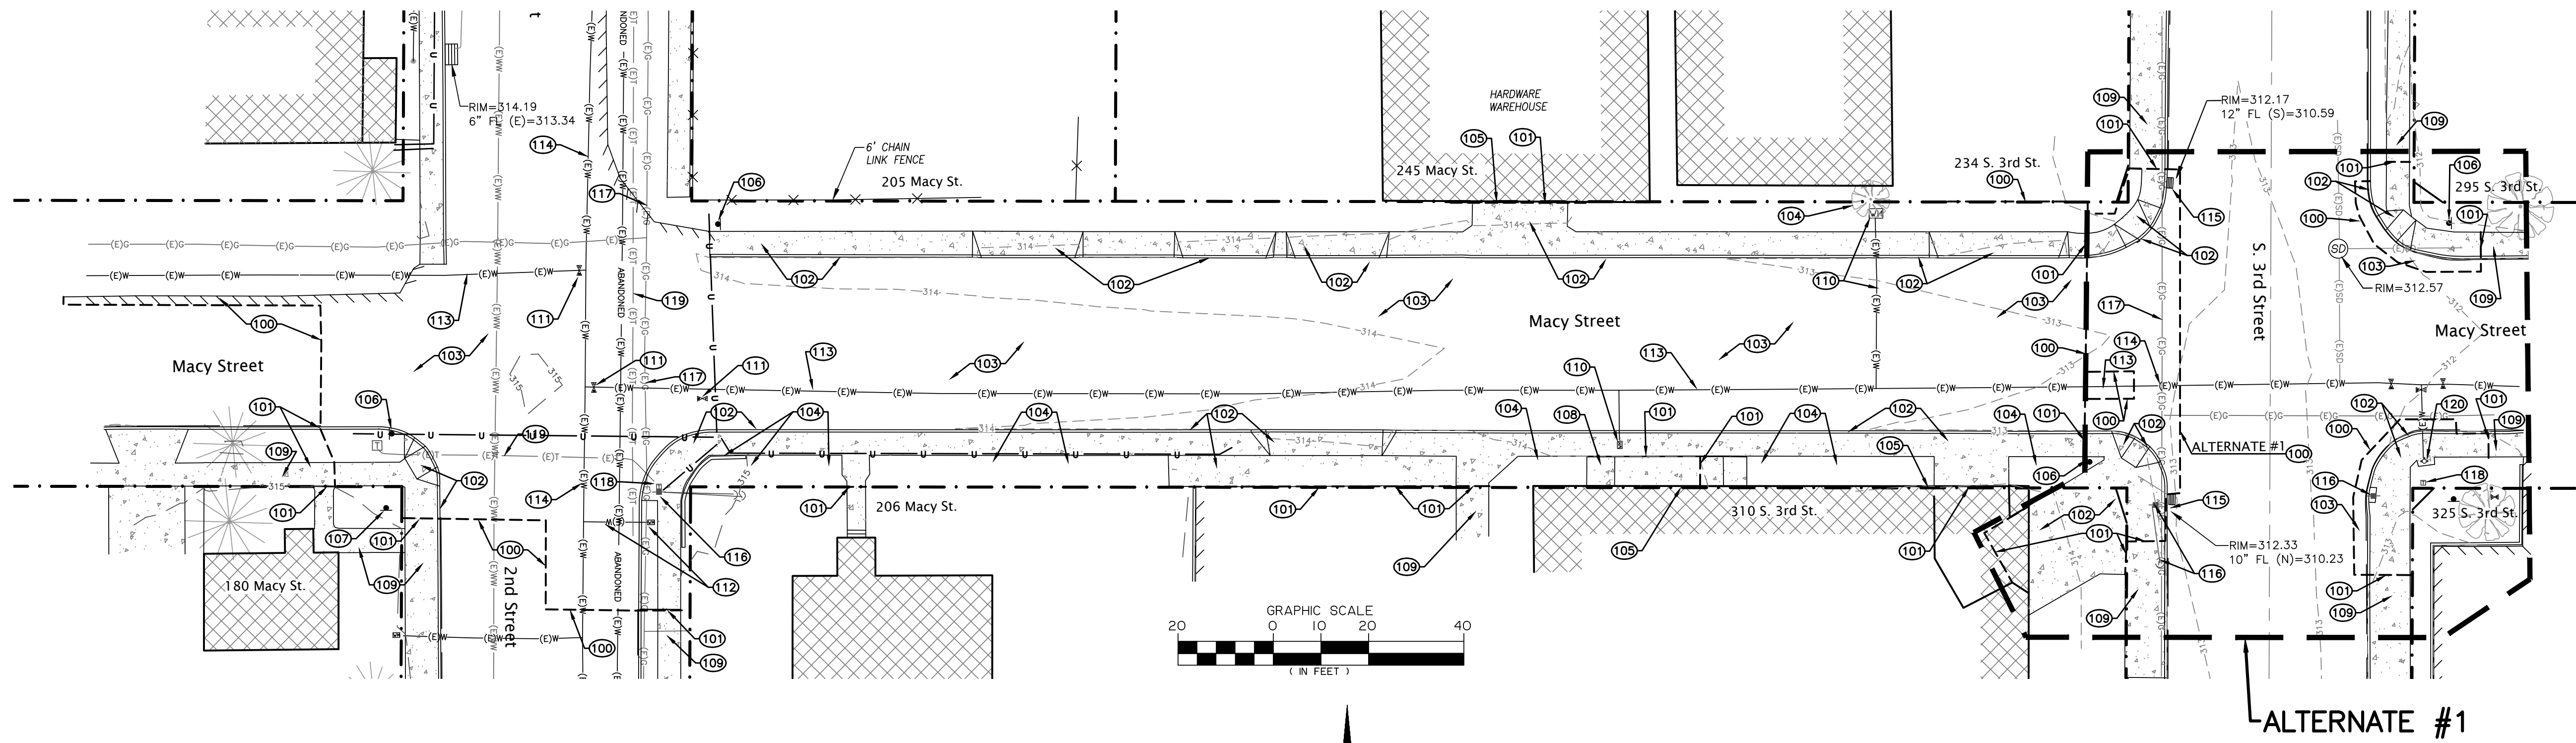

CONSTRUCTION NOTES

- 100 → SAWCUT EXISTING AC PAVEMENT. PROTECT SAWCUT EDGE FROM DAMAGE.
- 101 → SAWCUT EXISTING CONCRETE. PROTECT SAWCUT EDGE FROM DAMAGE.
- 102 → REMOVE EXISTING CONCRETE SIDEWALK (AND RAMPS) AND CONCRETE CURB & GUTTER.
- 103 → REMOVE EXISTING ASPHALT PAVEMENT. REMOVE EXISTING BASE ROCK AND SUBGRADE AS REQUIRED FOR NEW PAVEMENT SECTION FINISHED GRADE.
- 104 → REMOVE EXISTING RETAINING WALL BLOCKS, LANDSCAPE BOULDERS, LIGHTING AND VEGETATION (ROOT BALLS AND STUMPS ALSO) AND ASSOCIATED SOIL. COORDINATE WITH PROPERTY OWNER FOR SALVAGE.
- 105 → PROTECT EXISTING BUILDING.
- 106 → REMOVE EXISTING SIGN AND POLE. INSTALL NEW SIGN, POST AND FOUNDATION TO LOCATION SHOWN ON STREET IMPROVEMENT PLANS.
- 107 → PROTECT EXISTING SIGN AND POLE.
- 108 → PROTECT EXISTING CONCRETE RAMP.
- 109 → PROTECT EXISTING CONCRETE SIDEWALK.
- 110 → PROTECT EXISTING WATER METER AND BOX AND KEEP IN SERVICE UNTIL NEW WATER SERVICE AND METER ARE CONSTRUCTED. SEE WATERLINE PLAN SHEET C19 FOR MORE INFORMATION.
- 111 → REMOVE WATER VALVE BOXES ONCE NEW WATERLINE IS INSTALLED. ONCE NEW WATERLINE IS APPROVED, ABANDON EXISTING WATERLINE.
- 112 → PROTECT AND RELOCATE EXISTING WATER METER AND ADJUST TO FINISHED GRADE OF PROPOSED STREET IMPROVEMENTS.
- 113 → EXISTING PUBLIC WATER MAIN TO REMAIN IN SERVICE UNTIL NEW PUBLIC WATER MAIN IS CONSTRUCTED AND APPROVED FOR USE.
- 114 → PROTECT EXISTING WATER.
- 115 → PROTECT EXISTING STORM CATCH BASIN.
- 116 → EXISTING POWER POLE AND ANCHOR TO REMAIN. COORDINATE WORK WITH PACIFIC POWER (ELKE VATH 541-967-6160).
- 117 → PROTECT EXISTING GAS LINE.
- 118 → EXISTING TELEPHONE RISER TO BE INSTALLED IN UNDERGROUND VAULT. COORDINATE WORK WITH CENTURY LINK (LUKE PILON 541-484-7827).
- 119 → PROTECT EXISTING UNDERGROUND TELEPHONE/FIBER OPTICS.
- 120 → EXISTING FIRE HYDRANT TO BE RELOCATED AS SHOWN ON SHEET C20.

project title:

CITY OF HARRISBURG Smith, Macy, & 2nd Street Rehabilitation

Smith - 1st To 3rd, Macy - 2nd To 3rd, 2nd - Smith To Macy
HARRISBURG, OREGON

revisions:

date: JANUARY 28, 2020
drawn by: GAM
designer: GAM
project no: 17-009F

Macy Street
Ex. Conditions
& Demolition
Plan

sheet:

C5

CONSTRUCTION NOTES


- ADJUST EXISTING WATER VALVE BOXES TO PROPOSED FINISHED GRADE.
- CONSTRUCT 48" CONCRETE STORM MANHOLE PER ODOT STD DWG RD335. SEE PROFILE FOR RIM AND PIPE ELEVATIONS.
- CONSTRUCT G-2 CONCRETE CATCH BASIN PER ODOT STD DWG RD364. SEE PROFILE FOR RIM AND PIPE ELEVATIONS.
- FURNISH AND INSTALL 12" PVC D3034 STORM LINE. CLASS B BACKFILL. SEE ODOT TYPICAL TRENCH DETAIL RD300.
- CONTRACTOR TO POT HOLE EXISTING UTILITY AND CONFIRM LOCATION, MATERIAL, SIZE AND DEPTH. NOTIFY ENGINEER IF DISCREPANCIES ARE DISCOVERED.
- ABANDON EXISTING 12" STORM LINE IN PLACE.
- FURNISH AND INSTALL 3" PVC SCH40 ROOF DRAIN TO WEEP HOLE. CONNECT TO EXISTING USING APPROPRIATE FITTINGS.
- PROPOSED STREET LIGHTING PER SHEETS C22-C24 AND PACIFIC POWER AND LIGHTING (PP&L) COORDINATE WITH PP&L. CONTACT ELKE VATH 541-967-6160.
- REPLACE EXISTING POLE MOUNTED STREET LIGHT ON EXISTING POLE WITH NEW POLE MOUNTED STREET LIGHT ON EXISTING POLE TO REMAIN. POLE MOUNTED STREET LIGHT TO MATCH GROUND MOUNTED STREET LIGHT. CONTACT ELKE VATH AT 541-967-6160.
- CONSTRUCT PAVEMENT SECTION, CURB & GUTTER AND SIDEWALK PER TYPICAL SECTIONS, SHEET C2.
- CONSTRUCT CONCRETE DRIVEWAY PER OREGON STANDARD DWG RD745 OPTION K. PLACE 6" MINIMUM THICKNESS OF 1"-0" CRUSHED QUARRY ROCK.
- CONSTRUCT CURB RETURN WITH ADA RAMPS. PLACE 4" MINIMUM THICKNESS OF 1"-0" CRUSHED QUARRY ROCK. SEE SHEETS C11 & C12 FOR CURB RETURN DETAILS WITH DIMENSIONS AND SPOT ELEVATIONS.
- CONSTRUCT 6" HIGH, 10" WIDE AND 3' LONG CONCRETE STEP FOR ENTRANCE TO EXISTING BUILDING. SEE DETAIL 1, SHEET C26.
- SEAL PAVEMENT JOINT. TACK COAT EXISTING PAVEMENT EDGES. THE MATCHLINE TO EXISTING PAVING SHALL COMPLY WITH ODOT STANDARD DRAWING RD302.
- FURNISH AND INSTALL 4'X4' TREE WELL AND 2.5" CALIPER TREE PER TREE WELL DETAIL, SHEET C25. INSTALL TREE WELL GRATE AND FRAME PER MANUFACTURER'S RECOMMENDATIONS.
- PLACE EXPANSION JOINT ALONG EXISTING BUILDINGS OR STRUCTURES THAT SIDEWALK WILL ABUT AGAINST. SEE DETAIL 3, SHEET C26.
- CONSTRUCT CONCRETE RAMP TO EXISTING DOOR. 4" THICK CONCRETE.
- SAWCUT EXISTING RAMP AT LOCATION INDICATED AND NEW SIDEWALK TO MATCH EXISTING RAMP. MODIFY RAMP AND EXISTING HAND RAILS AS REQUIRED.
- CONTRACTOR TO INSTALL NEW 30"X30" ALUMINUM STOP SIGN PER MUTCD R1-1 AND STREET SIGNS PER MUTCD D3-1 ON 2"-12 GAUGE P.S.S.T. POST PER OREGON STANDARD DRAWINGS TM200, TM223, TM681 AND TM687.
- CONTRACTOR TO INSTALL NEW "NO U-TURN" SIGN PER MUTCD R3-4 ON SAME POST AS STOP SIGN. NO U-TURN SIGN TO FACE EAST.
- CONTRACTOR TO FURNISH AND INSTALL ONE FOOT WIDE, WHITE BH-5 THERMOPLASTIC STOP BAR BY LANE WIDTH SHOWN PER OREGON STANDARD DRAWINGS TM503 AND TM530.

CURB RETURN DATA															
DESC.	C1	C2	C3	C4	C5	C6	C7	C8	C9	C10	C11	C12	C13	C14	C15
RADIUS	10.00'	10.00'	15.00	15.00'	20.00'	15.00'	15.00'	20.00'	15.00'	15.00'	20.00'	15.00'	15.00'	20.00'	15.00'
LENGTH	15.69'	15.71'	11.81'	8.91'	38.05'	11.00'	8.91'	58.72'	11.63'	11.93'	59.13'	8.91'	58.89'	11.63'	
DELTA	89.8956°	90.0000°	45.1074°	34.0477°	166.3081°	42.0246°	34.0477°	168.2273°	44.4153°	45.5730°	169.3850°	34.0477°	34.0477°	168.6988°	44.4153°
PC/PCC/PRC STA	CL STA 6+77.92 (1ST STR)	CL STA 6+21.94 (1ST STR)	CL STA 6+08.99 (1ST STR)	CL STA 3+98.27 (SMITH STR)	CL STA 4+06.67 (SMITH STR)	CL STA 6+95.52 (2ND STR)	CL STA 3+98.54 (SMITH STR)	CL STA 4+06.93 (SMITH STR)	CL STA 6+04.13 (2ND STR)	CL STA 5+01.46 (SMITH STR)	CL STA 4+93.07 (SMITH STR)	CL STA 6+96.15 (2ND STREET)	CL STA 5+01.73 (SMITH STR)	CL STA 4+93.35 (SMITH STR)	CL STA 6+03.87 (2ND STR)
PC/PCC/PRC OFFSET	13.89' L	13.77' L	18.04' L	18.00' R	15.43' R	17.14' R	18.00' L	15.43' L	17.71' R	18.00' R	15.43' R	18.00' L	18.00' L	15.40' L	17.71' L
PC/PCC/PRC TC ELEV	314.89	314.74	314.18	312.77	312.71	312.81	312.77	312.71	312.28	312.33	312.38	312.71	312.33	312.37	312.28
1/4 Δ TC ELEV	314.87	314.76	314.72	-	312.82	-	-	312.61	-	-	312.46	-	-	312.45	-
1/2 Δ TC ELEV	314.85	314.78	314.70	312.74	312.92	312.79	312.74	312.50	312.23	312.36	312.55	312.75	312.35	312.52	312.23
3/4 Δ TC ELEV	314.84	314.80	314.69	-	312.88	-	-	312.39	-	-	312.62	-	-	312.41	-
PT/PCC/PRC TC ELEV	314.82	314.82	314.73	312.71	312.81	312.81	312.71	312.28	312.17	312.38	312.71	312.79	312.37	312.28	312.17
PT/PCC/PRC STA	CL STA 1+15.16 (SMITH STR)	CL STA 1+15.27 (SMITH STR)	CL STA 6+19.55 (1ST STR)	CL STA 4+06.67 (SMITH STR)	CL STA 6+95.52 (2ND STR)	CL STA 7+05.56 (2ND STR)	CL STA 4+06.93 (SMITH STR)	CL STA 6+04.13 (2ND STR)	CL STA 5+93.64 (2ND STR)	CL STA 4+93.07 (SMITH)	CL STA 6+96.15 (2ND STR)	CL STA 7+06.86 (2ND STR)	CL STA 4+93.35 (SMITH STR)	CL STA 6+03.87 (2ND STR)	CL STA 5+93.37 (2ND STR)
PT/PCC/PRC OFFSET	18.00' R	18.00' L	13.76' L	15.43' R	17.14' R	21.00' R	15.43' L	17.71' R	22.00' R	15.43' R	18.00' L	22.50' L	15.40' L	17.71' L	22.00' L

TC NOTE:
TOP OF CURB ELEVATIONS IN TABLE ABOVE ASSUME SIX INCHES OF CURB EXPOSURE REGARDLESS OF BEING IN ADA RAMP. FOR EXACT ELEVATIONS SEE ADA RAMP DETAILS INCLUDED IN THIS PLAN SET.

GENERAL NOTE

CONTRACTOR TO POTHOLE EXISTING UTILITIES WHERE THERE IS UTILITY CROSSING AND NOTIFY THE ENGINEER IF THERE IS A CONFLICT.

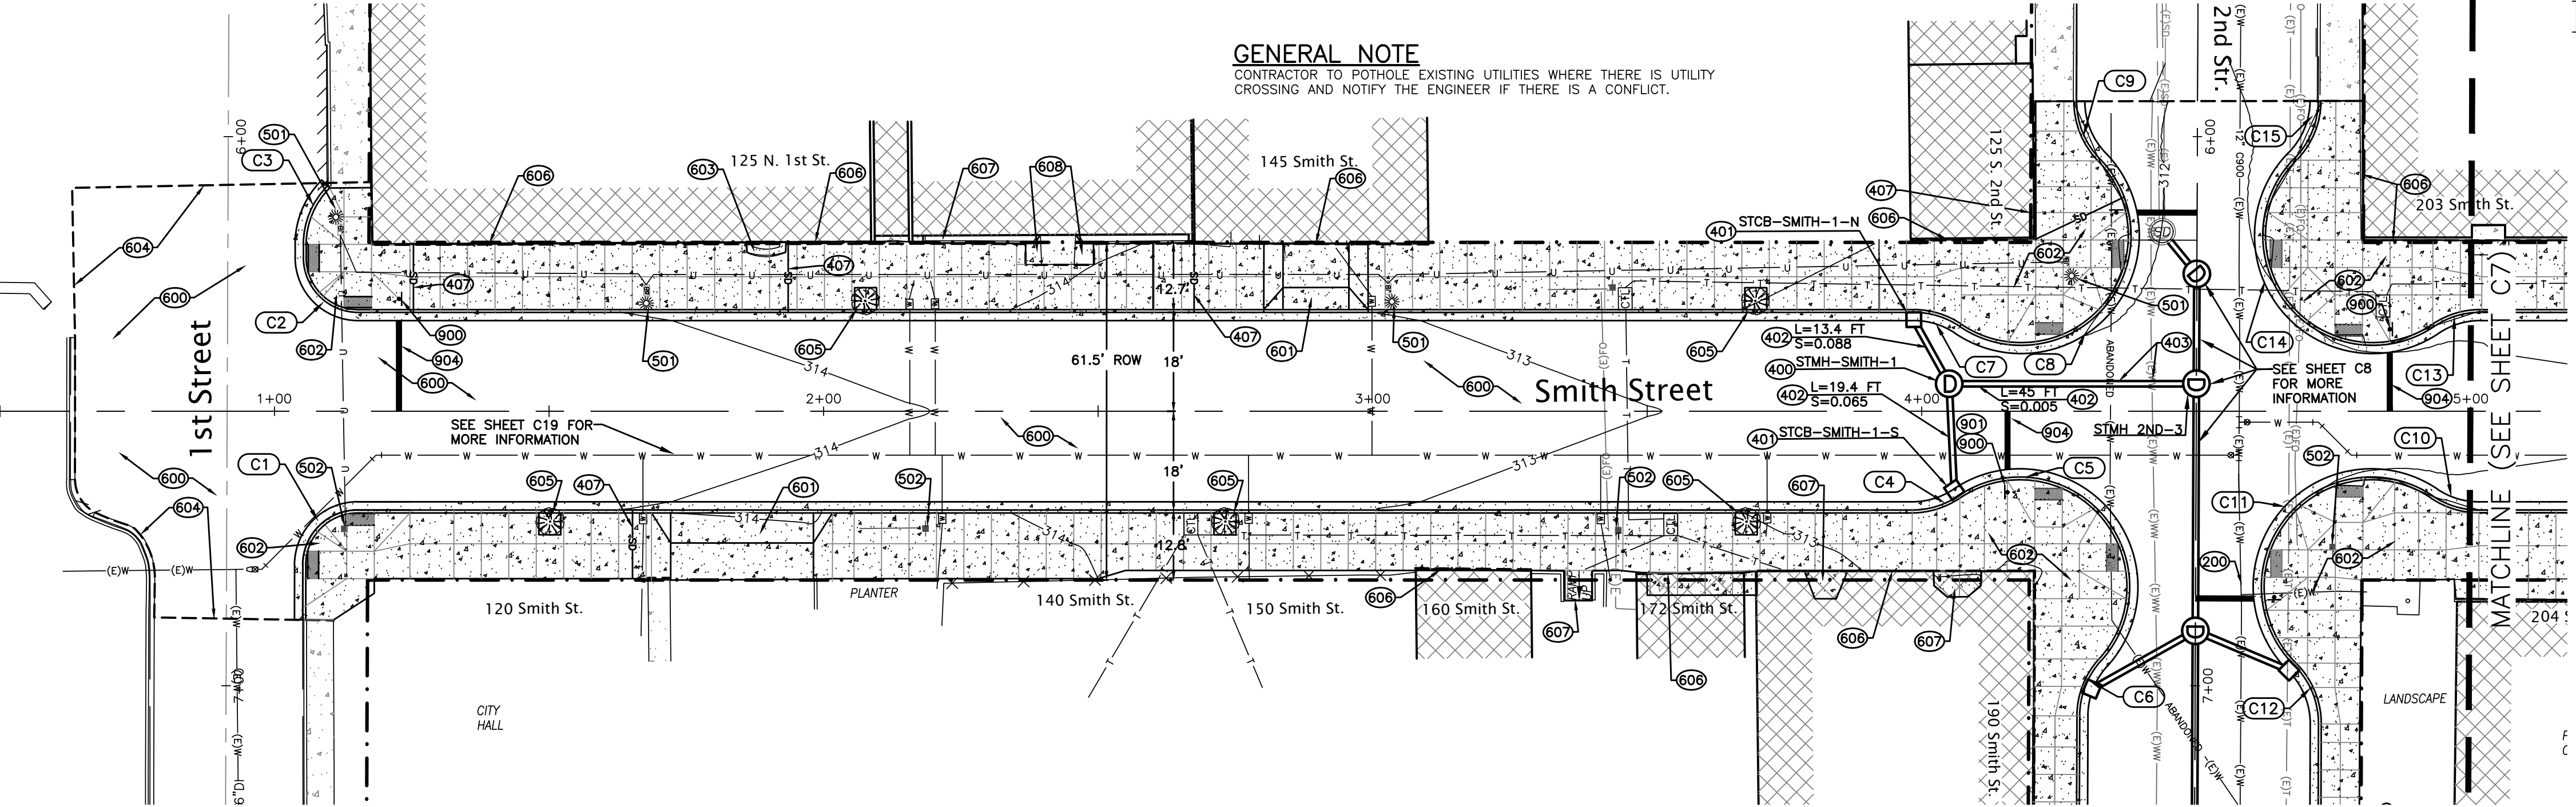

ABBREVIATIONS
GL: GUTTER LINE
TC: TOP OF CURB
C: CONCRETE
FG: FINISHED GRADE
CL: CENTERLINE
STA: STATION
STR: STREET
PC: POINT OF CURVATURE
PT: POINT OF TANGENCY
PRC: POINT OF REVERSE CURVE
PCC: POINT OF COMPOUND CURVE
L: LEFT
R: RIGHT
ELEV: ELEVATION

GRAPHIC SCALE
20 0 10 20 40
(IN FEET)

Branch ENGINEERING
Since 1977
civil • transportation
structural • geotechnical
SURVEYING

310 5th Street
Springfield, OR 97477
p: 541.746.0637
www.BranchEngineering.com
Springfield OR | Albany OR

REGISTERED PROFESSIONAL
ENGINEER
#53,800
DIGITALLY SIGNED
OREGON
JULY 9, 2001
GREGORY A. MOWER
EXPIRES: DECEMBER 31, 2020

project title:
CITY OF HARRISBURG
Smith, Macy, & 2nd Street Rehabilitation
Smith - 1st To 3rd, Macy - 2nd To 3rd, 2nd - Smith To Macy
HARRISBURG, OREGON

revisions:
date: JANUARY 28, 2020
drawn by: GAM
designer: GAM
project no: 17-009F

Smith Street
Plan & Profile
Sta 0+00 to 5+00


sheet:
C6

- 400- CONSTRUCT G-2 CONCRETE CATCH BASIN PER ODOT STD DWG R0364. SEE PROFILE FOR RIM AND PIPE ELEVATIONS. CONSTRUCT OVER EXISTING PIPE.
- 401- CONSTRUCTOR TO POT HOLE EXISTING UTILITY AND CONFIRM LOCATION, MATERIAL, SIZE AND DEPTH. NOTIFY ENGINEER IF DISCREPANCIES ARE DISCOVERED.
- 402- EXISTING STORM LINE TO REMAIN IN SERVICE.
- 403- ABANDON EXISTING 12" STORM LINE IN PLACE.
- 404- EXISTING STORM MANHOLE LID TO BE ADJUST TO PROPOSED FINISHED GRADE.
- 405- FURNISH AND INSTALL 3" PVC SCH40 ROOF DRAIN TO WEEP HOLE. CONNECT TO EXISTING ROOF DRAINS USING APPROPRIATE COUPLINGS AND FITTINGS.
- 501- PROPOSED STREET LIGHTING PER SHEET C22 AND PACIFIC POWER AND LIGHTING (PP&L) COORDINATE WITH PP&L. CONTACT ELKE VATH AT 541-967-6160.
- 502- REPLACE EXISTING POLE MOUNTED STREET LIGHT ON EXISTING POLE WITH NEW POLE MOUNTED STREET LIGHT ON EXISTING POLE TO REMAIN. POLE MOUNTED STREET LIGHT TO MATCH GROUND MOUNTED STREET LIGHT. CONTACT ELKE VATH AT 541-967-6160.
- 600- CONSTRUCT PAVEMENT SECTION, CURB & GUTTER AND SIDEWALK PER TYPICAL SECTIONS, SHEET C2.
- 601- CONSTRUCT CONCRETE DRIVEWAY PER OREGON STANDARD DWG RD745 OPTION K. PLACE 6" MINIMUM THICKNESS OF 1"-0" CRUSHED QUARRY ROCK.
- 602- CONSTRUCT CURB RETURN WITH ADA RAMPS. PLACE 4" MINIMUM THICKNESS OF 1"-0" CRUSHED QUARRY ROCK. SEE SHEET C14 FOR CURB RETURN DETAILS WITH DIMENSIONS AND SPOT ELEVATIONS.
- 603- SEAL PAVEMENT JOINT. TACK COAT EXISTING PAVEMENT EDGES, THE MATCHLINE TO EXISTING PAVING SHALL COMPLY WITH ODOT STANDARD DRAWING R0302.
- 604- FURNISH AND INSTALL 4"x4" TREE WELL AND 2.5" CALIPER TREE PER TREE WELL DETAIL 2, SHEET C26. INSTALL TREE WELL GRATE AND FRAME PER MANUFACTURER'S RECOMMENDATIONS.
- 605- PLACE EXPANSION JOINT ALONG EXISTING BUILDINGS OR STRUCTURES THAT SIDEWALK WILL ABUT AGAINST. SEE DETAIL 3, SHEET C26.
- 606- CONSTRUCT CONCRETE RAMP TO EXISTING DOOR. 4" THICK CONCRETE.
- 607- CONTRACTOR TO REUSE FOUNDATION WELL GRATES.
- 608- CONTRACTOR TO MATCH EXISTING PAVEMENT SECTION WHEN RE-PAVING N ADA RAMPS.
- 900- CONTRACTOR TO INSTALL NEW 30"x30" ALUMINUM STOP SIGN PER MUTCD R1-1 AND STREET SIGNS ON 2"-12 GAUGE P.S.S.T. POST PER OREGON STANDARD DRAWINGS TM200, TM 223, TM681 AND TM687.
- 901- CONTRACTOR TO INSTALL NEW 15 MINUTE PARKING 6AM TO 9PM" SIGN PER MUTCD R7-108 ON 2"-12 GAUGE P.S.S.T. POST PER OREGON STANDARD DRAWINGS TM200, TM681 AND TM687.
- 902- CONTRACTOR TO INSTALL NEW 2" HOUR PARKING 9AM TO 6PM" SIGN PER MUTCD R7-108 ON 2"-12 GAUGE P.S.S.T. POST PER OREGON STANDARD DRAWINGS TM200, TM681 AND TM687.
- 903- CONTRACTOR TO INSTALL NEW 18"x15" "DOWNTOWN PARKING" SIGN WITH LEFT ARROW PER MUTCD D4-1 ON 2"-12 GAUGE P.S.S.T. POST PER OREGON STANDARD DRAWINGS TM200, TM681 AND TM687.
- 904- CONTRACTOR TO FURNISH AND INSTALL ONE FOOT WIDE, WHITE PH-5 THERMOPLASTIC STOP BAR BY LANE WIDTH SHOWN PER OREGON STANDARD DRAWINGS TM503 AND TM530.

ABBREVIATIONS

GL:	GUTTER LINE
TC:	TOP OF CURB
C:	CONCRETE
FG:	FINISHED GRADE
CL:	CENTERLINE
STA:	STATION
STR:	STREET
PC:	POINT OF CURVATURE
PT:	POINT OF TANGENCY
PRC:	POINT OF REVERSE CURVE
PCC:	POINT OF COMPOUND CURVE
L:	LEFT
R:	RIGHT
ELEV:	ELEVATION

ALTERNATE #1

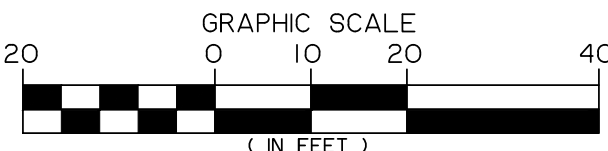

SCALE: HORZ: 1" = 20'
VERT: 1" = 2'



Branch
ENGINEERING Inc.

Since 1977

civil • transportation
structural • geotechnical
SURVEYING

310 5th Street
Springfield, OR 97477
p. 541.746.0637

www.BranchEngineering.com
Springfield OR | Albany OR



project title:

CITY OF HARRISBURG
Smith, Macy, & 2nd Street Rehabilitation

Smith - 1st To 3rd, Macy - 2nd To 3rd, 2nd - Smith To Macy
HARRISBURG, OREGON

revisions:

date: JANUARY 28, 2020
drawn by: GAM
designer: GAM
project no: 17-009F



Smith Street
Plan & Profile
STA 5+00 to 8+50

sheet:

C7

CONSTRUCTION NOTES

- 200 → ADJUST EXISTING WATER VALVE BOXES TO PROPOSED FINISHED GRADE.
- 201 → ADJUST EXISTING WATER METER BOXES TO PROPOSED FINISHED GRADE.
- 400 → CONSTRUCT 48" CONCRETE STORM MANHOLE PER ODOT STD DWG RD335. SEE PROFILE FOR RIM AND PIPE ELEVATIONS.
- 401 → CONSTRUCT G-2 CONCRETE CATCH BASIN PER ODOT STD DWG RD364. SEE PROFILE FOR RIM AND PIPE ELEVATIONS.
- 403 → CONSTRUCT AREA DRAINAGE BASIN PER ODOT STANDARD DRAWING RD374.
- 404 → FURNISH AND INSTALL 12" PVC D3034 STORM LINE. CLASS B BACKFILL. SEE ODOT TYPICAL TRENCH DETAIL RD300.
- 405 → CONTRACTOR TO POT HOLE EXISTING UTILITY AND CONFIRM LOCATION, MATERIAL, SIZE AND DEPTH. NOTIFY ENGINEER IF DISCREPANCIES ARE DISCOVERED.
- 406 → EXISTING STORM LINE TO REMAIN IN SERVICE.
- 407 → EXISTING MANHOLE LID TO BE ADJUST TO PROPOSED FINISHED GRADE.
- 408 → FURNISH AND INSTALL 3" PVC SCH40 ROOF DRAIN TO WEEP HOLE. CONNECT TO EXISTING ROOF DRAINS USING APPROPRIATE COUPLINGS AND FITTINGS.
- 409 → CORE DRILL EXISTING MANHOLE TO ACCEPT NEW 12" STORM PIPE AND GROUT WITH NON-SHRINK GROUT.
- 501 → PROPOSED STREET LIGHTING PER SHEET C23 AND PACIFIC POWER AND LIGHTING (PP&L) COORDINATE WITH PP&L. CONTACT ELKE VATH 541-967-6160.
- 504 → ADJUST TELEPHONE MANHOLE RIM TO FINISHED GRADE.
- 600 → CONSTRUCT PAVEMENT SECTION, CURB & GUTTER AND SIDEWALK PER TYPICAL SECTIONS, SHEET C2.
- 601 → CONSTRUCT CONCRETE DRIVEWAY PER OREGON STANDARD DWG RD750 OPTION M. PLACE 6" MINIMUM THICKNESS OF 1"-0" CRUSHED QUARRY ROCK.
- 602 → CONSTRUCT CURB RETURN WITH ADA RAMPS. PLACE 4" MINIMUM THICKNESS OF 1"-0" CRUSHED QUARRY ROCK. SEE SHEET C12 & C13 FOR CURB RETURN DETAILS WITH DIMENSIONS AND SPOT ELEVATIONS.
- 603 → CONSTRUCT 6" THICK CONCRETE SLAB TO MATCH EXISTING CONCRETE SURFACE AND BACK OF NEW DRIVEWAY. SEE DETAIL 4, SHEET C26.
- 604 → CONSTRUCT 6" HIGH, 10" WIDE AND 3' LONG CONCRETE STEP FOR ENTRANCE TO EXISTING BUILDING. SEE DETAIL 1, SHEET C26.
- 605 → SEAL PAVEMENT JOINT. TACK COAT EXISTING PAVEMENT EDGES. THE MATCHLINE TO EXISTING PAVING SHALL COMPLY WITH ODOT STANDARD DRAWING RD302.
- 606 → FURNISH AND INSTALL 4'X4' TREE WELL AND TREE PER TREE WELL DETAIL, SHEET C2. INSTALL TREE WELL GRATE AND FRAME PER MANUFACTURER'S RECOMMENDATIONS. INSTALL 2.5" CALIPER TREE PER THE TREE WELL DETAIL 2, SHEET C26.
- 607 → PLACE EXPANSION JOINT ALONG EXISTING BUILDINGS OR STRUCTURES THAT SIDEWALK WILL ABUT AGAINST. SEE DETAIL 3, SHEET C26.
- 608 → CONSTRUCT CONCRETE RAMP TO EXISTING DOOR. 4" THICK CONCRETE.
- 900 → CONTRACTOR TO INSTALL NEW 30"X30" ALUMINUM STOP SIGN PER MUTCD R1-1 AND STREET SIGNS ON 2"-12 GAUGE P.S.S.T. POST PER OREGON STANDARD DRAWINGS TM200, TM 223, TM681 AND TM687.
- 904 → CONTRACTOR TO FURNISH AND INSTALL ONE FOOT WIDE, WHITE BH-5 THERMOPLASTIC STOP BAR BY LANE WIDTH SHOWN PER OREGON STANDARD DRAWINGS TM503 AND TM530.

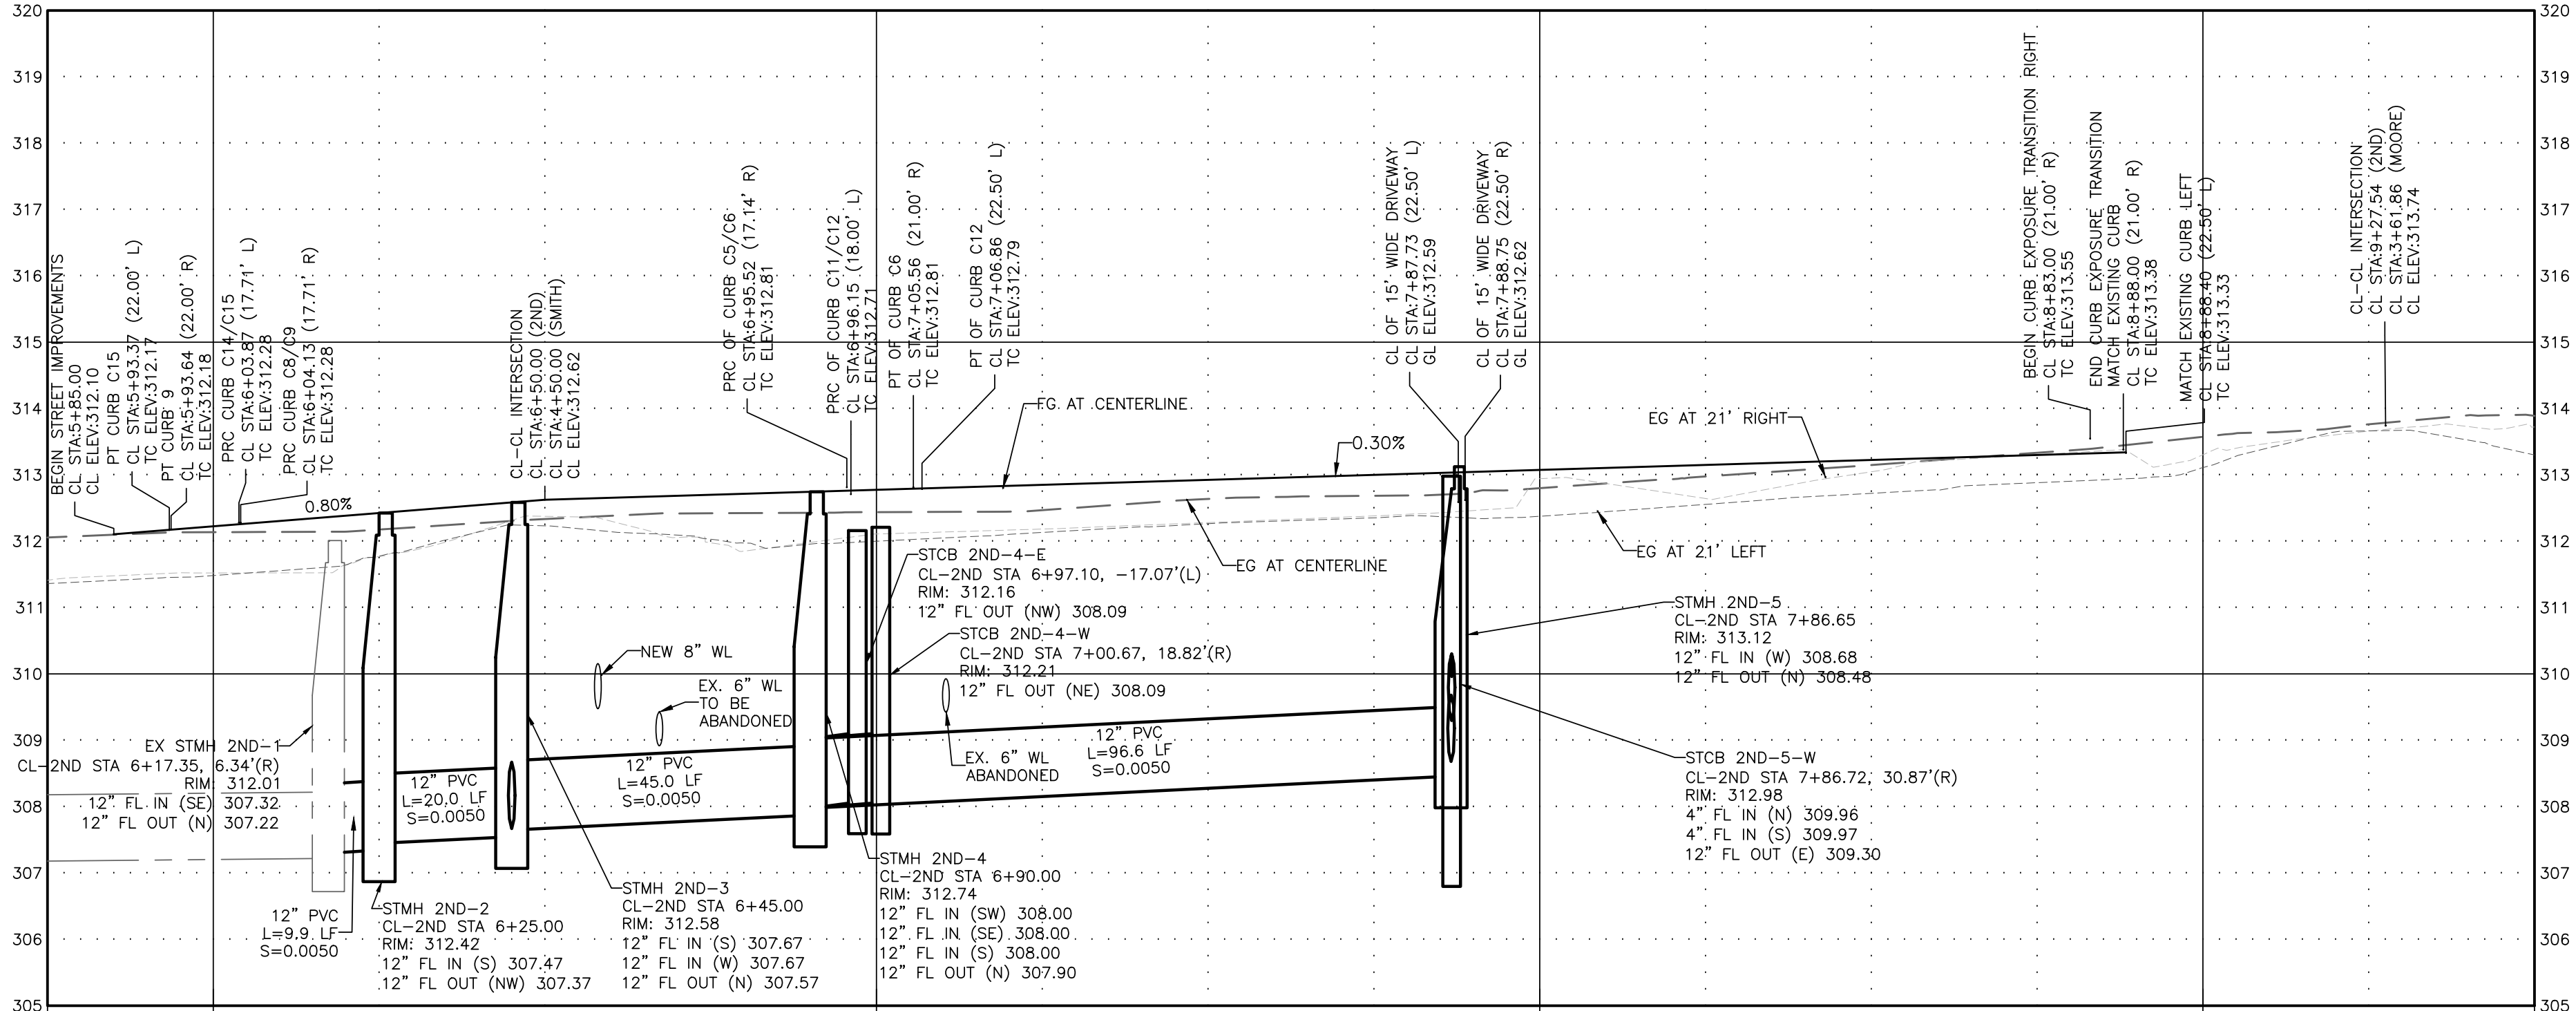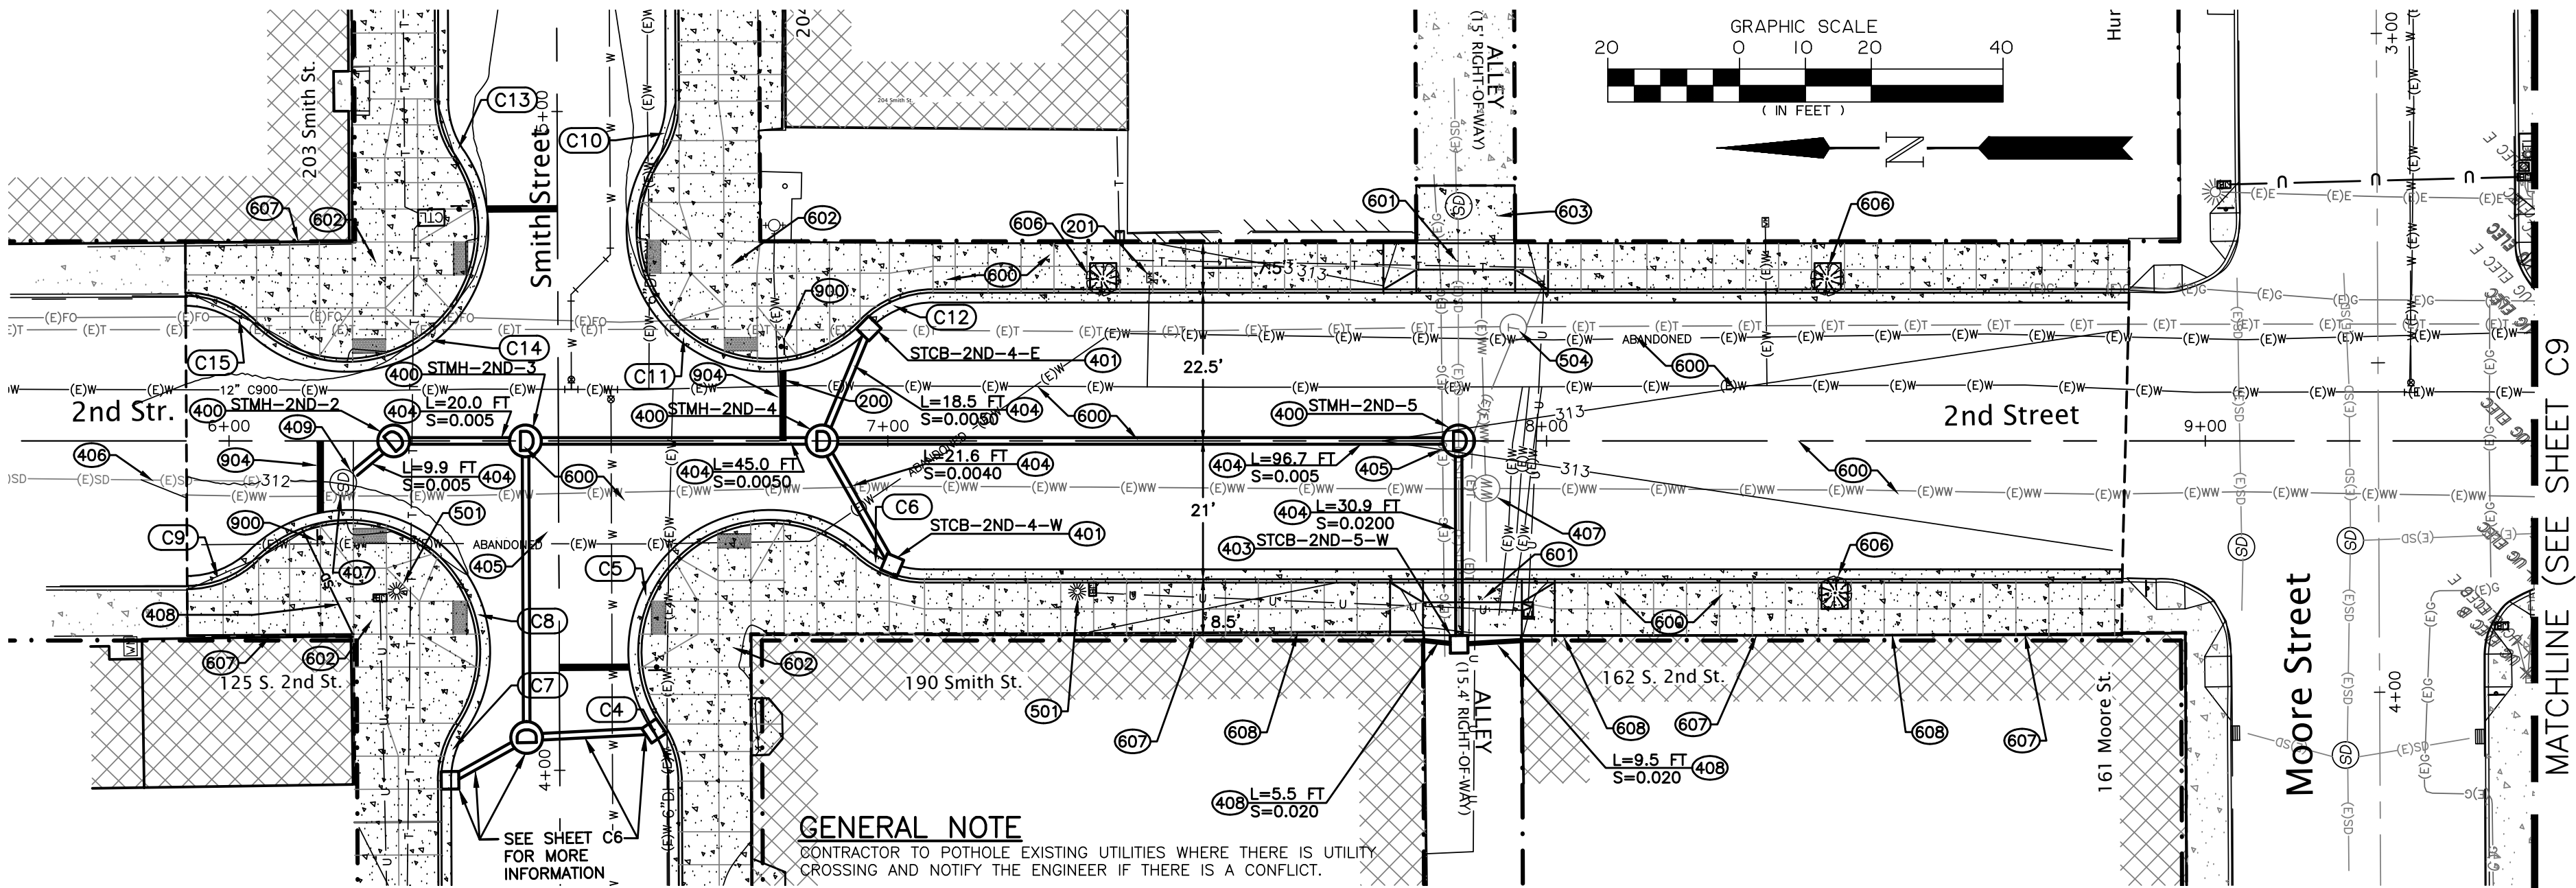

2ND STREET PROFILE
SCALE: HORIZ: 1" = 20'
VERT: 1" = 2'

project title:

CITY OF HARRISBURG
Smith, Macy, & 2nd Street Rehabilitation
Smith - 1st To 3rd, Macy - 2nd To 3rd, 2nd - Smith To Macy
HARRISBURG, OREGON

revisions:

date: JANUARY 28, 2020
drawn by: GAM
designer: GAM
project no: 17-009F

2nd Street
Plan & Profile
STA 5+75 TO 9+50

sheet:

C8

CONSTRUCTION NOTES

- 200—ADJUST EXISTING WATER VALVE BOXES TO PROPOSED FINISHED GRADE.
- 201—ADJUST EXISTING WATER METER TO PROPOSED FINISHED GRADE.
- 300—ADJUST EXISTING WASTEWATER MANHOLE LID TO PROPOSED FINISHED GRADE.
- 400—CORE DRILL EXISTING STORM MANHOLE AND CONNECT NEW STORM LINE USING NON-SHRINK GROUT.
- 401—CONSTRUCT 48" CONCRETE STORM MANHOLE PER ODOT STD DWG RD335. SEE PROFILE FOR RIM AND PIPE ELEVATIONS.
- 402—EXISTING STORM MANHOLE LID TO BE ADJUSTED TO PROPOSED FINISHED GRADE.
- 403—CONSTRUCT G-2 CONCRETE CATCH BASIN PER ODOT STD DWG RD364. SEE PROFILE FOR RIM AND PIPE ELEVATIONS.
- 404—CONSTRUCT G-2 CONCRETE CATCH BASIN OVER EXISTING STORM LINE PER ODOT STD DWG RD364. SEE PROFILE FOR RIM AND PIPE ELEVATIONS.
- 405—ADJUST EXISTING CATCH BASIN RIM TO FINISHED GRADE.
- 406—FURNISH AND INSTALL 12" PVC D3034 STORM LINE. LENGTH AND SLOPE PER PLAN. CLASS B BACKFILL. SEE ODOT TYPICAL TRENCH DETAIL RD300.
- 407—FURNISH AND INSTALL 8" PVC C-900 STORM LINE. LENGTH AND SLOPE PER PLAN. CLASS B BACKFILL. SEE ODOT TYPICAL TRENCH DETAIL RD300.
- 408—FURNISH AND INSTALL 3" PVC SCH40 ROOF DRAIN TO WEEP HOLE. CONNECT TO EXISTING ROOF DRAINS USING APPROPRIATE COUPLINGS AND FITTINGS.
- 409—EXISTING STORM LINE TO REMAIN IN SERVICE.

- 500—CONTRACTOR TO POT HOLE EXISTING UTILITY AND CONFIRM LOCATION, MATERIAL, SIZE AND DEPTH. NOTIFY ENGINEER IF DISCREPANCIES ARE DISCOVERED PRIOR TO ORDERING CATCH BASINS AND MANHOLES.
- 501—PROPOSED STREET LIGHTING PER SHEET C23 AND PACIFIC POWER AND LIGHTING (PP&L) COORDINATE WITH PP&L. CONTACT ELKE VATH 541-967-6160.

- 600—CONSTRUCT PAVEMENT SECTION, CURB & GUTTER AND SIDEWALK PER TYPICAL SECTIONS, SHEET C2.
- 601—CONSTRUCT CONCRETE DRIVEWAY PER OREGON STANDARD DWG RD745 OPTION K. PLACE 6" MINIMUM THICKNESS OF 1"-0" CRUSHED QUARRY ROCK.
- 602—CONSTRUCT CONCRETE DRIVEWAY PER OREGON STANDARD DWG RD745 OPTION L. PLACE 6" MINIMUM THICKNESS OF 1"-0" CRUSHED QUARRY ROCK.
- 603—CONSTRUCT CONCRETE DRIVEWAY PER OREGON STANDARD DWG RD750 OPTION N. PLACE 6" MINIMUM THICKNESS OF 1"-0" CRUSHED QUARRY ROCK.
- 604—CONSTRUCT CURB RETURN WITH ADA RAMP. PLACE 6" MINIMUM THICKNESS OF 1"-0" CRUSHED QUARRY ROCK. SEE SHEET C15 FOR CURB RETURN DETAILS WITH DIMENSIONS AND SPOT ELEVATIONS.
- 605—SEAL PAVEMENT JOINT. TACK COAT EXISTING PAVEMENT EDGES. THE MATCHLINE TO EXISTING PAVING SHALL COMPLY WITH ODOT STANDARD DRAWING RD302.
- 606—FURNISH AND INSTALL 4'X4' TREE WELL AND 2.5" CALIPER TREE PER TREE WELL DETAIL 2, SHEET C26. INSTALL TREE WELL GRATE AND FRAME PER MANUFACTURER'S RECOMMENDATIONS.
- 607—PLACE EXPANSION JOINT ALONG EXISTING BUILDINGS THAT SIDEWALK WILL ABUT AGAINST. SEE DETAIL 3, SHEET C26.
- 608—CONSTRUCT CONCRETE RAMP TO EXISTING DOOR. 4" THICK CONCRETE.
- 609—CONTRACTOR TO EXTEND SIDEWALK TO EXISTING CONCRETE STEP.
- 610—CONTRACTOR TO RECONSTRUCT EXISTING CONCRETE PAVERS TO MATCH NEW SIDEWALK. COORDINATE WITH PROPERTY OWNER.

GENERAL NOTE

CONTRACTOR TO POTHOLE EXISTING UTILITIES WHERE THERE IS UTILITY CROSSING AND NOTIFY THE ENGINEER IF THERE IS A CONFLICT.

CURB RETURN DATA

DESC.	C20	C21	C22	C23	C24
RADIUS	15.00'	10.00'	10.00'	10.00'	10.00'
LENGTH	4.75'	15.74'	15.67'	15.67'	15.74'
DELTA	18.1597°	90.1890°	89.8110°	89.8110°	90.1890°
PC/PCC/PRC STA	CL STA 9+71.36 (2ND STR)	CL STA 12+32.23 (2ND STR)	CL STA 11+74.26 (2ND STR)	CL STA 12+30.05 (2ND STR)	CL STA 11+74.05 (2ND STR)
PC/PCC/PRC OFFSET	21.25' L	22.00' R	22.00' R	22.00' L	22.00' L
PC/PCC/PRC TC ELEV	313.70	314.67	314.79	314.71	314.80
1/4 Δ TC ELEV	—	314.63	314.72	314.69	314.75
1/2 Δ TC ELEV	—	314.60	314.65	314.66	314.71
3/4 Δ TC ELEV	—	314.57	314.58	314.64	314.67
PT/PCC/PRC TC ELEV	314.05	314.54	314.50	314.62	314.63
PT/PCC/PRC STA	CL STA 9+76.04 (2ND STR)	CL STA 4+17.91 (MACY STR)	CL STA 4+18.09 (MACY STR)	CL STA 4+81.91 (MACY STR)	CL STA 4+82.09 (MACY STR)
PT/PCC/PRC OFFSET	22.00' L	18.00' R	18.00' L	18.00' R	18.00' L

TC NOTE:
TOP OF CURB ELEVATIONS IN TABLE ABOVE ASSUME SIX INCHES OF CURB EXPOSURE REGARDLESS OF BEING IN ADA RAMP. FOR EXACT ELEVATIONS SEE ADA RAMP DETAILS INCLUDED IN THIS PLAN SET.

ABBREVIATIONS
GL: GUTTER LINE
TC: TOP OF CURB
C: CONCRETE
FG: FINISHED GRADE
CL: CENTERLINE
STA: STATION
STR: STREET
PC: POINT OF CURVATURE
PT: POINT OF TANGENCY
PRC: POINT OF REVERSE CURVE
PCC: POINT OF COMPOUND CURVE
L: LEFT
R: RIGHT
ELEV: ELEVATION

Branch ENGINEERING INC
Since 1977

civil • transportation
structural • geotechnical
SURVEYING

310 5th Street
Springfield, OR 97477
p: 541.746.0637

www.BranchEngineering.com
Springfield OR | Albany OR

REGISTERED PROFESSIONAL
ENGINEER
#53,800
DIGITALLY SIGNED
OREGON
JULY 9, 2001
GREGORY A. MOWER

EXPIRES: DECEMBER 31, 2020

project title:

CITY OF HARRISBURG
Smith, Macy, & 2nd Street Rehabilitation
Smith - 1st To 3rd, Macy - 2nd To 3rd, 2nd - Smith To Macy
HARRISBURG, OREGON


revisions:


date: JANUARY 28, 2020
drawn by: GAM
designer: GAM
project no: 17-009F

2nd Street
Plan & Profile
STA 9+50 to 12+75

sheet:



C9

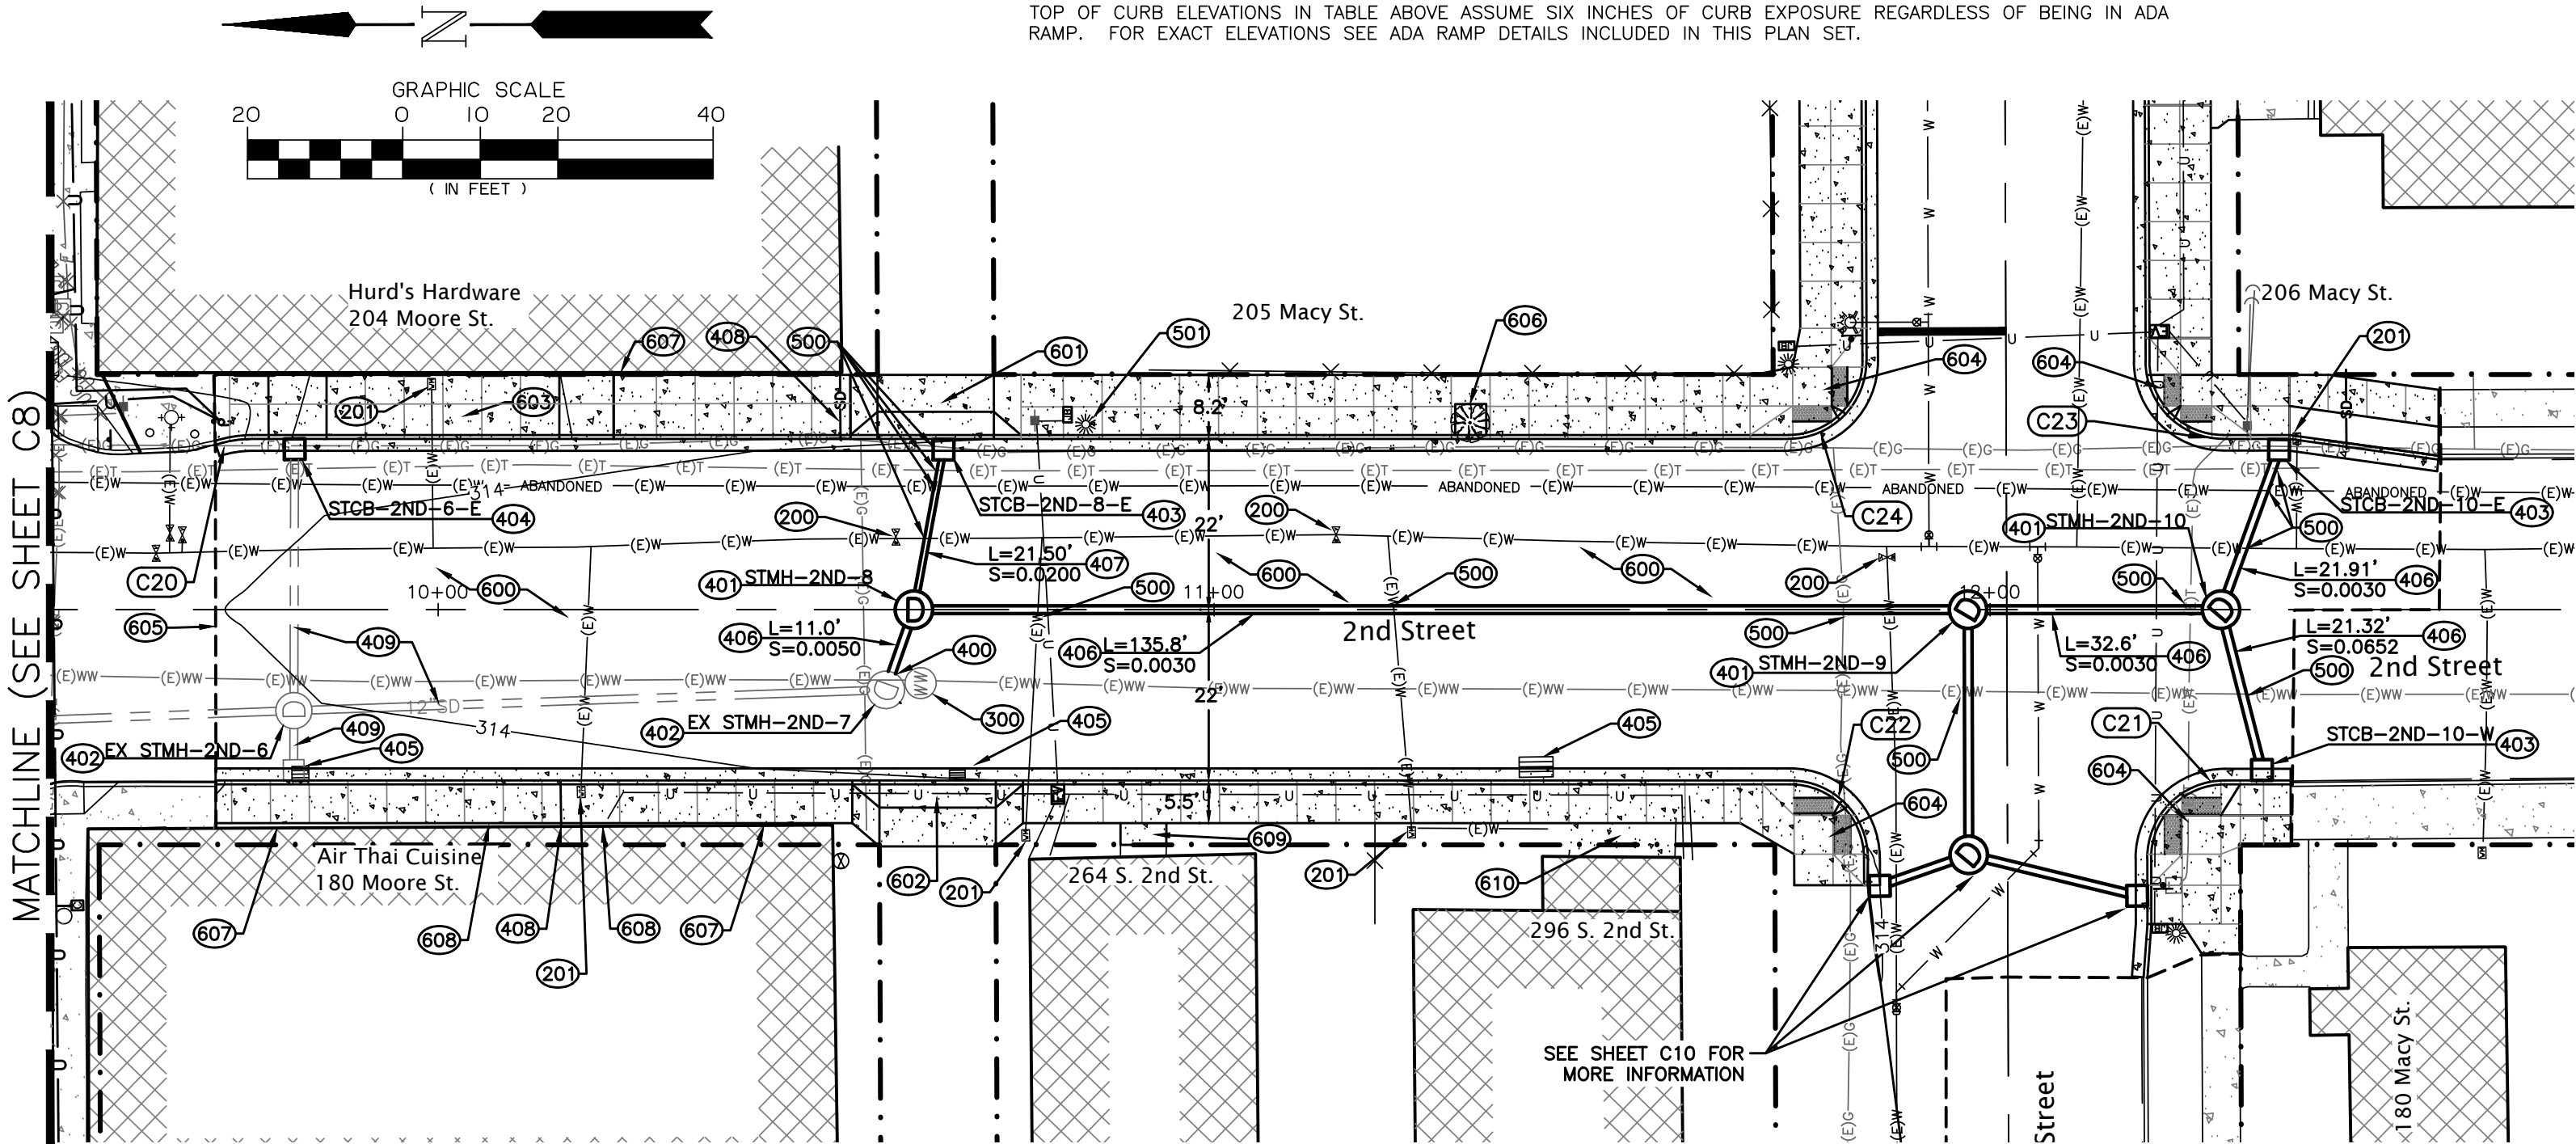

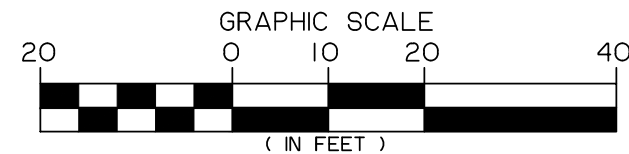

GENERAL NOTE

CONTRACTOR TO POTHOLE EXISTING UTILITIES WHERE THERE IS UTILITY CROSSING AND NOTIFY THE ENGINEER IF THERE IS A CONFLICT.

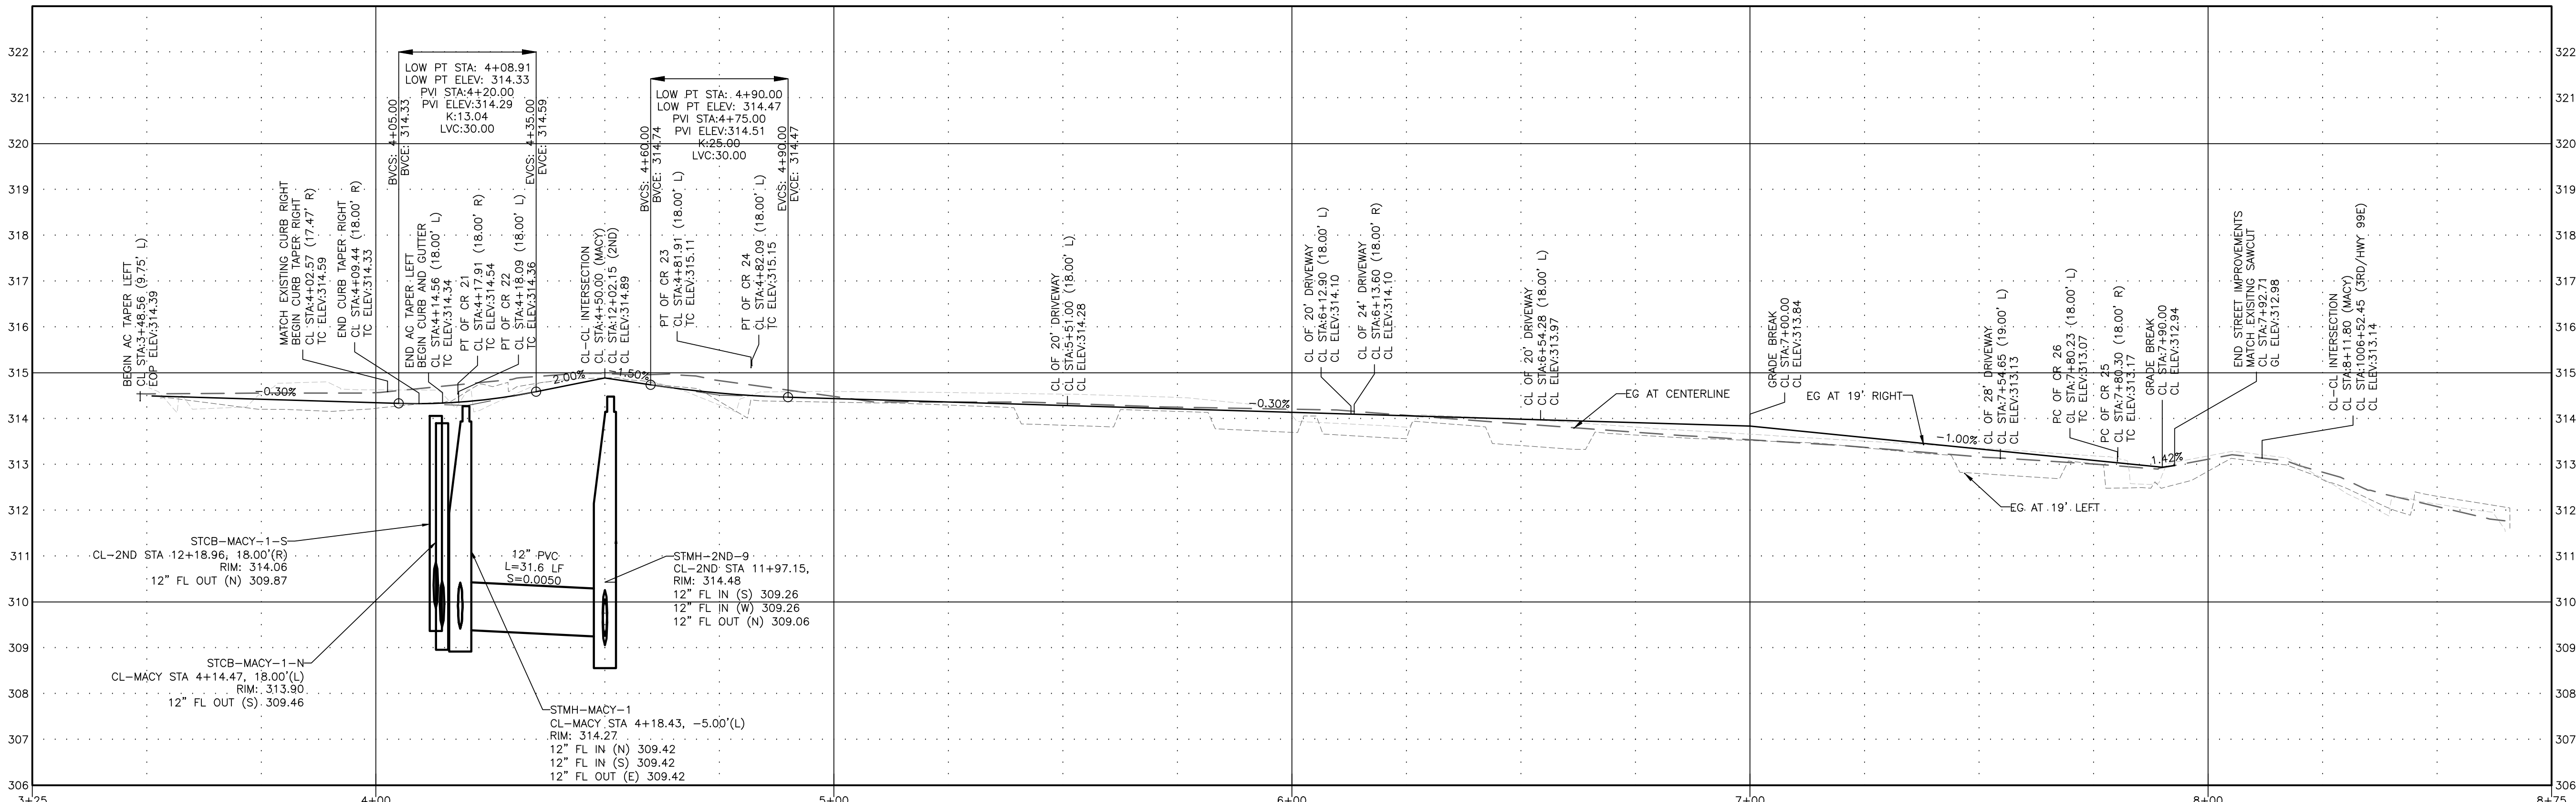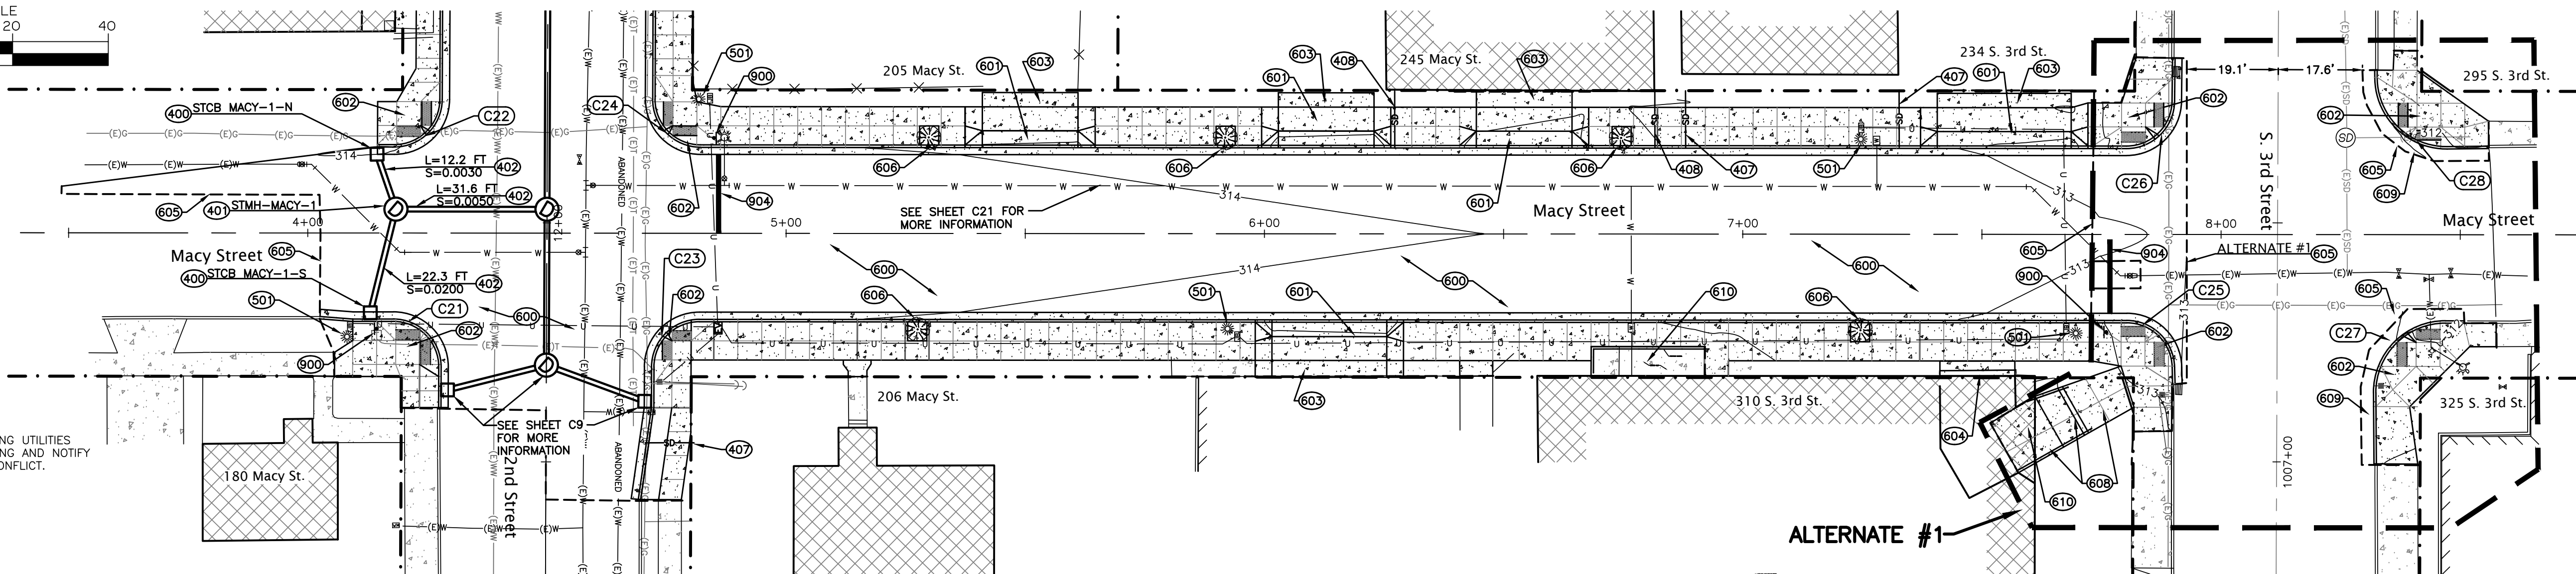

MACY STREET PROFILE

SCALE: HORIZ: 1" = 20'
VERT: 1" = 2'

CURB RETURN DATA				
DESC.	C25	C26	C27	C28
RADIUS	10.00'	10.00'	15.00'	23.68'
LENGTH	15.52'	15.67'	23.71'	15.00'
DELTA	88.9160°	89.4276°	90.5570°	90.4665°
PC/PCC/PRC STA	CL STA 7+80.30 (MACY STR)	CL STA 7+80.23 (MACY STR)	CL STA 1006+85.50 (3RD STR)	CL STA 1006+19.48 (3RD STR)
PC/PCC/PRC OFFSET	18.00' R	18.00' L	20.20' L	20.20' L
PC/PCC/PRC TC ELEV	313.17	313.07	312.82	312.66
1/4 Δ TC ELEV	313.15	313.00	312.59	312.57
1/2 Δ TC ELEV	313.14	312.93	312.49	312.48
3/4 Δ TC ELEV	313.10	312.86	312.32	312.39
PT/PCC/PRC TC ELEV	313.05	312.79	312.21	312.32
PT/PCC/PRC STA	CL STA 1006+80.33 (3RD STR)	CL STA 1006+24.62 (MACY STR)	CL STA 8+46.93 (MACY STR)	CL STA 8+47.25 (MACY STR)
PT/PCC/PRC OFFSET	21.41' R	21.63' R	18.00' R	18.00' L

TC NOTE:
TOP OF CURB ELEVATIONS IN TABLE ABOVE ASSUME SIX INCHES OF CURB EXPOSURE REGARDLESS OF BEING IN ADA RAMP. FOR EXACT ELEVATIONS SEE ADA RAMP DETAILS INCLUDED IN THIS PLAN SET.

ABBREVIATIONS

GL: GUTTER LINE
TC: TOP OF CURB
C: CONCRETE
FG: FINISHED GRADE
CL: CENTERLINE
STA: STATION
STR: STREET
PC: POINT OF CURVATURE
PT: POINT OF TANGENCY
PRC: POINT OF REVERSE CURVE
PCC: POINT OF COMPOUND CURVE
L: LEFT
R: RIGHT
ELEV: ELEVATION

CONSTRUCTION NOTES

- 400—CONSTRUCT G-2 CONCRETE CATCH BASIN PER ODOT STD DWG RD364. SEE PROFILE FOR RIM AND PIPE ELEVATIONS.
- 401—CONSTRUCT 48" CONCRETE STORM MANHOLE PER ODOT STD DWG RD335. SEE PROFILE FOR RIM AND PIPE ELEVATIONS.
- 402—FURNISH AND INSTALL 12" PVC D3034 STORM LINE. CLASS B BACKFILL. SEE ODOT TYPICAL TRENCH DETAIL RD300.
- 407—FURNISH AND INSTALL 3" PVC SCH40 ROOF DRAIN TO WEEP HOLE. CAP AT R.O.W.
- 408—FURNISH AND INSTALL 3" PVC SCH40 ROOF DRAIN TO WEEP HOLE. CONNECT TO EXISTING ROOF DRAINS USING APPROPRIATE COUPLINGS AND FITTINGS.
- 501—PROPOSED STREET LIGHTING PER SHEET C20 AND PACIFIC POWER AND LIGHTING (PP&L) COORDINATE WITH PP&L. CONTACT ELKE VATH 541-967-6160.
- 600—CONSTRUCT PAVEMENT SECTION, CURB & GUTTER AND SIDEWALK PER TYPICAL SECTIONS, SHEET C2.
- 601—CONSTRUCT CONCRETE DRIVEWAY PER OREGON STANDARD DWG RD745 OPTION K. PLACE 6" MINIMUM THICKNESS OF 1"-0" CRUSHED QUARRY ROCK.
- 602—CONSTRUCT CURB RETURN WITH ADA RAMPS. PLACE 6" MINIMUM THICKNESS OF 1"-0" CRUSHED QUARRY ROCK. SEE SHEET C15 & C16 FOR CURB RETURN DETAILS WITH DIMENSIONS AND SPOT ELEVATIONS.
- 603—CONSTRUCT 6" THICK CONCRETE SLAB TO MATCH EXISTING CONCRETE SURFACE AND BACK OF NEW DRIVEWAY. SEE DETAIL 4, SHEET C26.
- 604—CONSTRUCT 6" HIGH, 12" WIDE AND 16' LONG CONCRETE STEP FOR ENTRANCE TO EXISTING BUILDING. SEE DETAIL 1, SHEET C26.
- 605—SEAL PAVEMENT JOINT. TACK COAT EXISTING PAVEMENT EDGES. THE MATCHLINE TO EXISTING PAVING SHALL COMPLY WITH ODOT STANDARD DRAWING RD302.
- 606—FURNISH AND INSTALL 4'X4' TREE WELL AND 2.5" CALIPER TREE PER TREE WELL DETAIL 2, SHEET C26. INSTALL TREE WELL GRATE AND FRAME PER MANUFACTURER'S RECOMMENDATIONS.

- 608—CONSTRUCT 4" THICK CONCRETE SIDEWALK WITH STAIRS AND HANDRAILS PER SHEET C18.
- 609—CONTRACTOR TO MATCH EXISTING PAVEMENT SECTION WHEN RE-PAVING NEAR ADA RAMPS.
- 610—SAWCUT EXISTING RAMP AT LOCATION INDICATED AND NEW SIDEWALK TO MATCH EXISTING RAMP. CONTRACTOR TO INSTALL NEW HANDRAIL PER SHEET 18.
- 900—CONTRACTOR TO INSTALL NEW 30"X30" ALUMINUM STOP SIGN PER MUTCD R1-1 AND STREET SIGNS ON 2"-12 GAUGE P.S.S.T. POST PER OREGON STANDARD DRAWINGS TM200, TM 223, TM681 AND TM687.
- 904—CONTRACTOR TO FURNISH AND INSTALL ONE FOOT WIDE, WHITE BH-5 THERMOPLASTIC STOP BAR BY LANE WIDTH SHOWN PER OREGON STANDARD DRAWINGS TM503 AND TM530.

project title:

CITY OF HARRISBURG Smith, Macy, & 2nd Street Rehabilitation

Smith - 1st To 3rd, Macy - 2nd To 3rd, 2nd - Smith To Macy
HARRISBURG, OREGON

revisions:

date: JANUARY 28, 2020
drawn by: GAM
designer: GAM
project no: 17-009F


**Macy Street
Plan & Profile
STA 3+48 to 8+75**

sheet:

C10


Z:\2017\17-009F Harrisburg Smith Street\Drawing\17-009F Street Improvements.dwg / 2/8/2020 2:01 PM JLL/E

copyright © 2016 Branch Engineering, Inc.

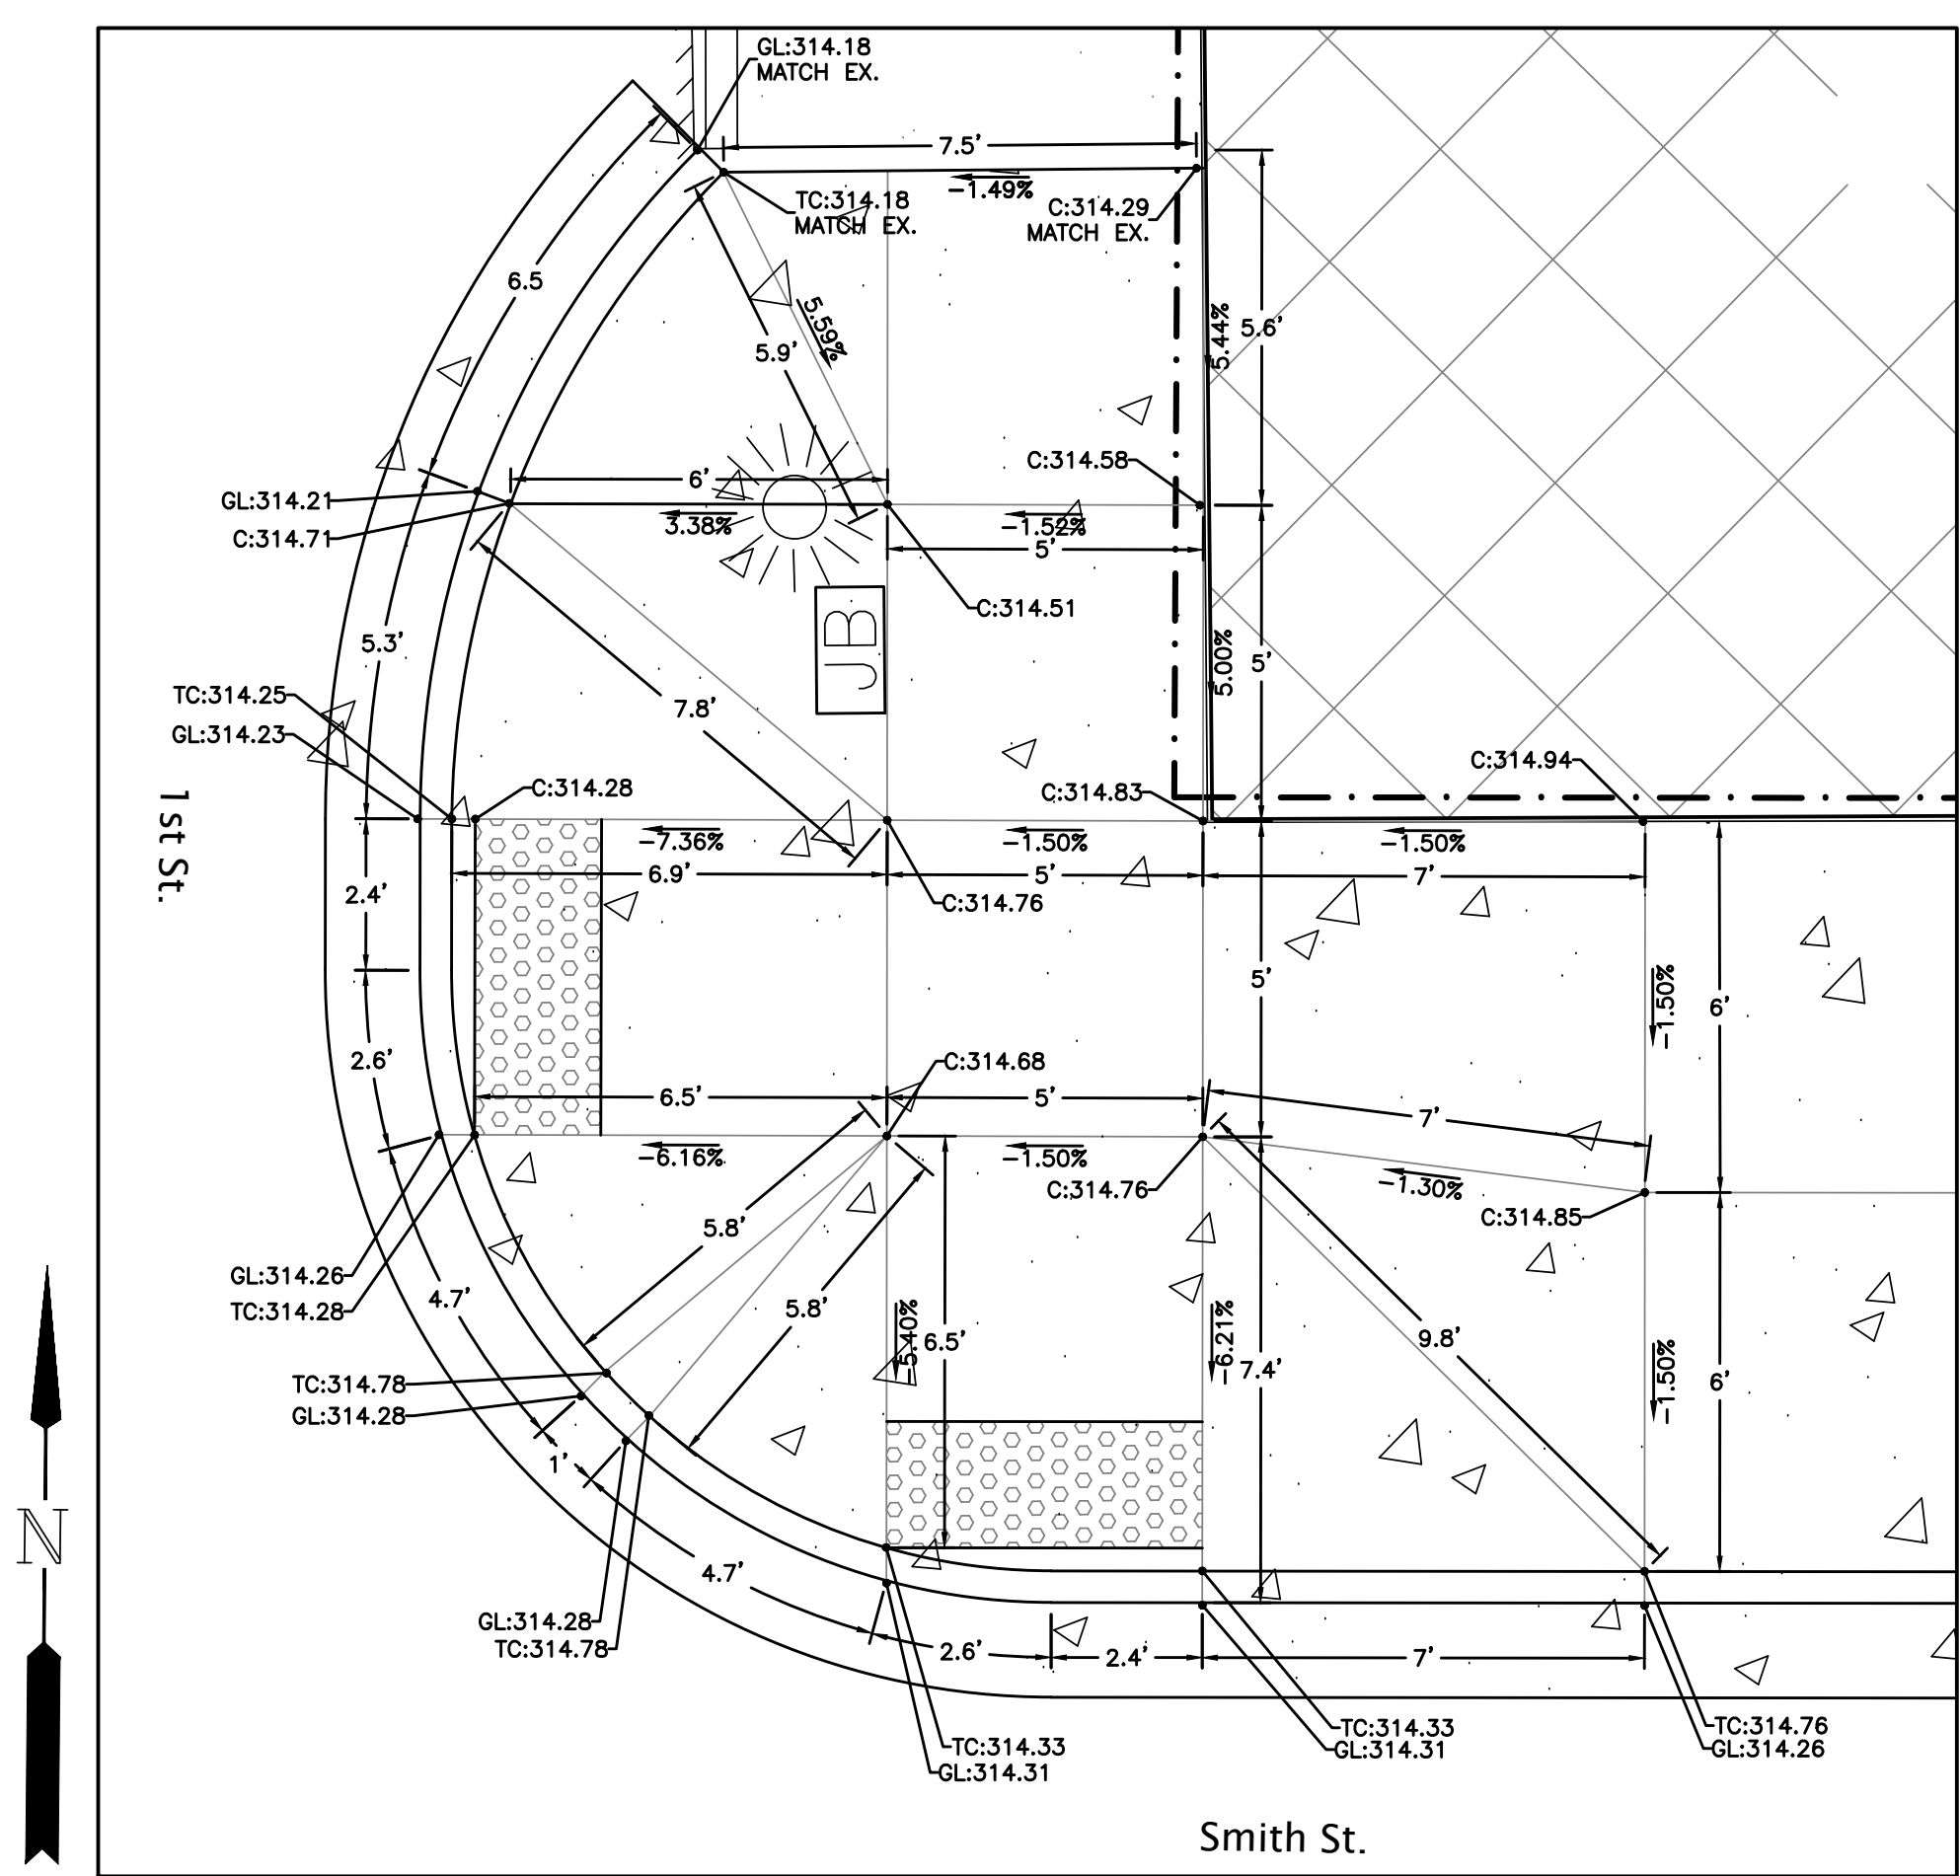

1 1st & Smith - NE ADA Ramp

SCALE: 1"=3'

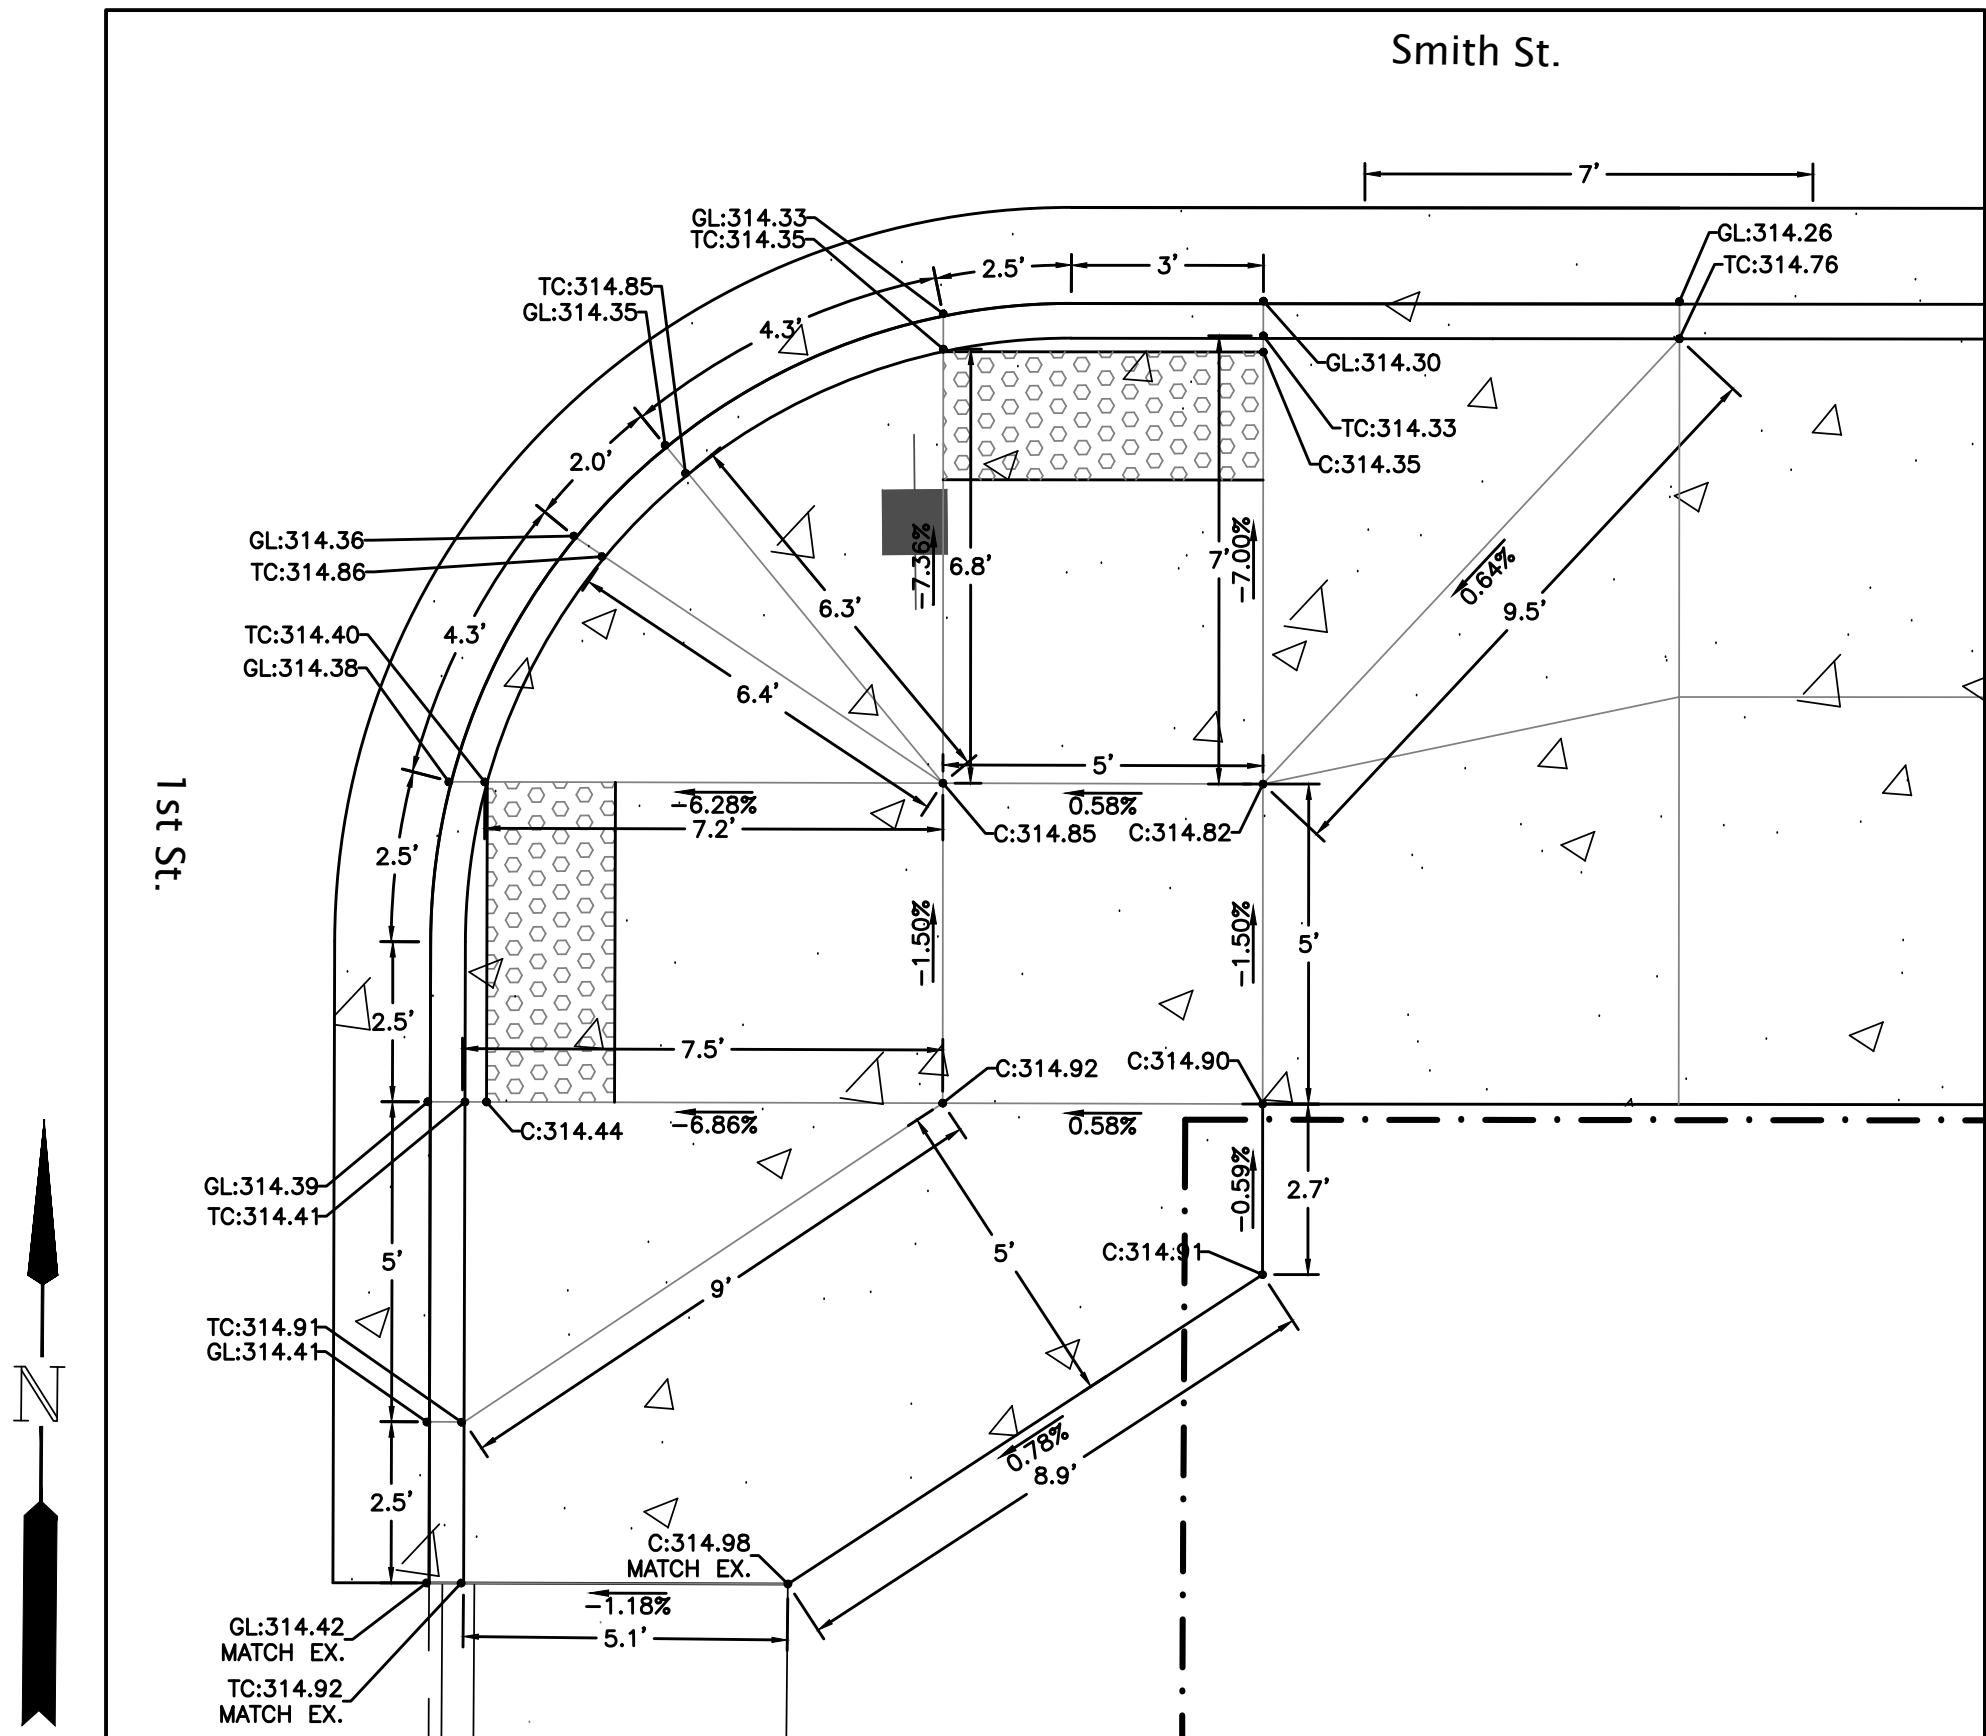

2 1st & Smith - SE ADA Ramp

SCALE: 1"=3'

Branch
ENGINEERING, INC.
Since 1977
civil • transportation
structural • geotechnical
SURVEYING

310 5th Street
Springfield, OR 97477
p: 541.746.0637

www.BranchEngineering.com
Springfield OR | Albany OR



EXPIRES: DECEMBER 31, 2020

project title:

CITY OF HARRISBURG Smith, Macy, & 2nd Street Rehabilitation

Smith - 1st To 3rd, Macy - 2nd To 3rd, 2nd - Smith To Macy
HARRISBURG, OREGON

revisions:


date: JANUARY 28, 2020
drawn by: GAM
designer: GAM
project no: 17-009F

**Curb Return
ADA Ramp
Details**


sheet:

C11

Z:\2017\17-009F Harrisburg Smith Street\Drawing\17-009F Street Improvements.dwg / 2/25/2020 2:01 PM JLL/E

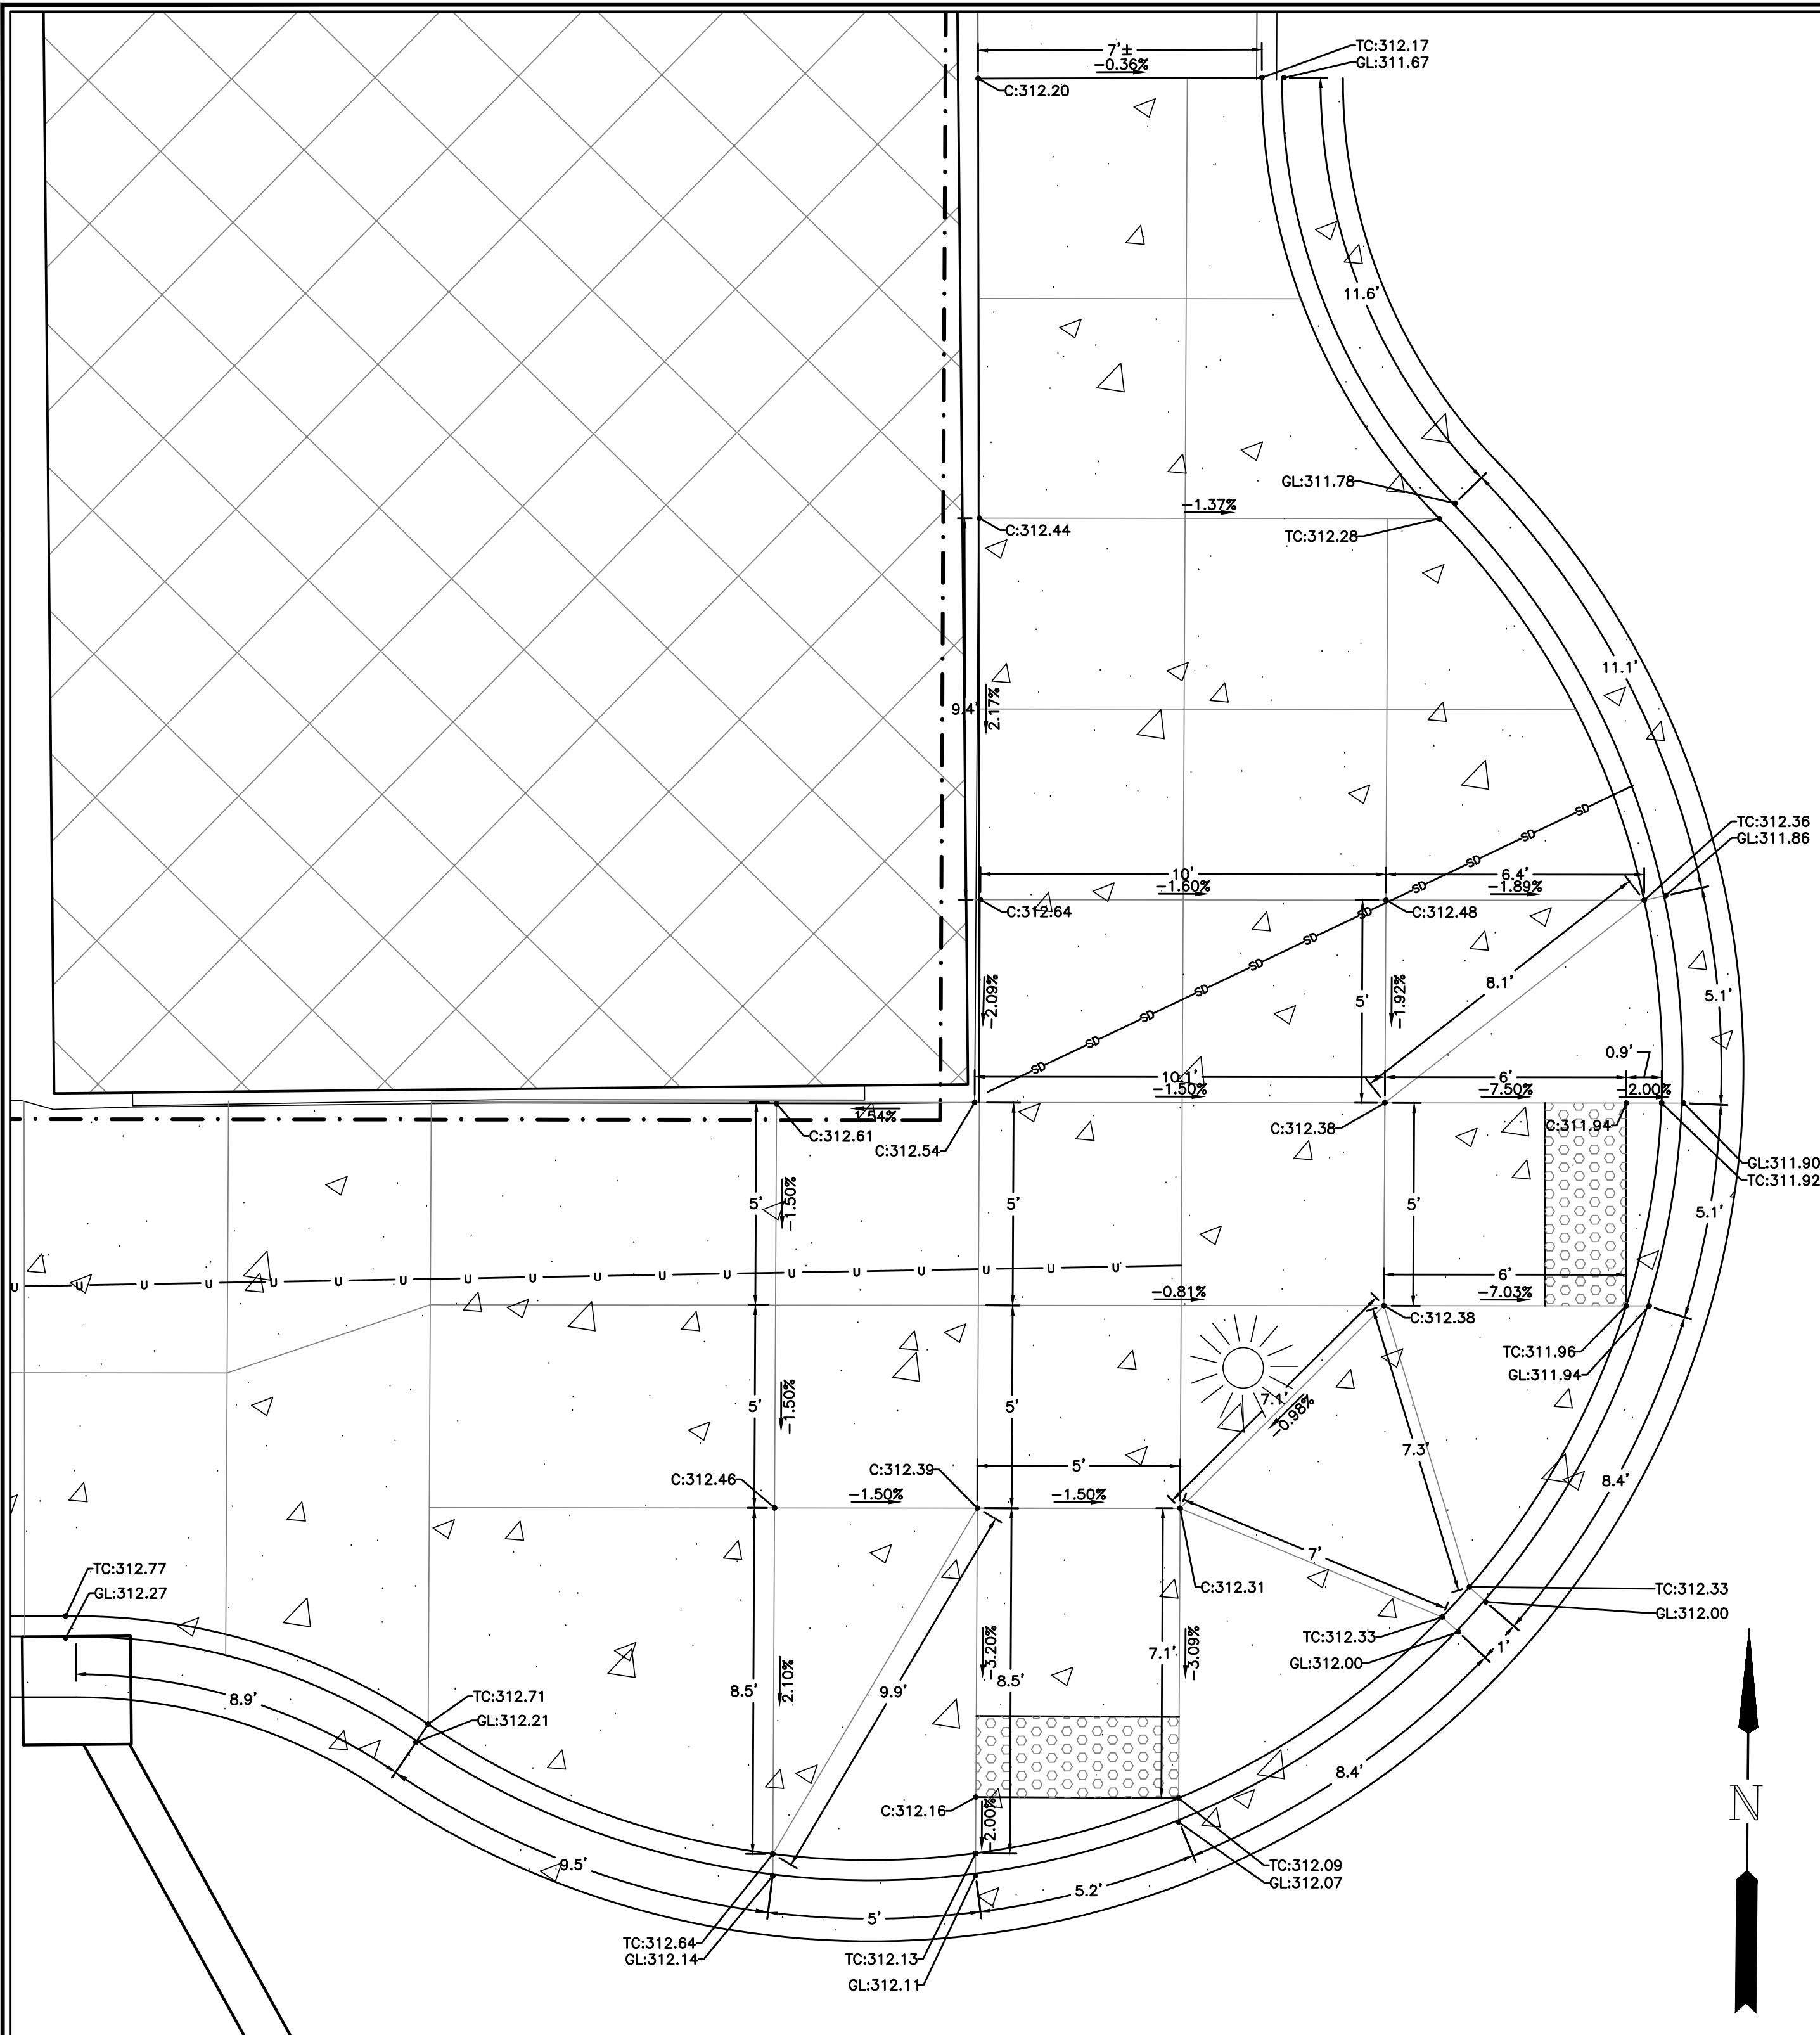

1
C12 2nd & Smith - NW ADA Ramp
SCALE: 1"=3'

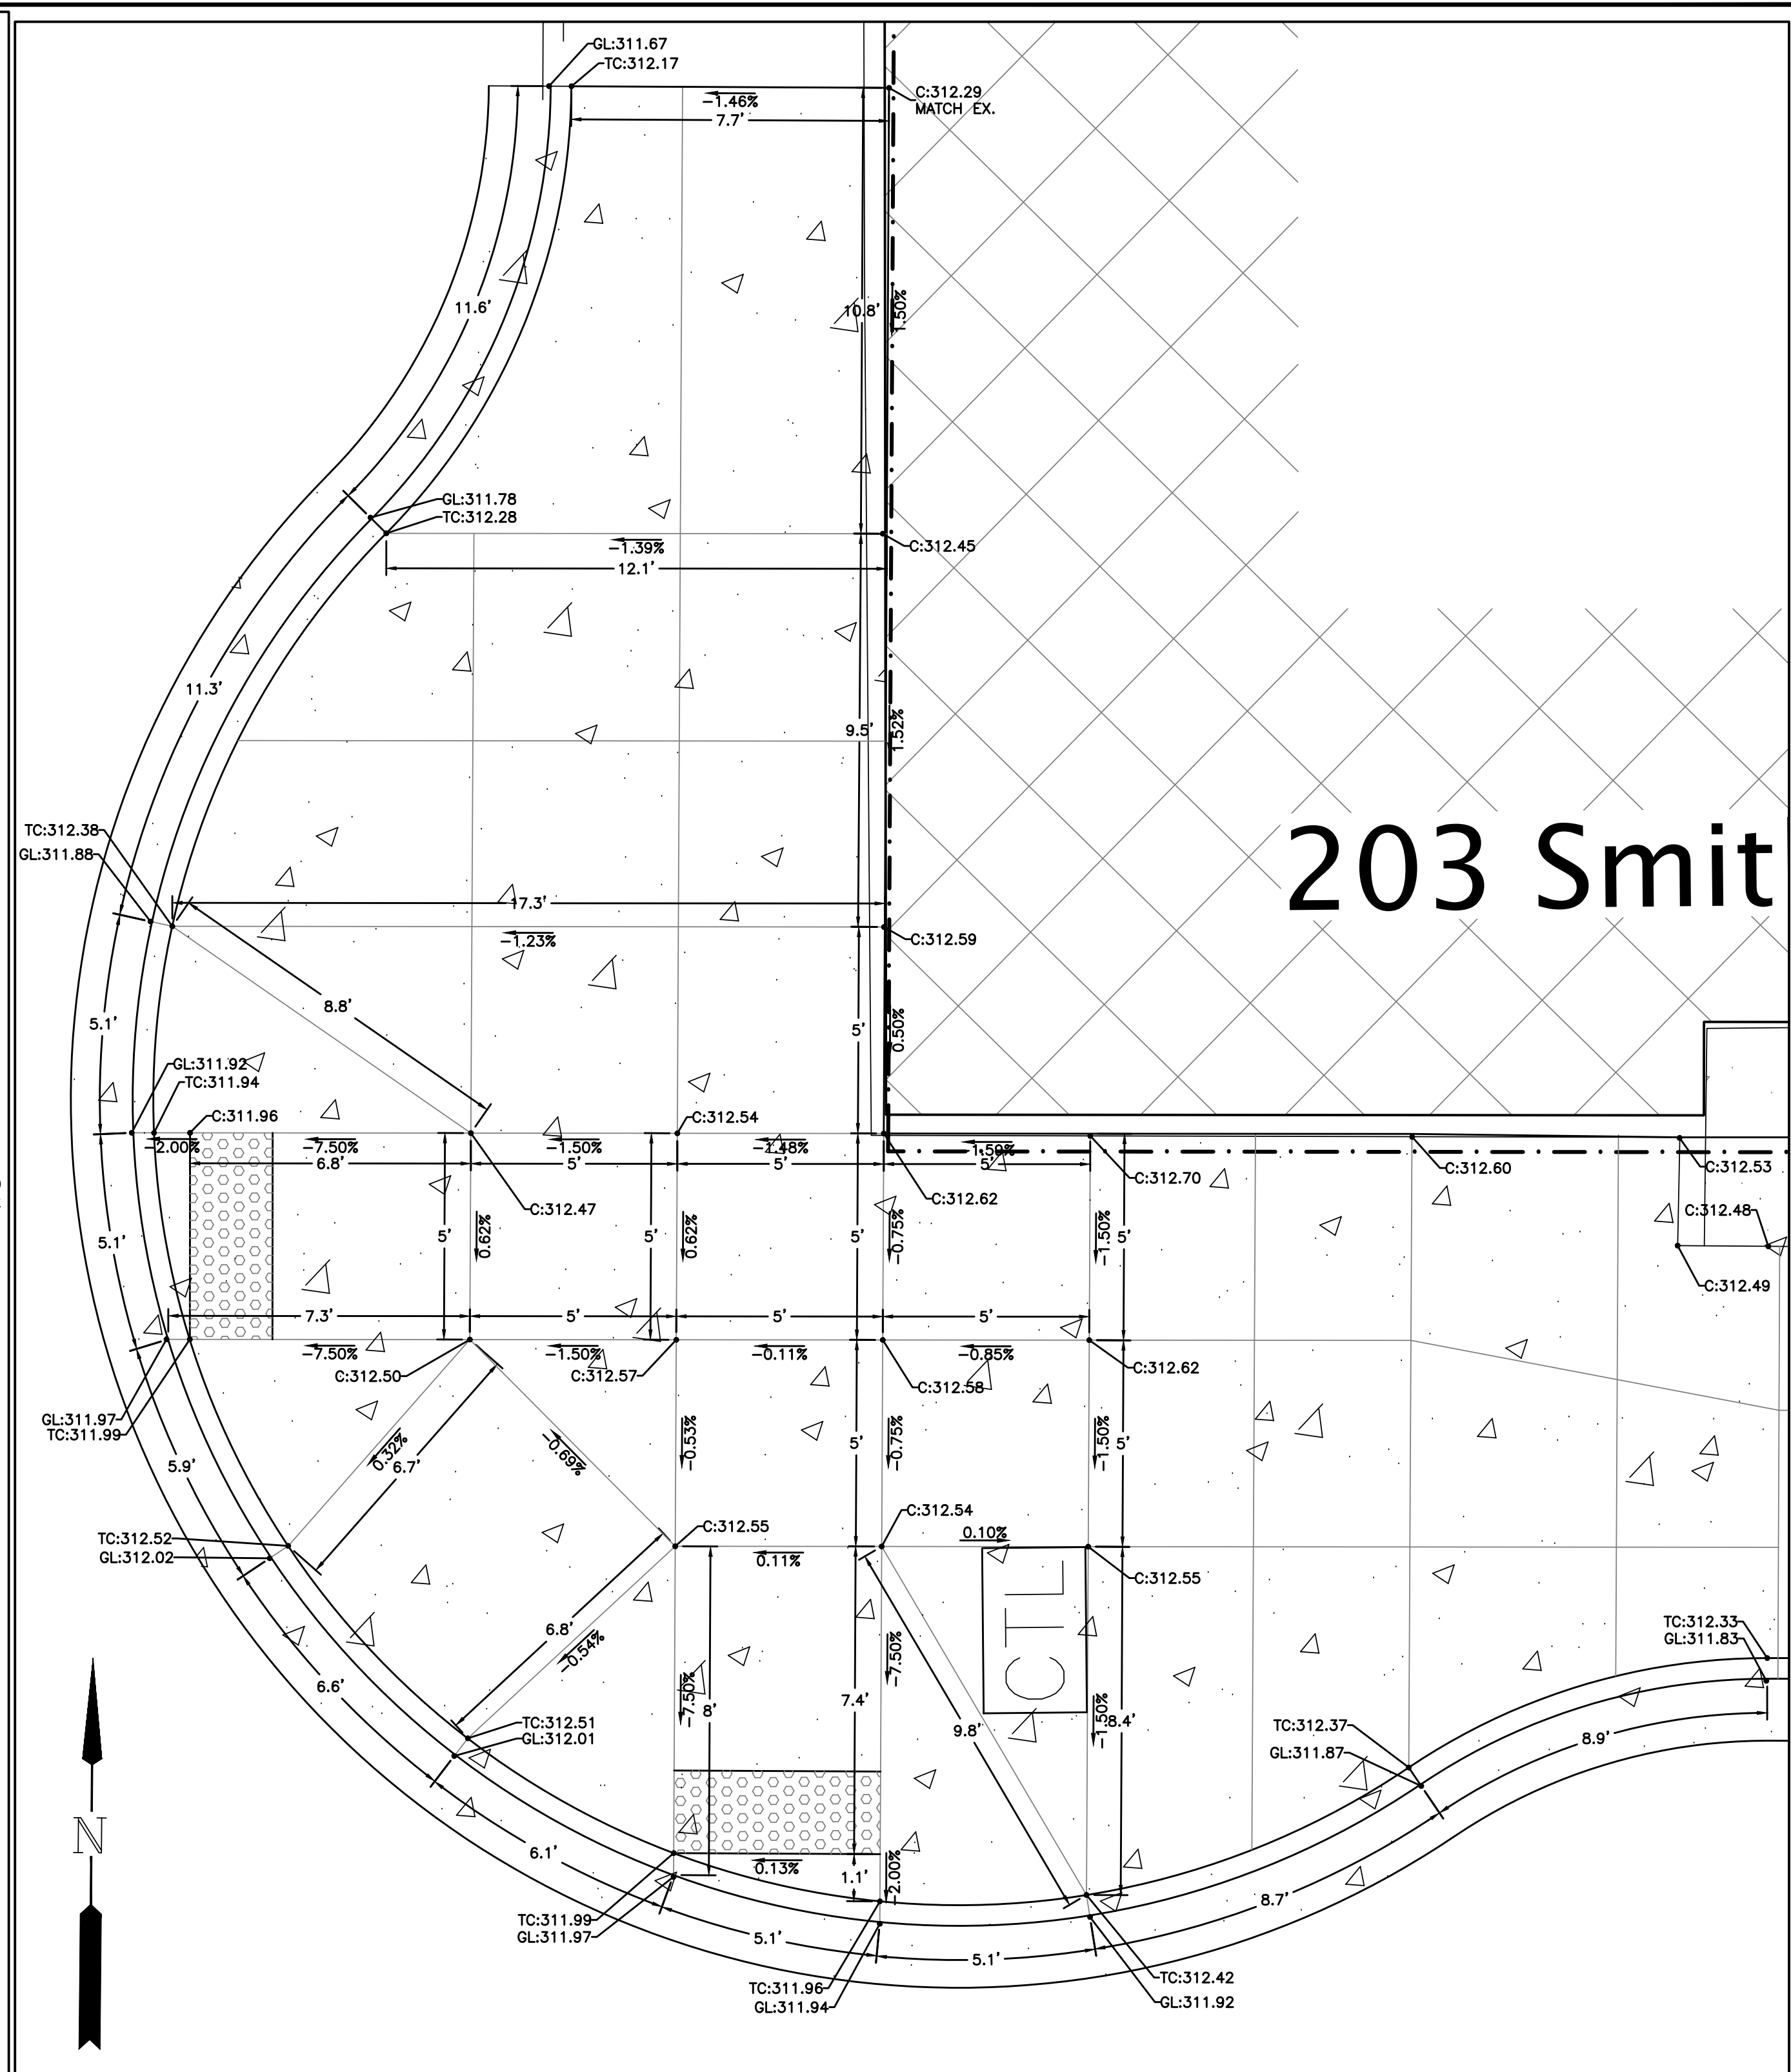

2
C12 2nd & Smith - NE ADA Ramp
SCALE: 1"=3'


project title:
CITY OF HARRISBURG
Smith, Macy, & 2nd Street Rehabilitation
Smith - 1st To 3rd, Macy - 2nd To 3rd, 2nd - Smith To Macy
HARRISBURG, OREGON

revisions:
date: JANUARY 28, 2020
drawn by: GAM
designer: GAM
project no: 17-009F


Curb Return
ADA Ramp
Details

sheet:
C12

Z:\2017\17-009F Harrisburg Smith Street\Drawings\17-009F Smith Street Improvements.dwg / 2/9/2020 2:01 PM JLL/E

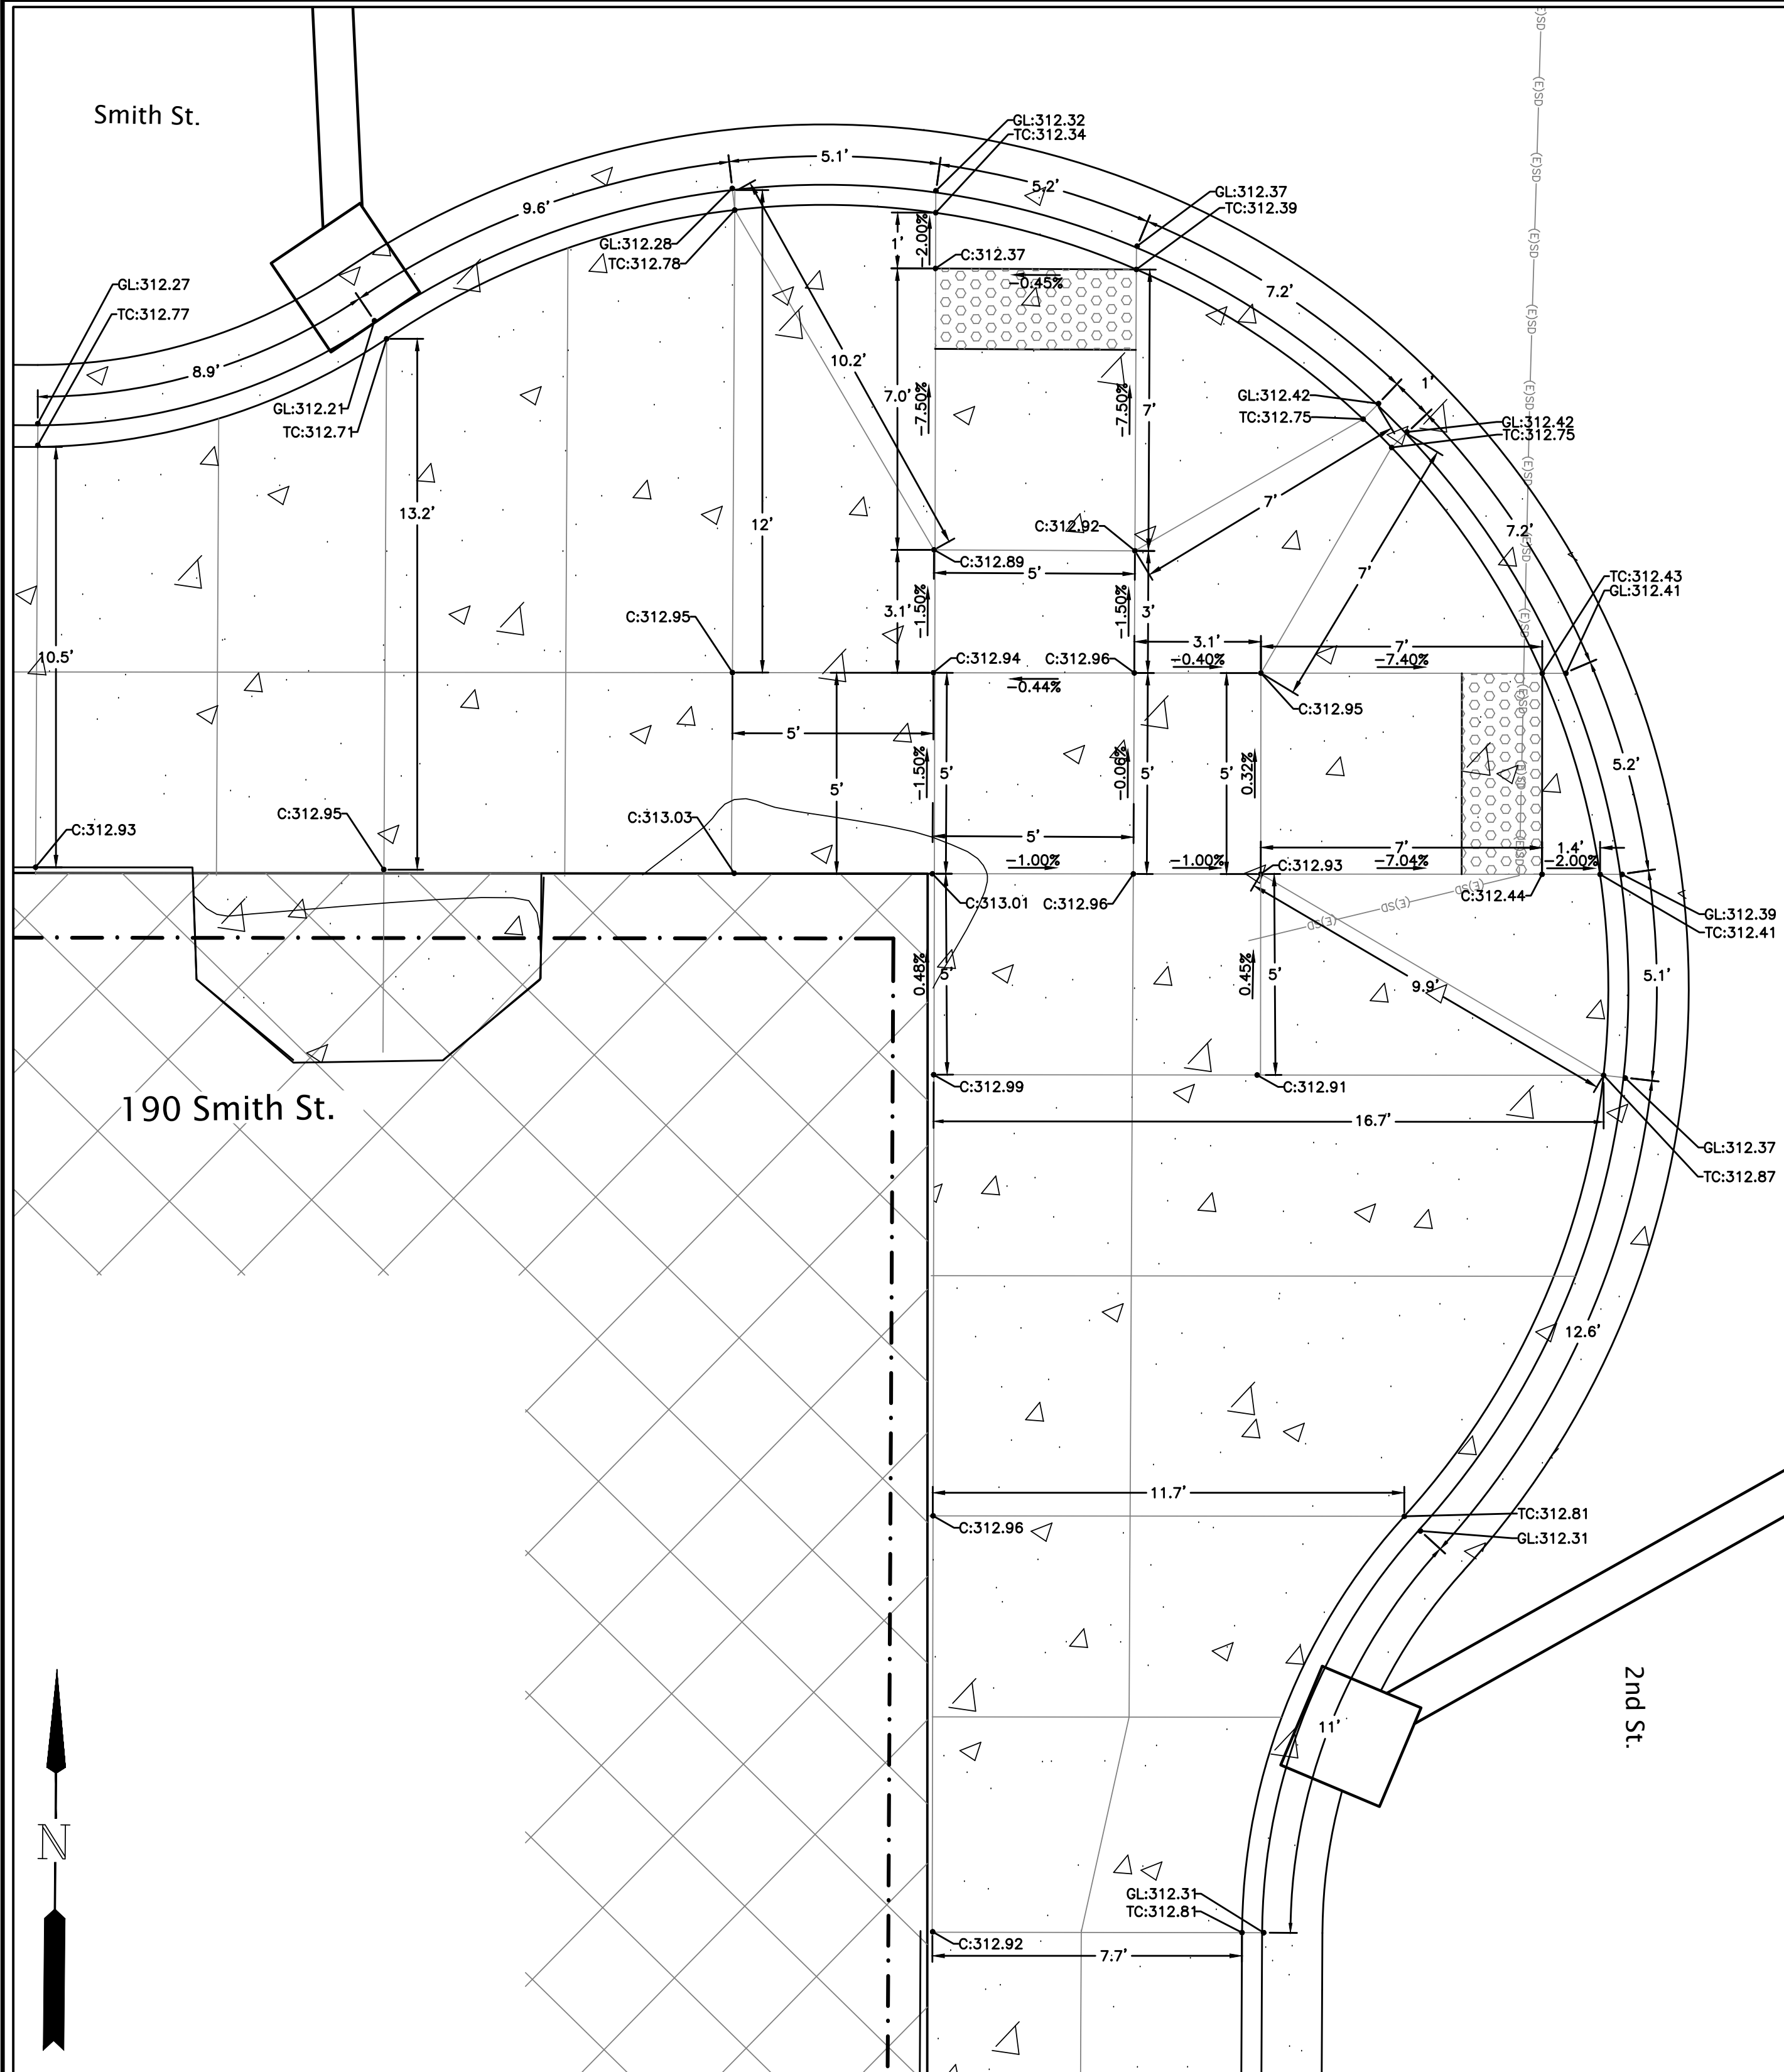

1
C13
2nd & Smith - SW ADA Ramp
SCALE: 1"=3'

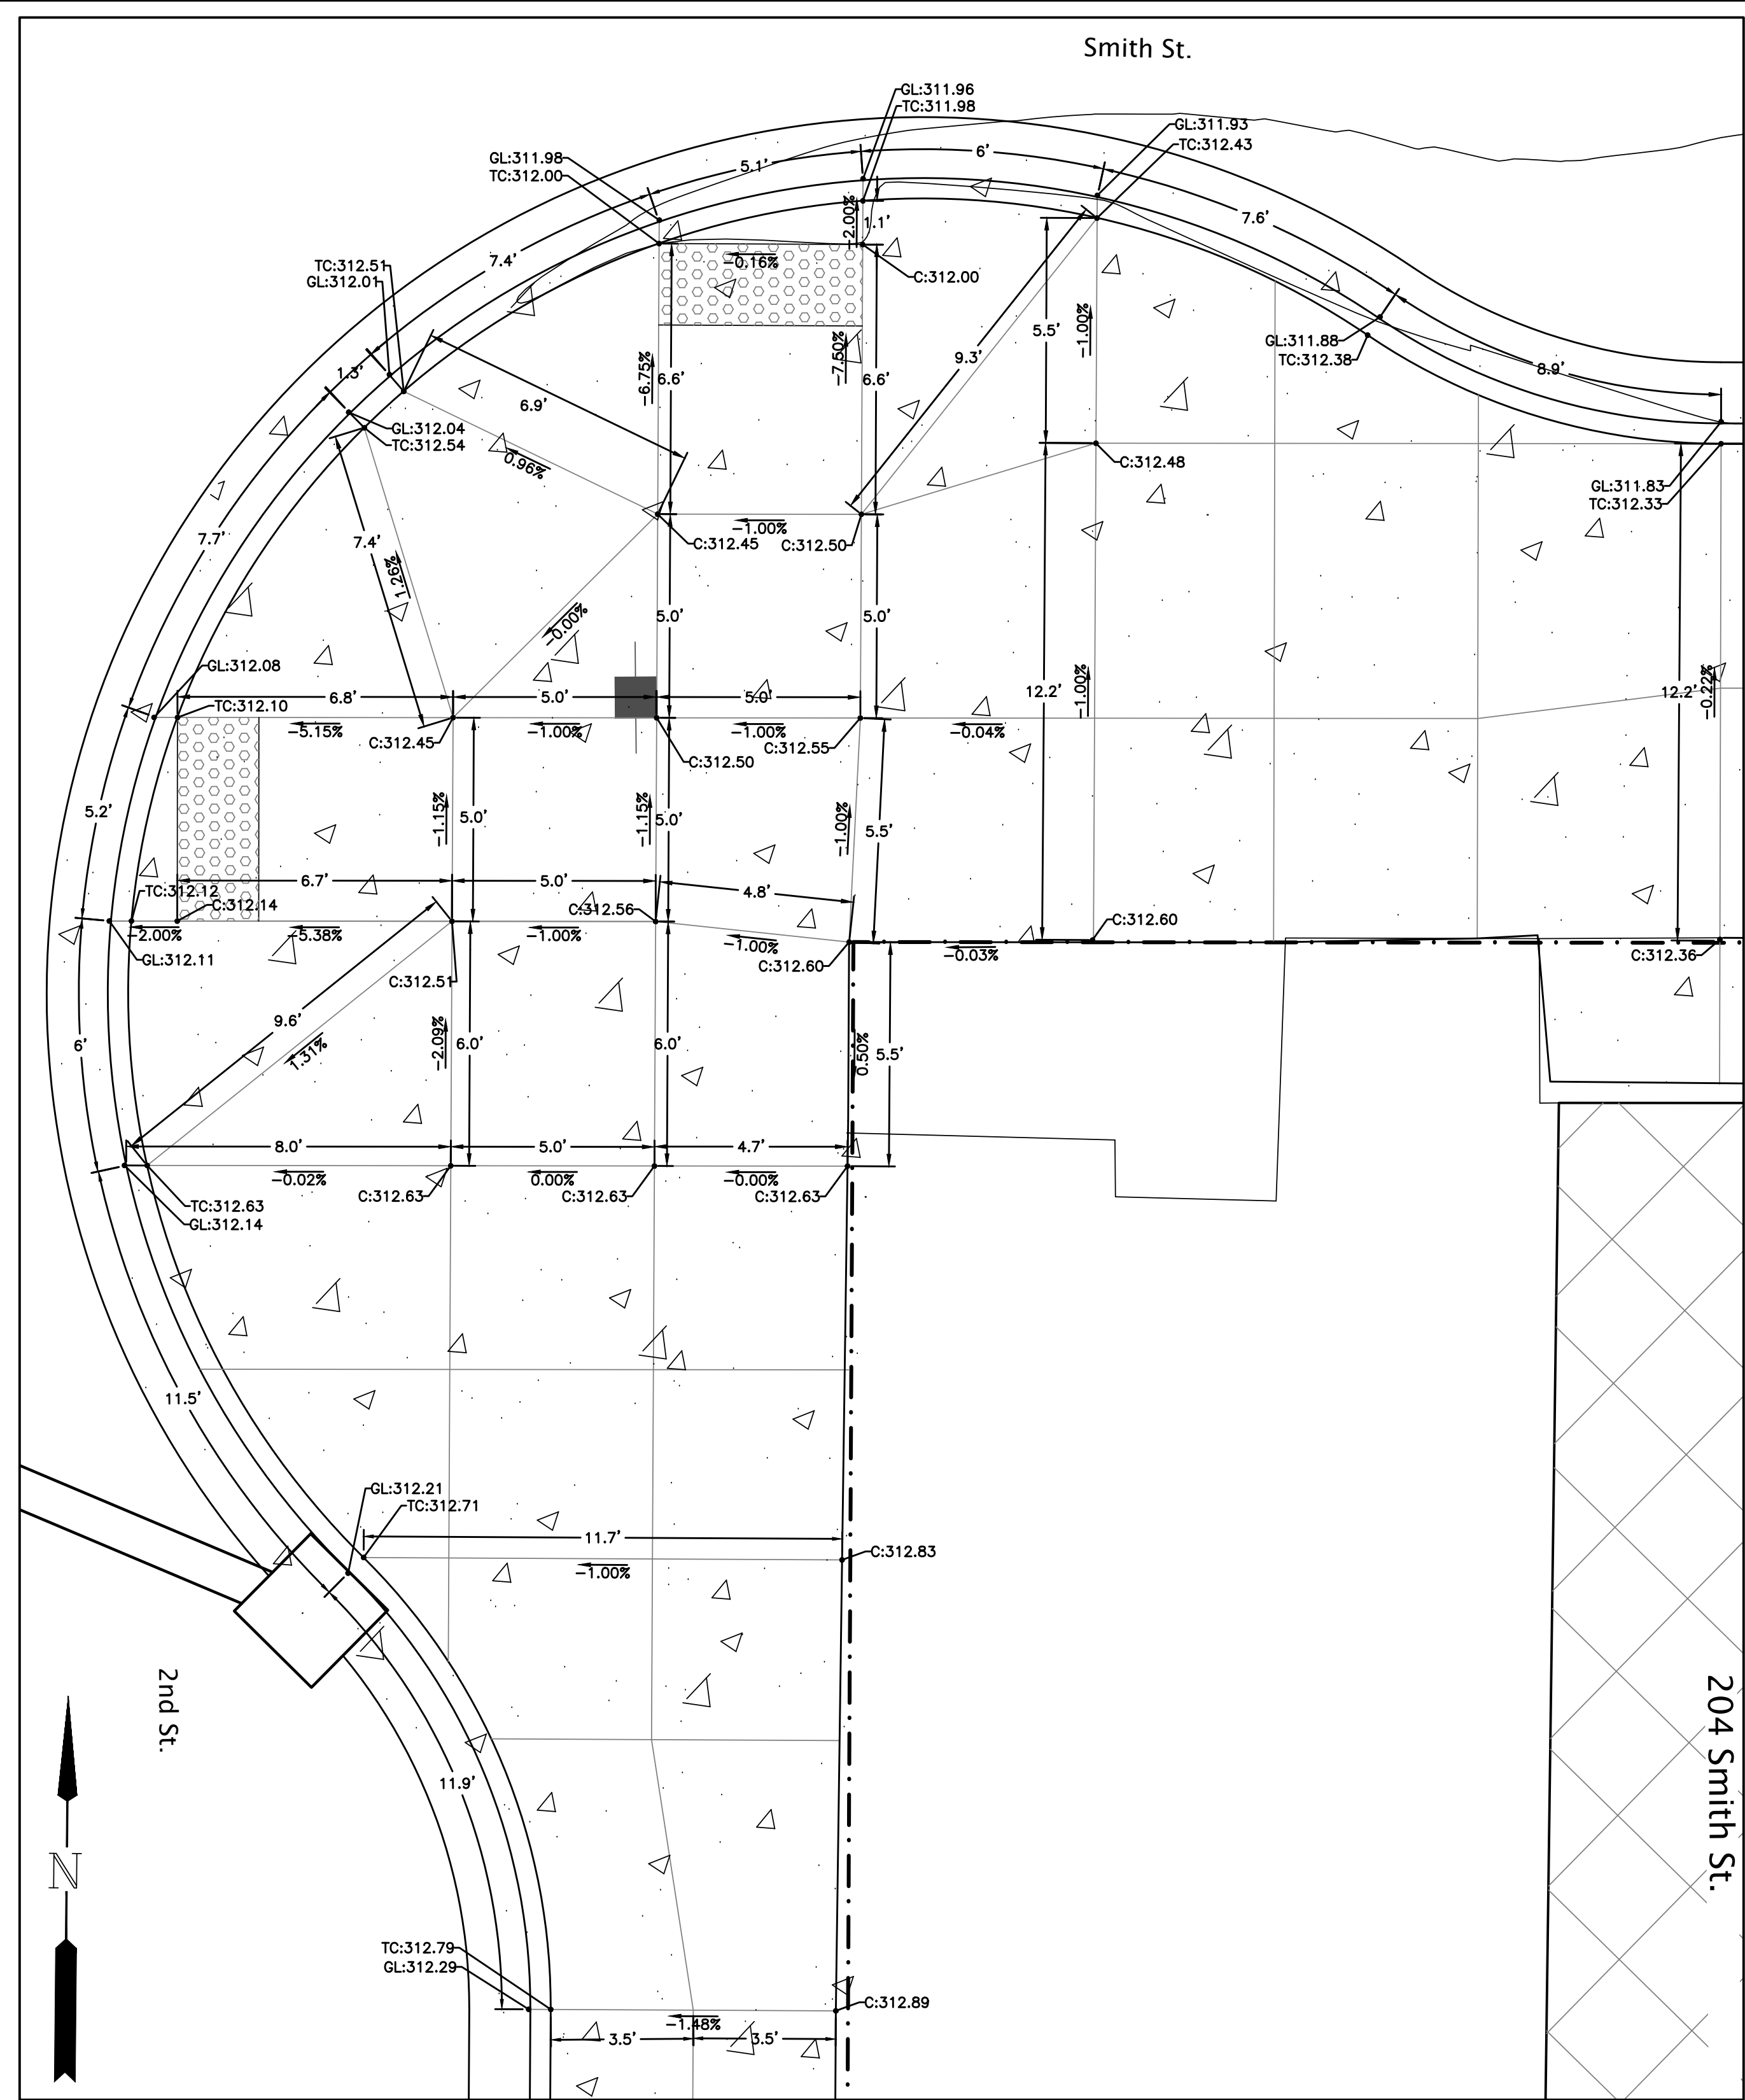

2
C13
2nd & Smith - SE ADA Ramp
SCALE: 1"=3'

Branch ENGINEERING INC.
Since 1977
civil • transportation
structural • geotechnical
SURVEYING
310 5th Street
Springfield, OR 97477
p: 541.746.0637
www.BranchEngineering.com
Springfield OR | Albany OR


REGISTERED PROFESSIONAL
ENGINEER
#53,800
DIGITALLY SIGNED
OREGON
JULY 9, 2001
GREGORY A. MOWER
EXPIRES: DECEMBER 31, 2020

project title:
CITY OF HARRISBURG
Smith, Macy, & 2nd Street Rehabilitation
Smith - 1st To 3rd, Macy - 2nd To 3rd, 2nd - Smith To Macy
HARRISBURG, OREGON

revisions:
date: JANUARY 28, 2020
drawn by: GAM
designer: GAM
project no: 157-009F

**Curb Return
ADA Ramp
Details**

sheet:
C13

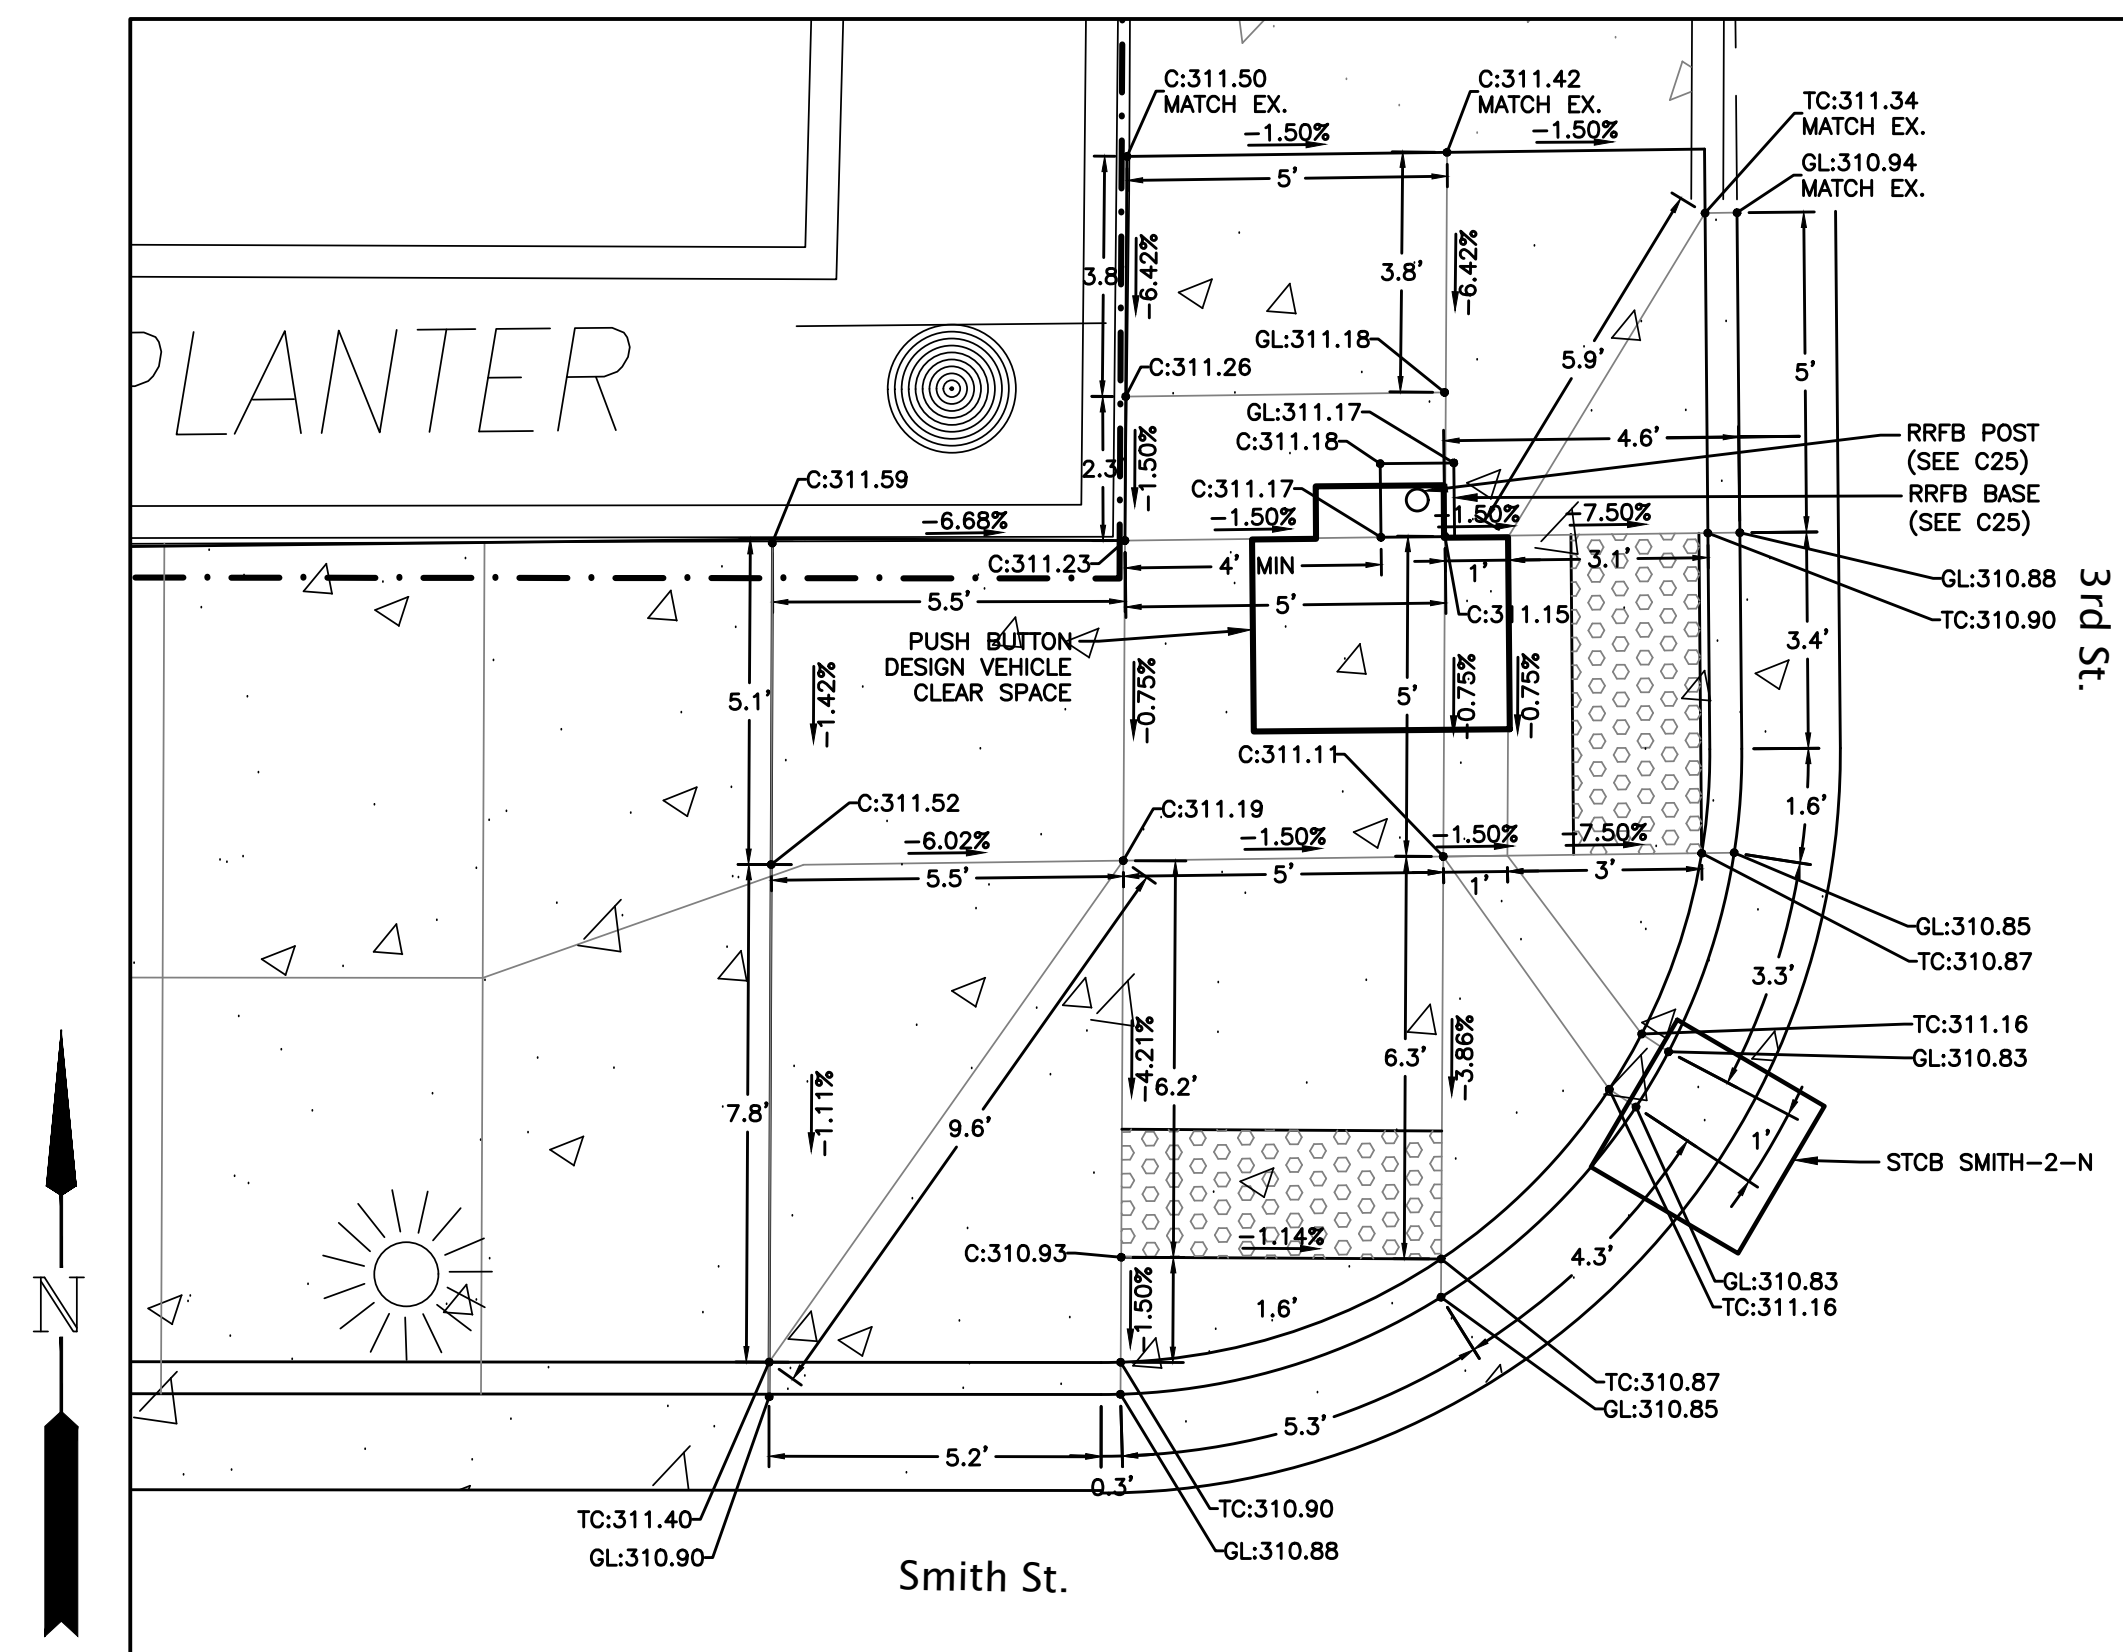


1
C14

3rd & Smith - NW ADA Ramp


SCALE: 1"=3'

ALTERNATE #1

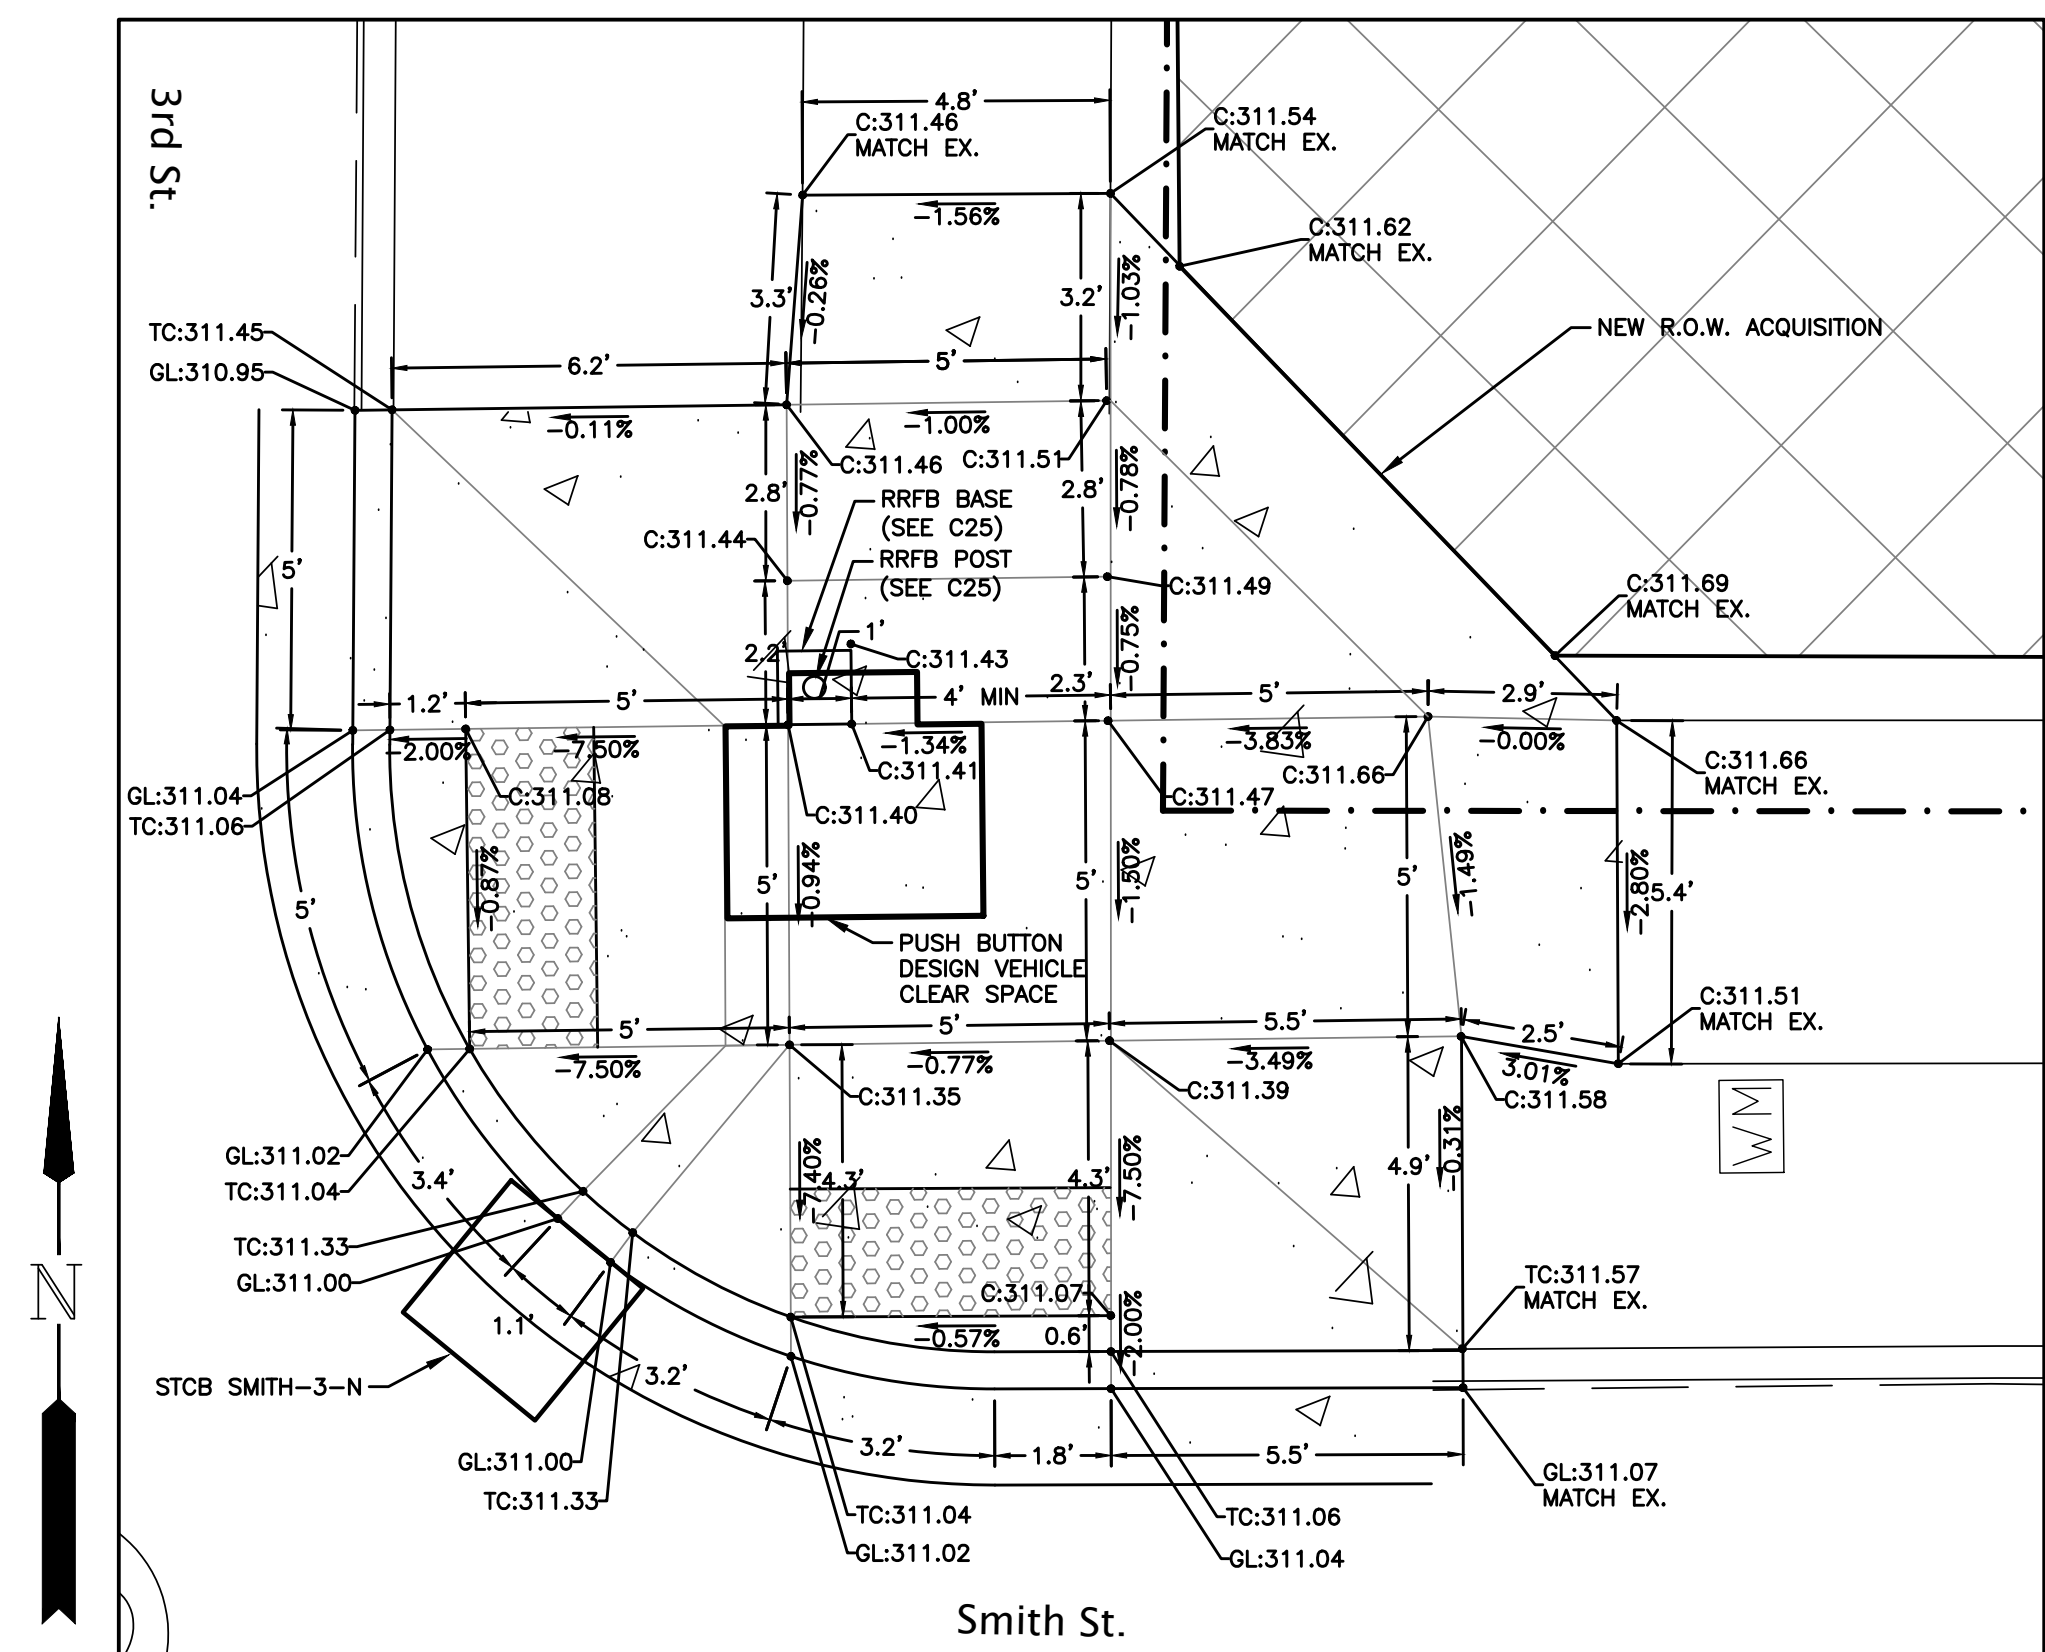

2 3rd & Smith - NE ADA Ramp
C14 SCALE: 1"=3'


➤ALTERNATE #1

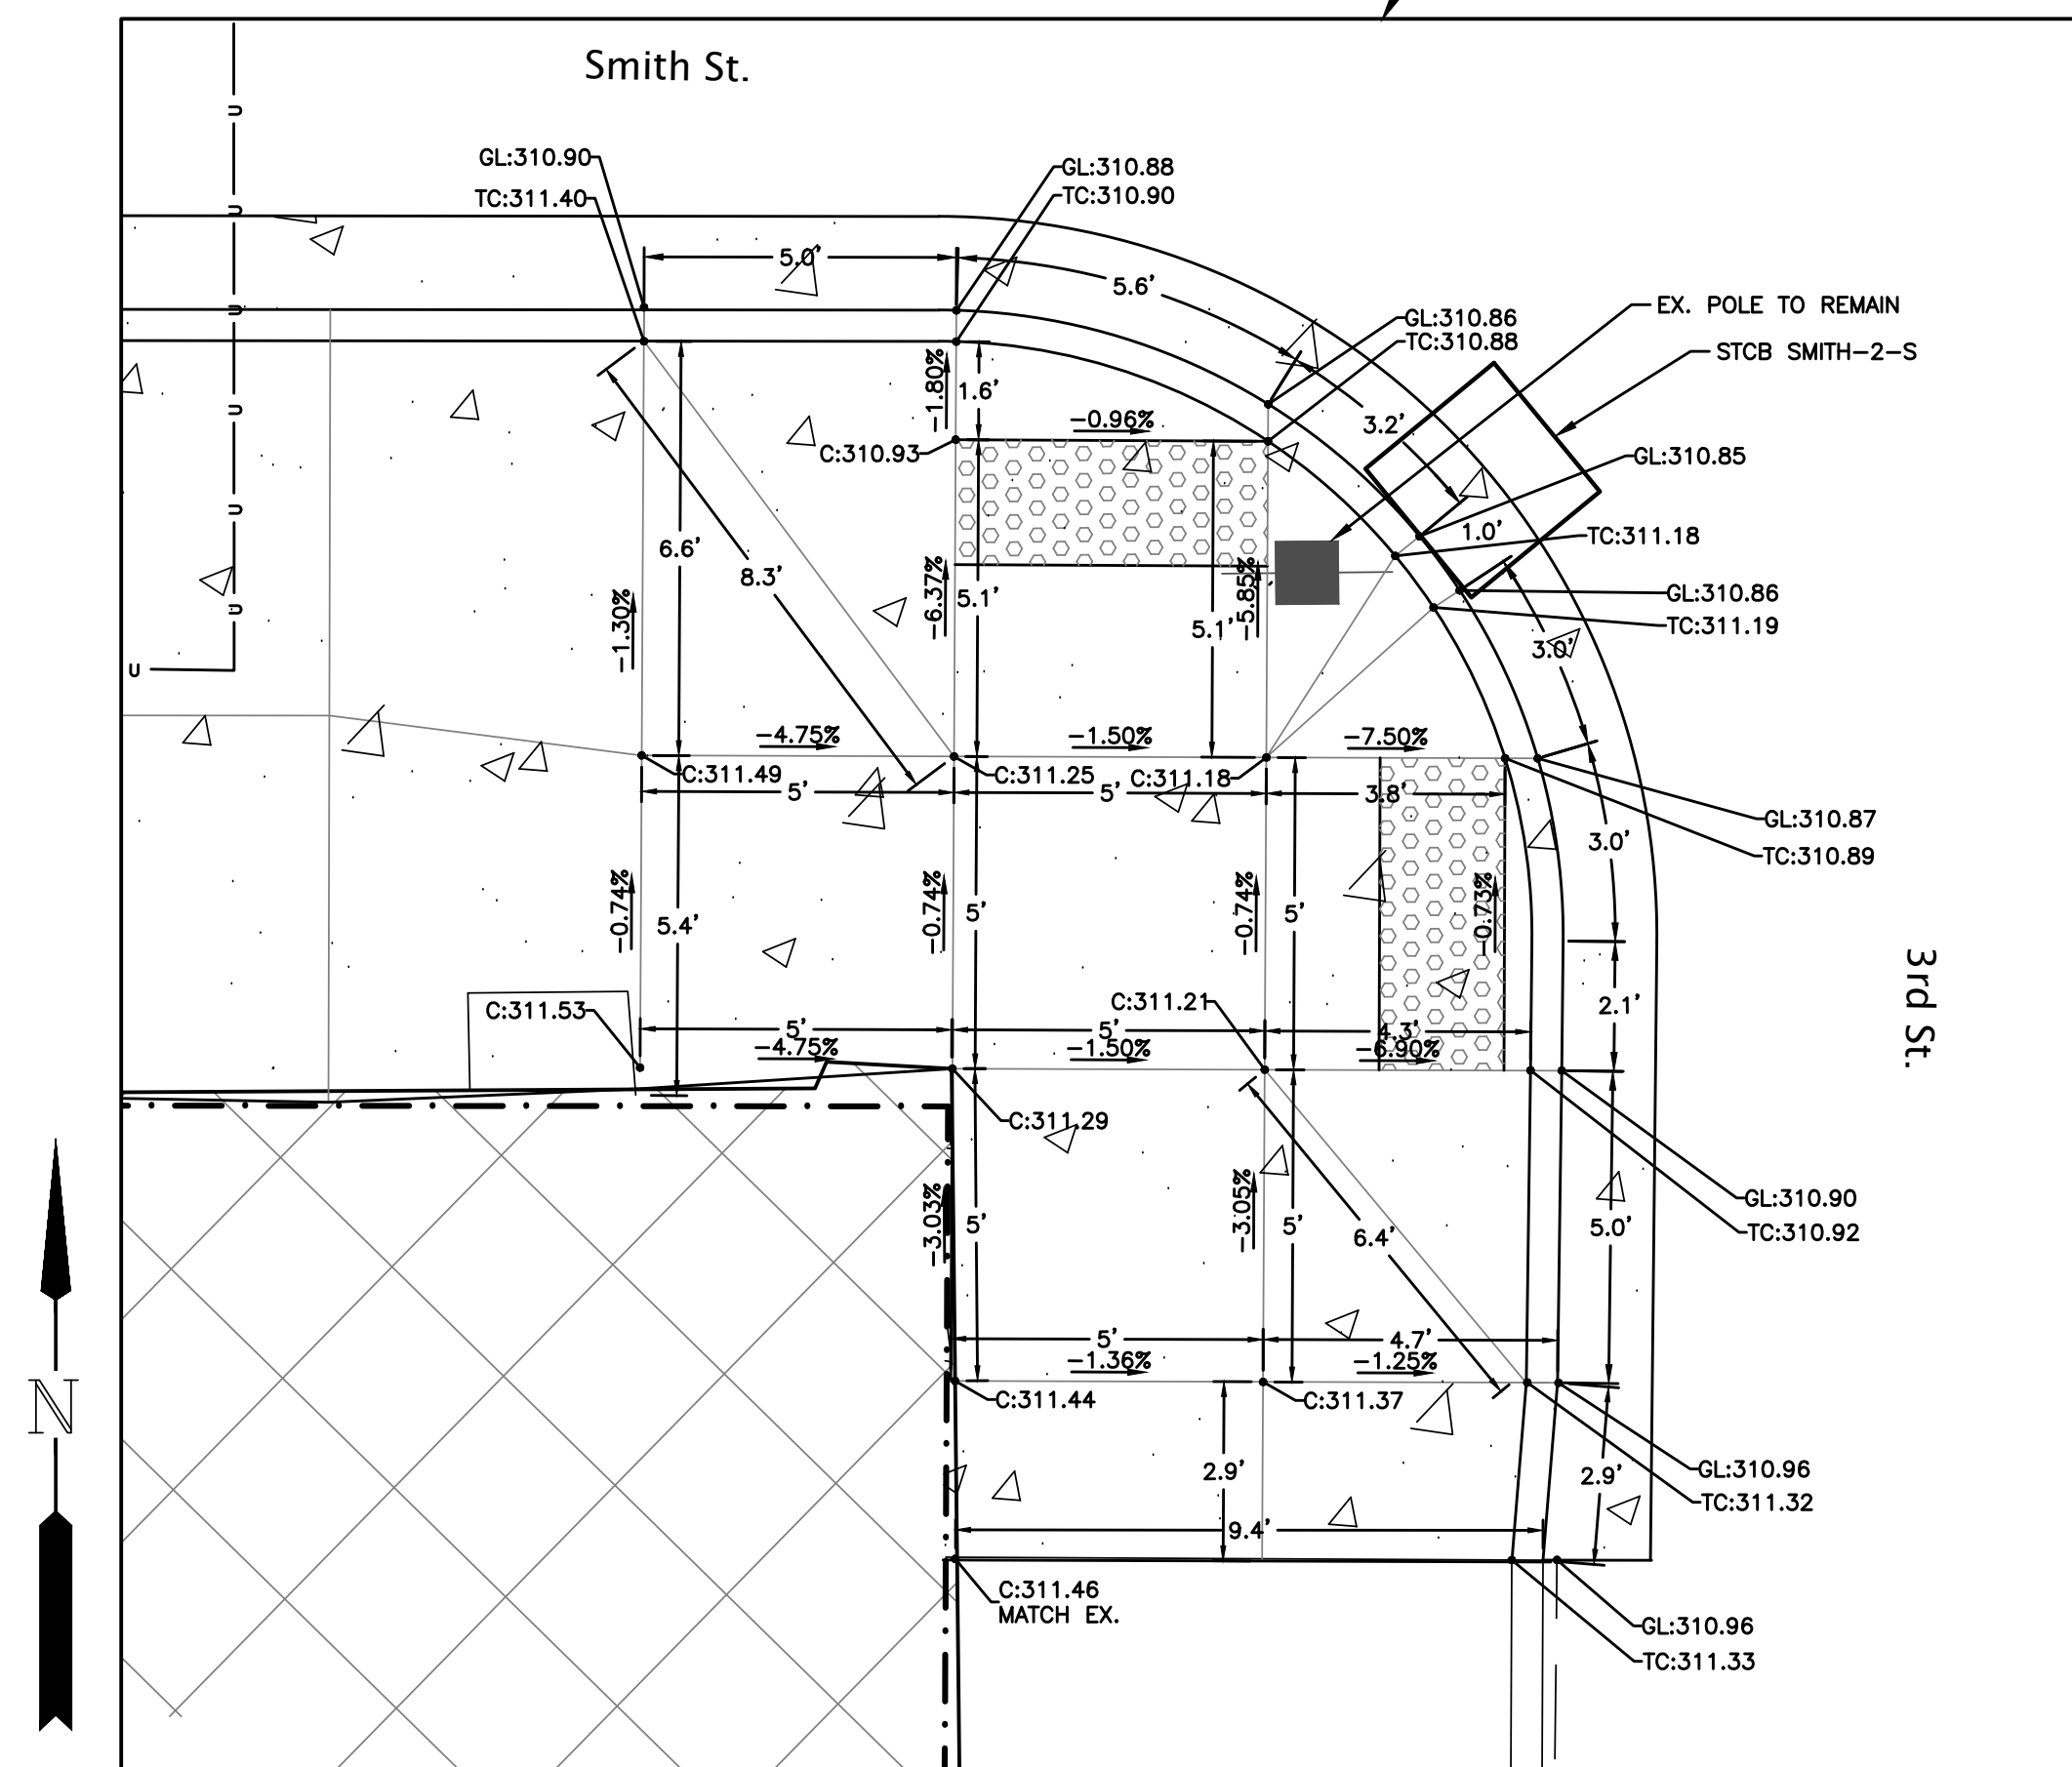

3
C14

3rd & Smith - SW ADA Ramp

SCALE: 1"=3'

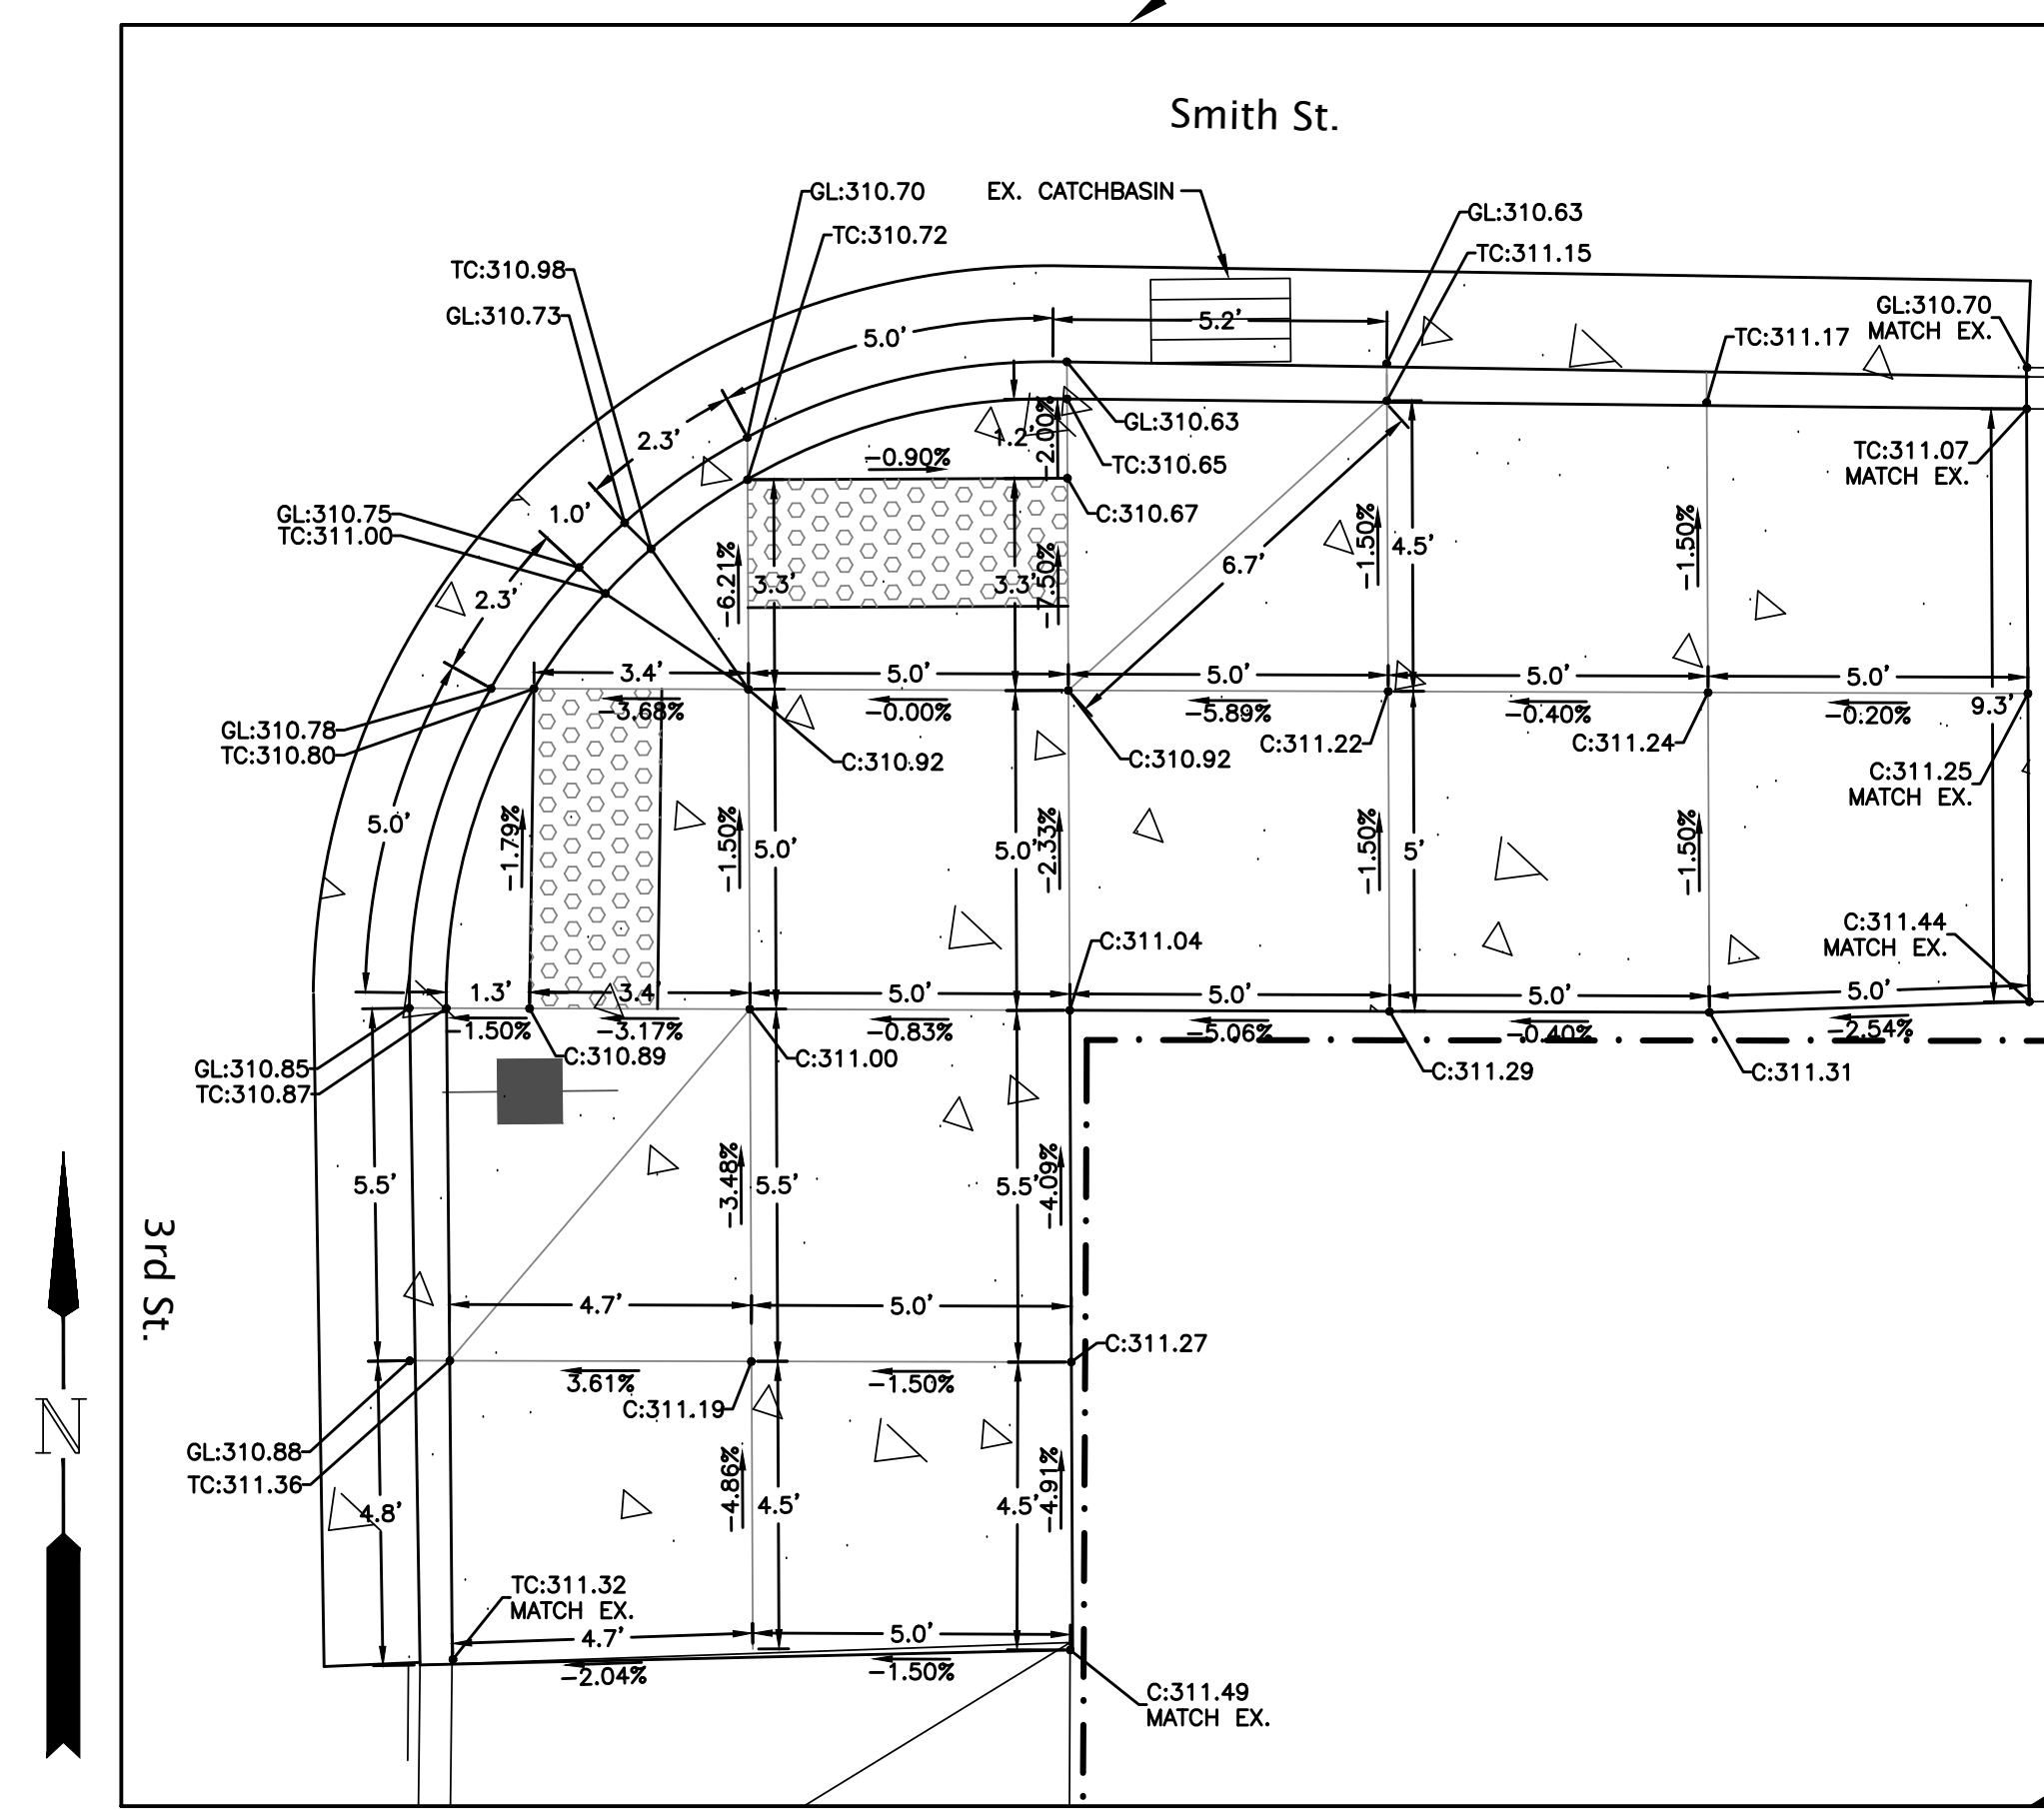


4
C14

3rd & Smith - SE ADA Ramp


SCALE: 1"=3'

Z:\2017\17-009F Harrisburg Smith Street\Drawings\17-009F Street Improvements.dwg / 2/9/2020 2:01 PM JLL/E


copyright © 2016 Branch Engineering, Inc.

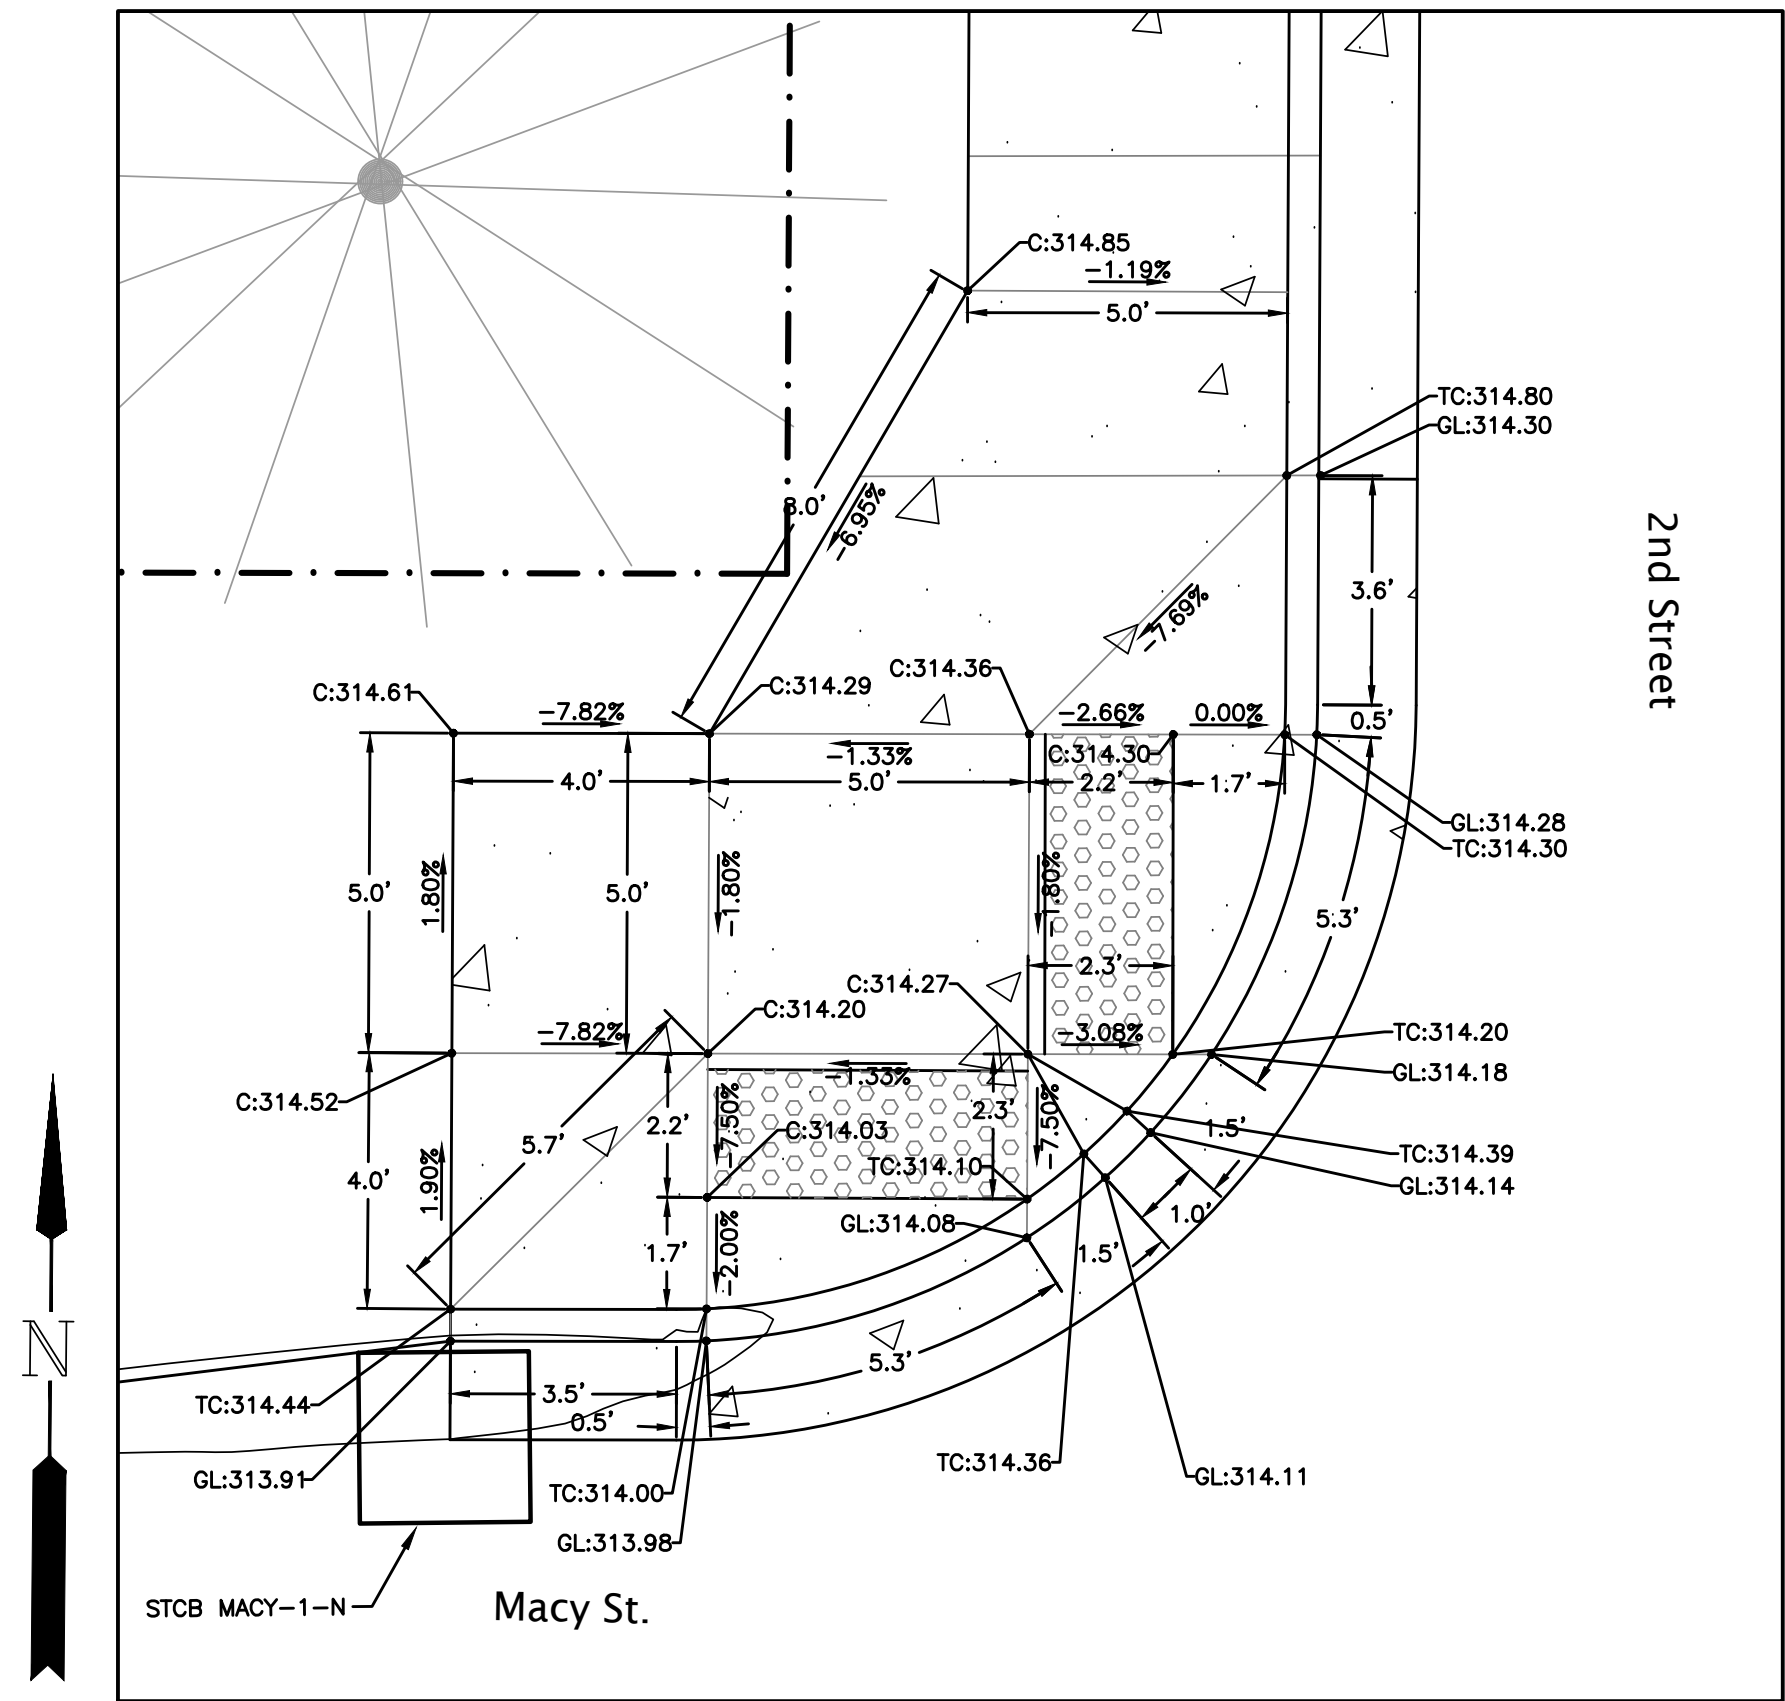


1 2nd & Macy - NW ADA Ramp
C15 SCALE: 1"=3'

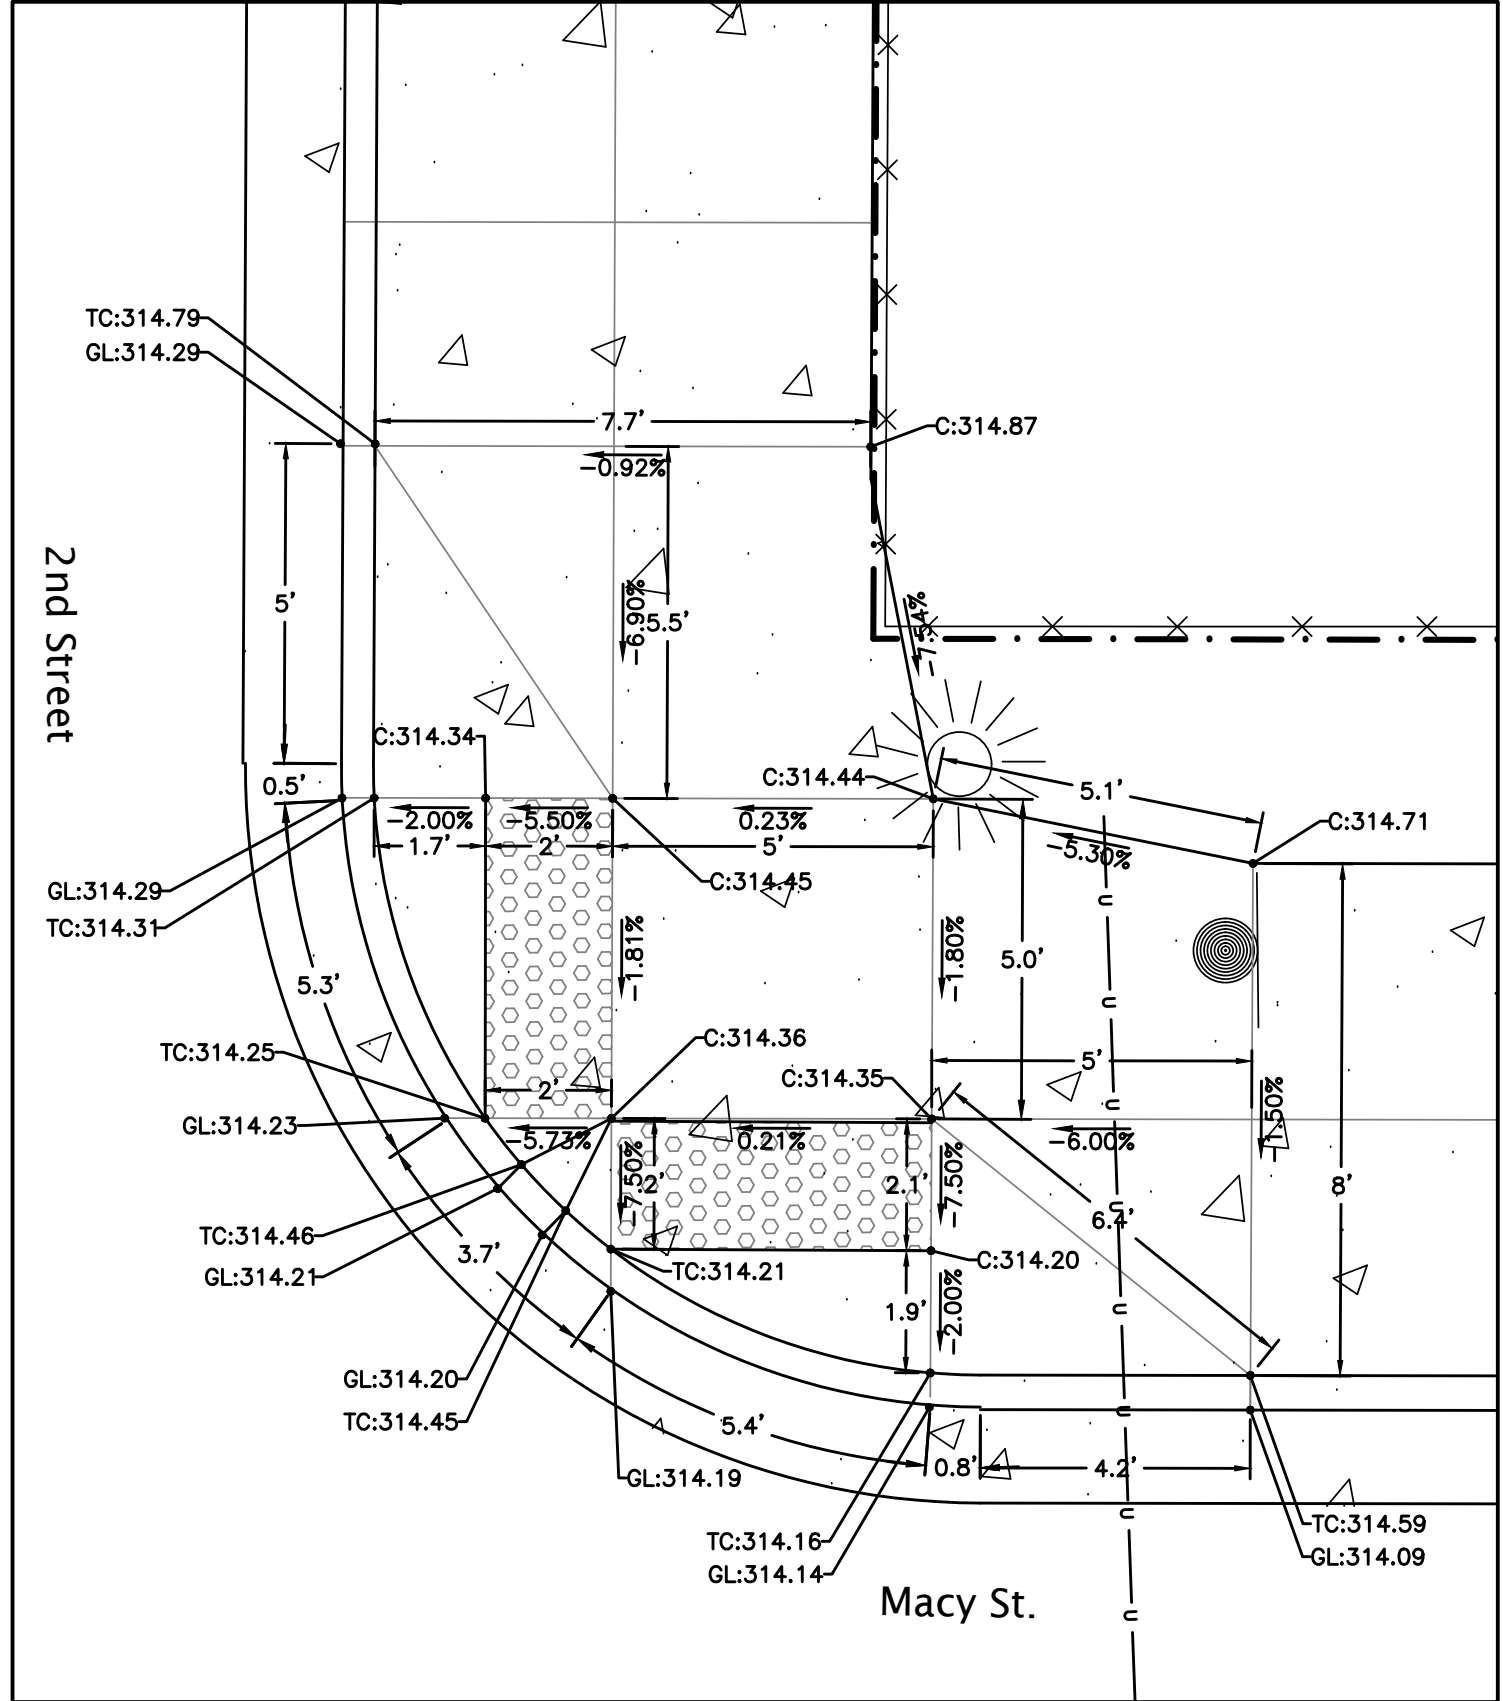

2 2nd & Macy - NE ADA Ramp
C15 SCALE: 1"=3'

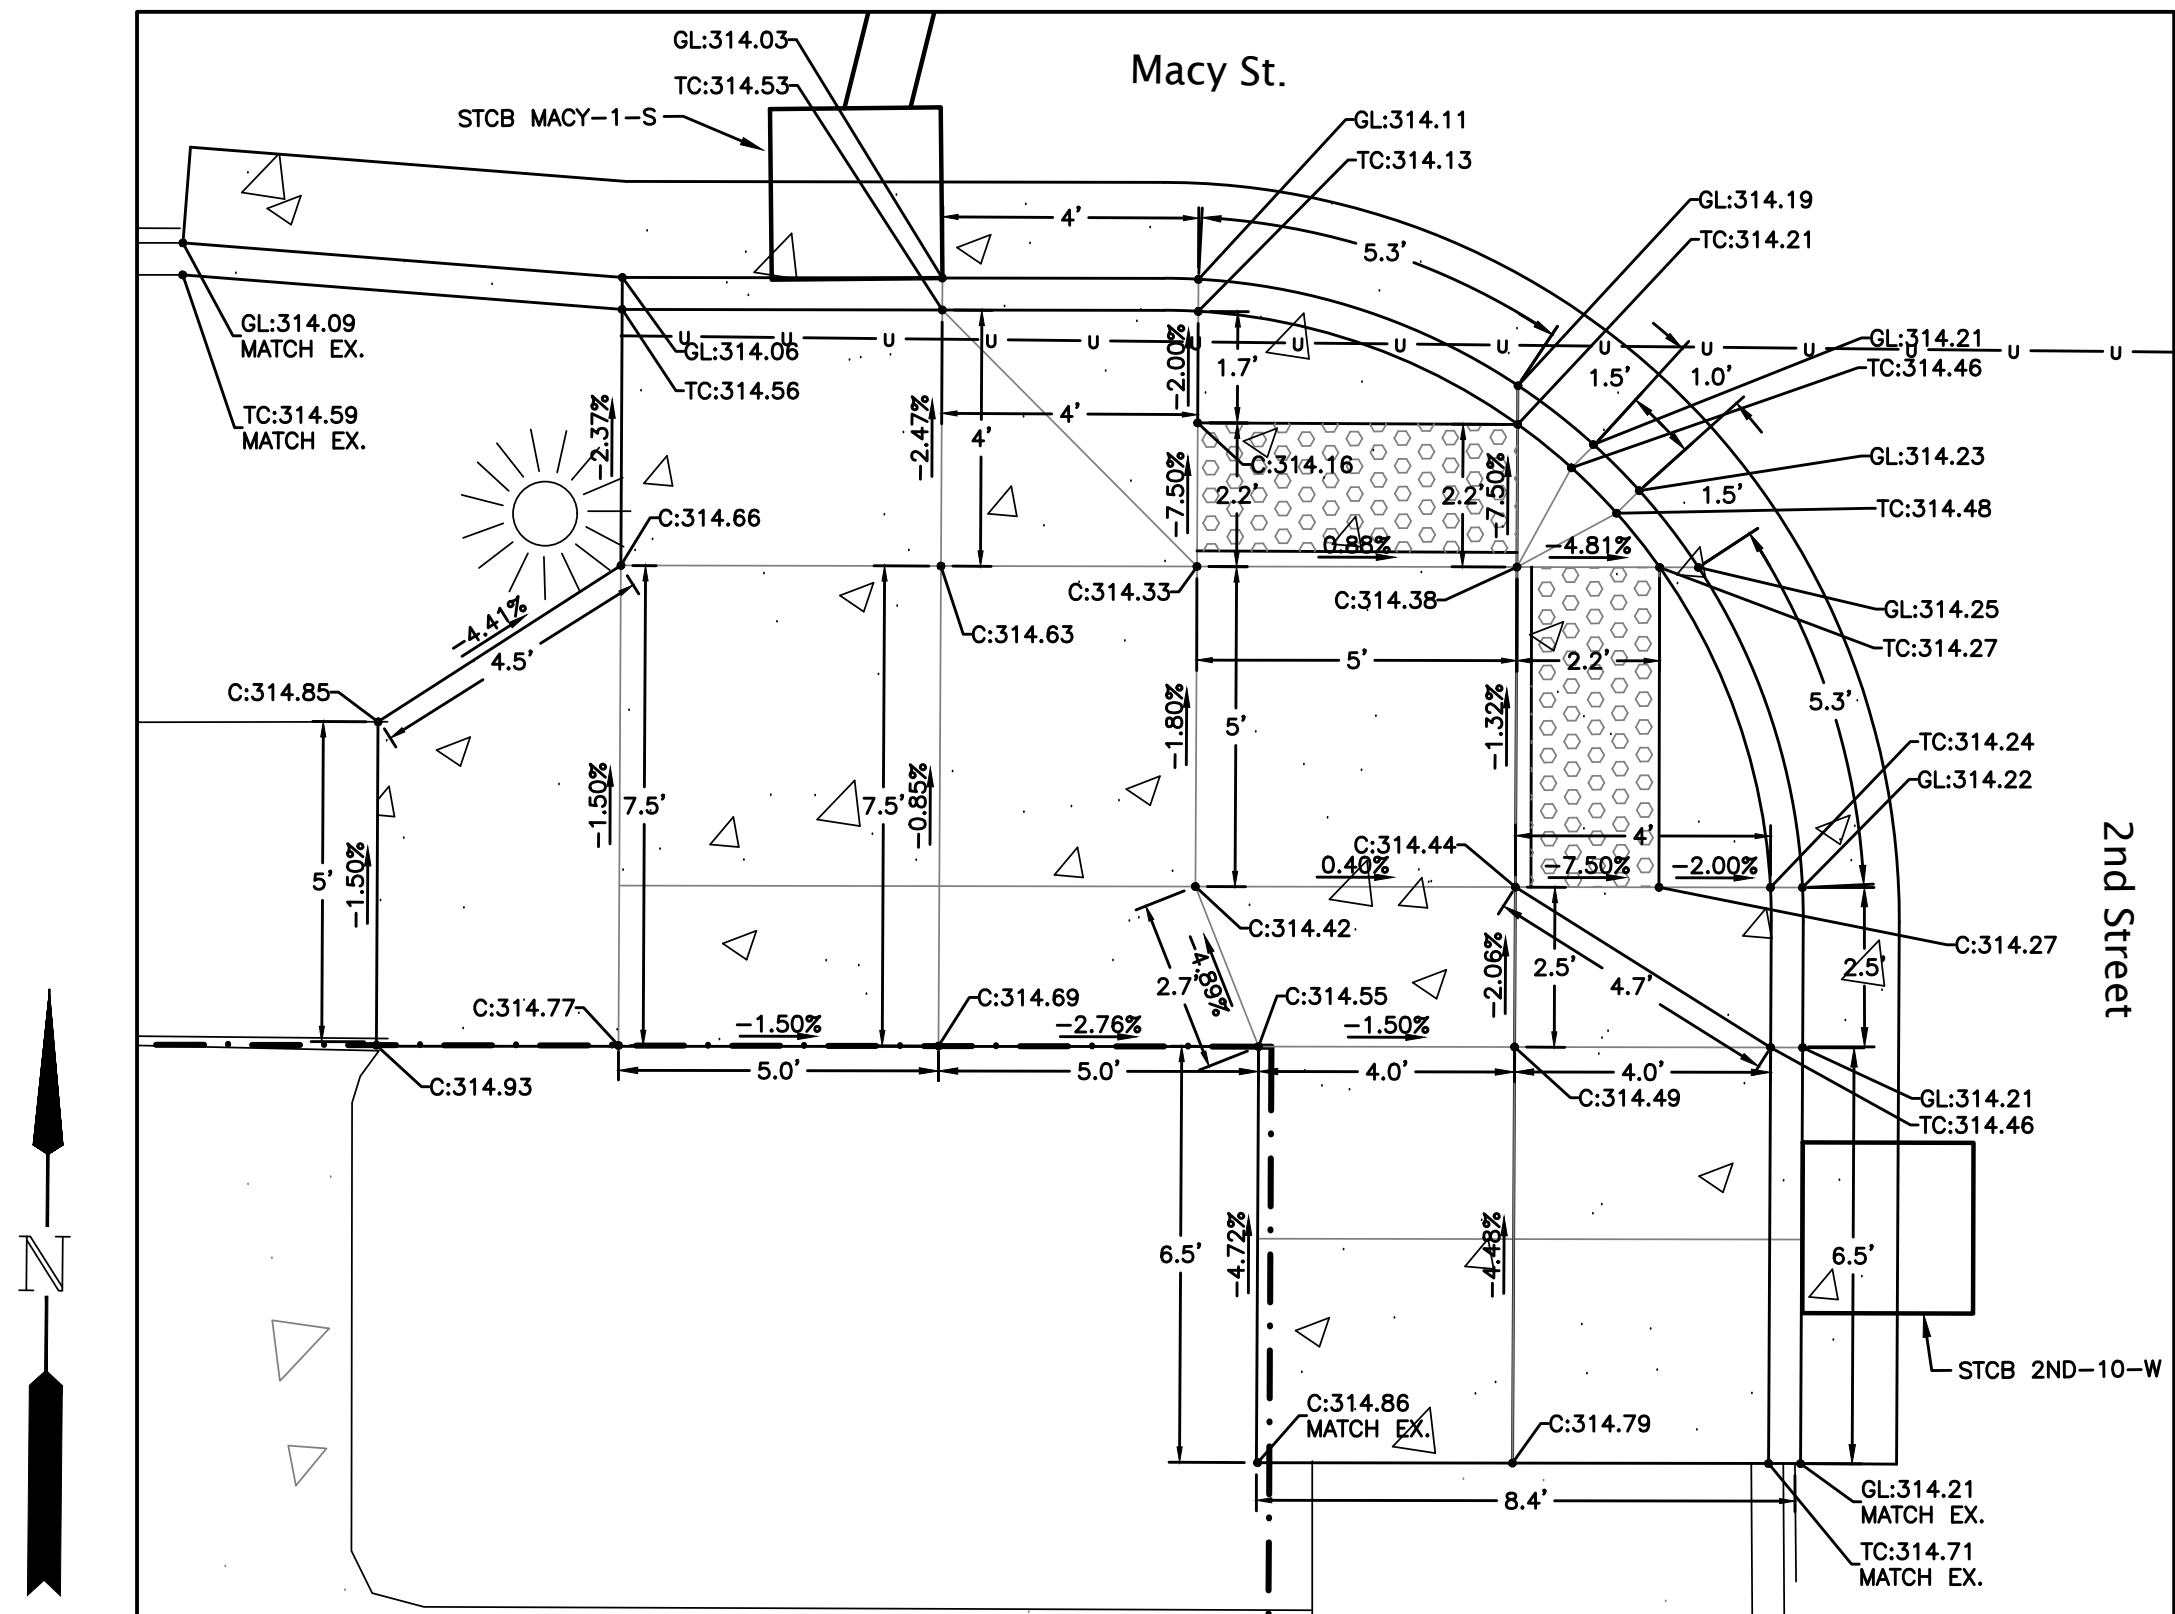

3 2nd & Macy - SW ADA Ramp
C15 SCALE: 1"=3'

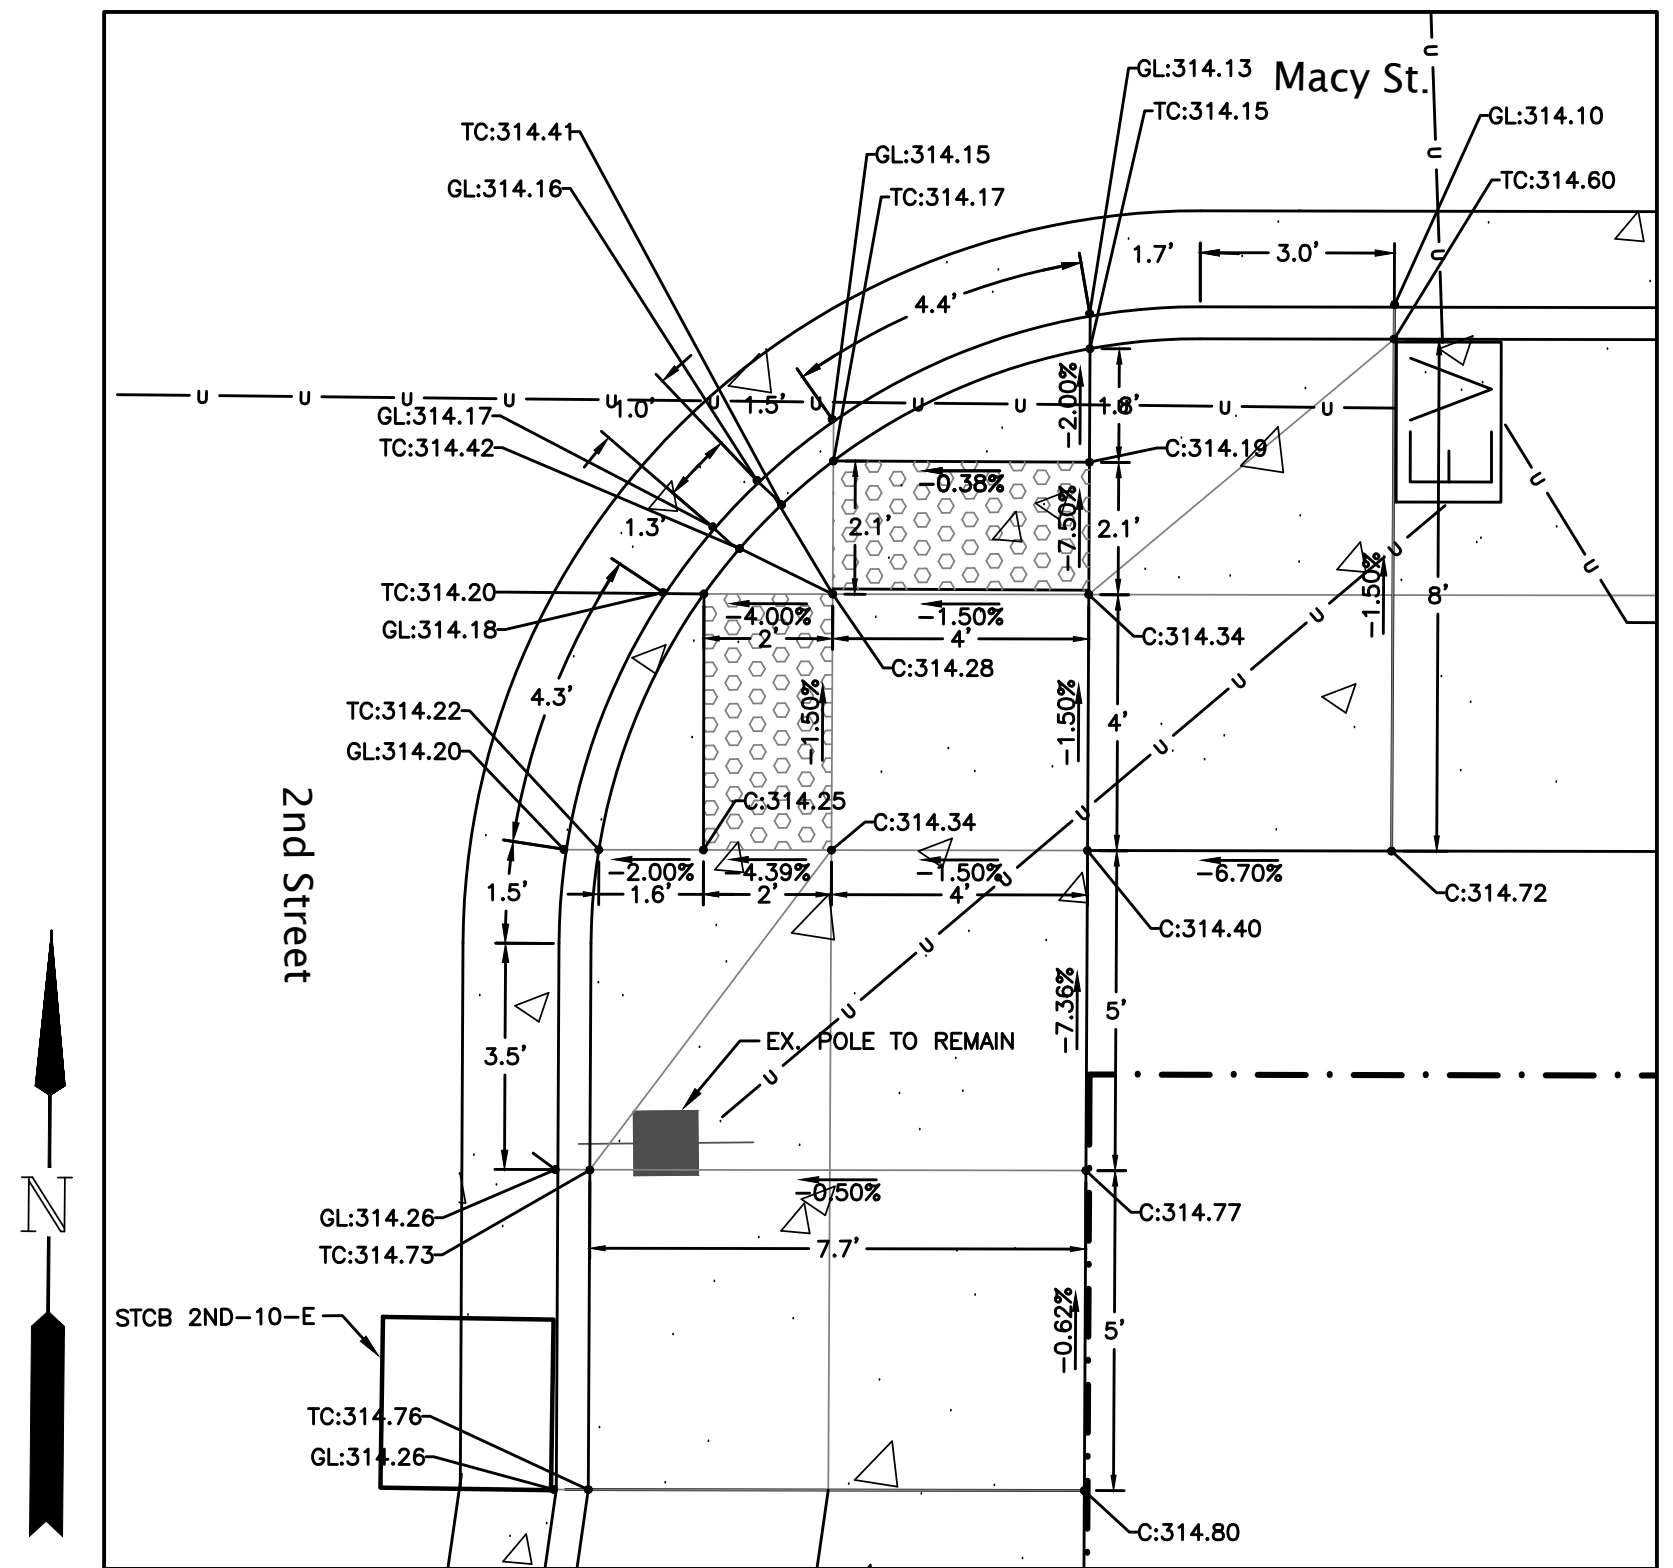

4 2nd & Macy - SE ADA Ramp
C15 SCALE: 1"=3'

project title:
**CITY OF HARRISBURG
Smith, Macy, & 2nd Street Rehabilitation**
Smith - 1st To 3rd, Macy - 2nd To 3rd, 2nd - Smith To Macy
HARRISBURG, OREGON

revisions:

date: JANUARY 28, 2020
drawn by: GAM
designer: GAM
project no: 17-009F

**Curb Return
ADA Ramp
Details**


sheet:

C15

Z:\2017\17-009F Harrisburg Smith Street\Drawing\17-009F Street Improvements.dwg / 2/8/2020 2:01 PM JLL/E


copyright © 2016 Branch Engineering, Inc.

ALTERNATE #1

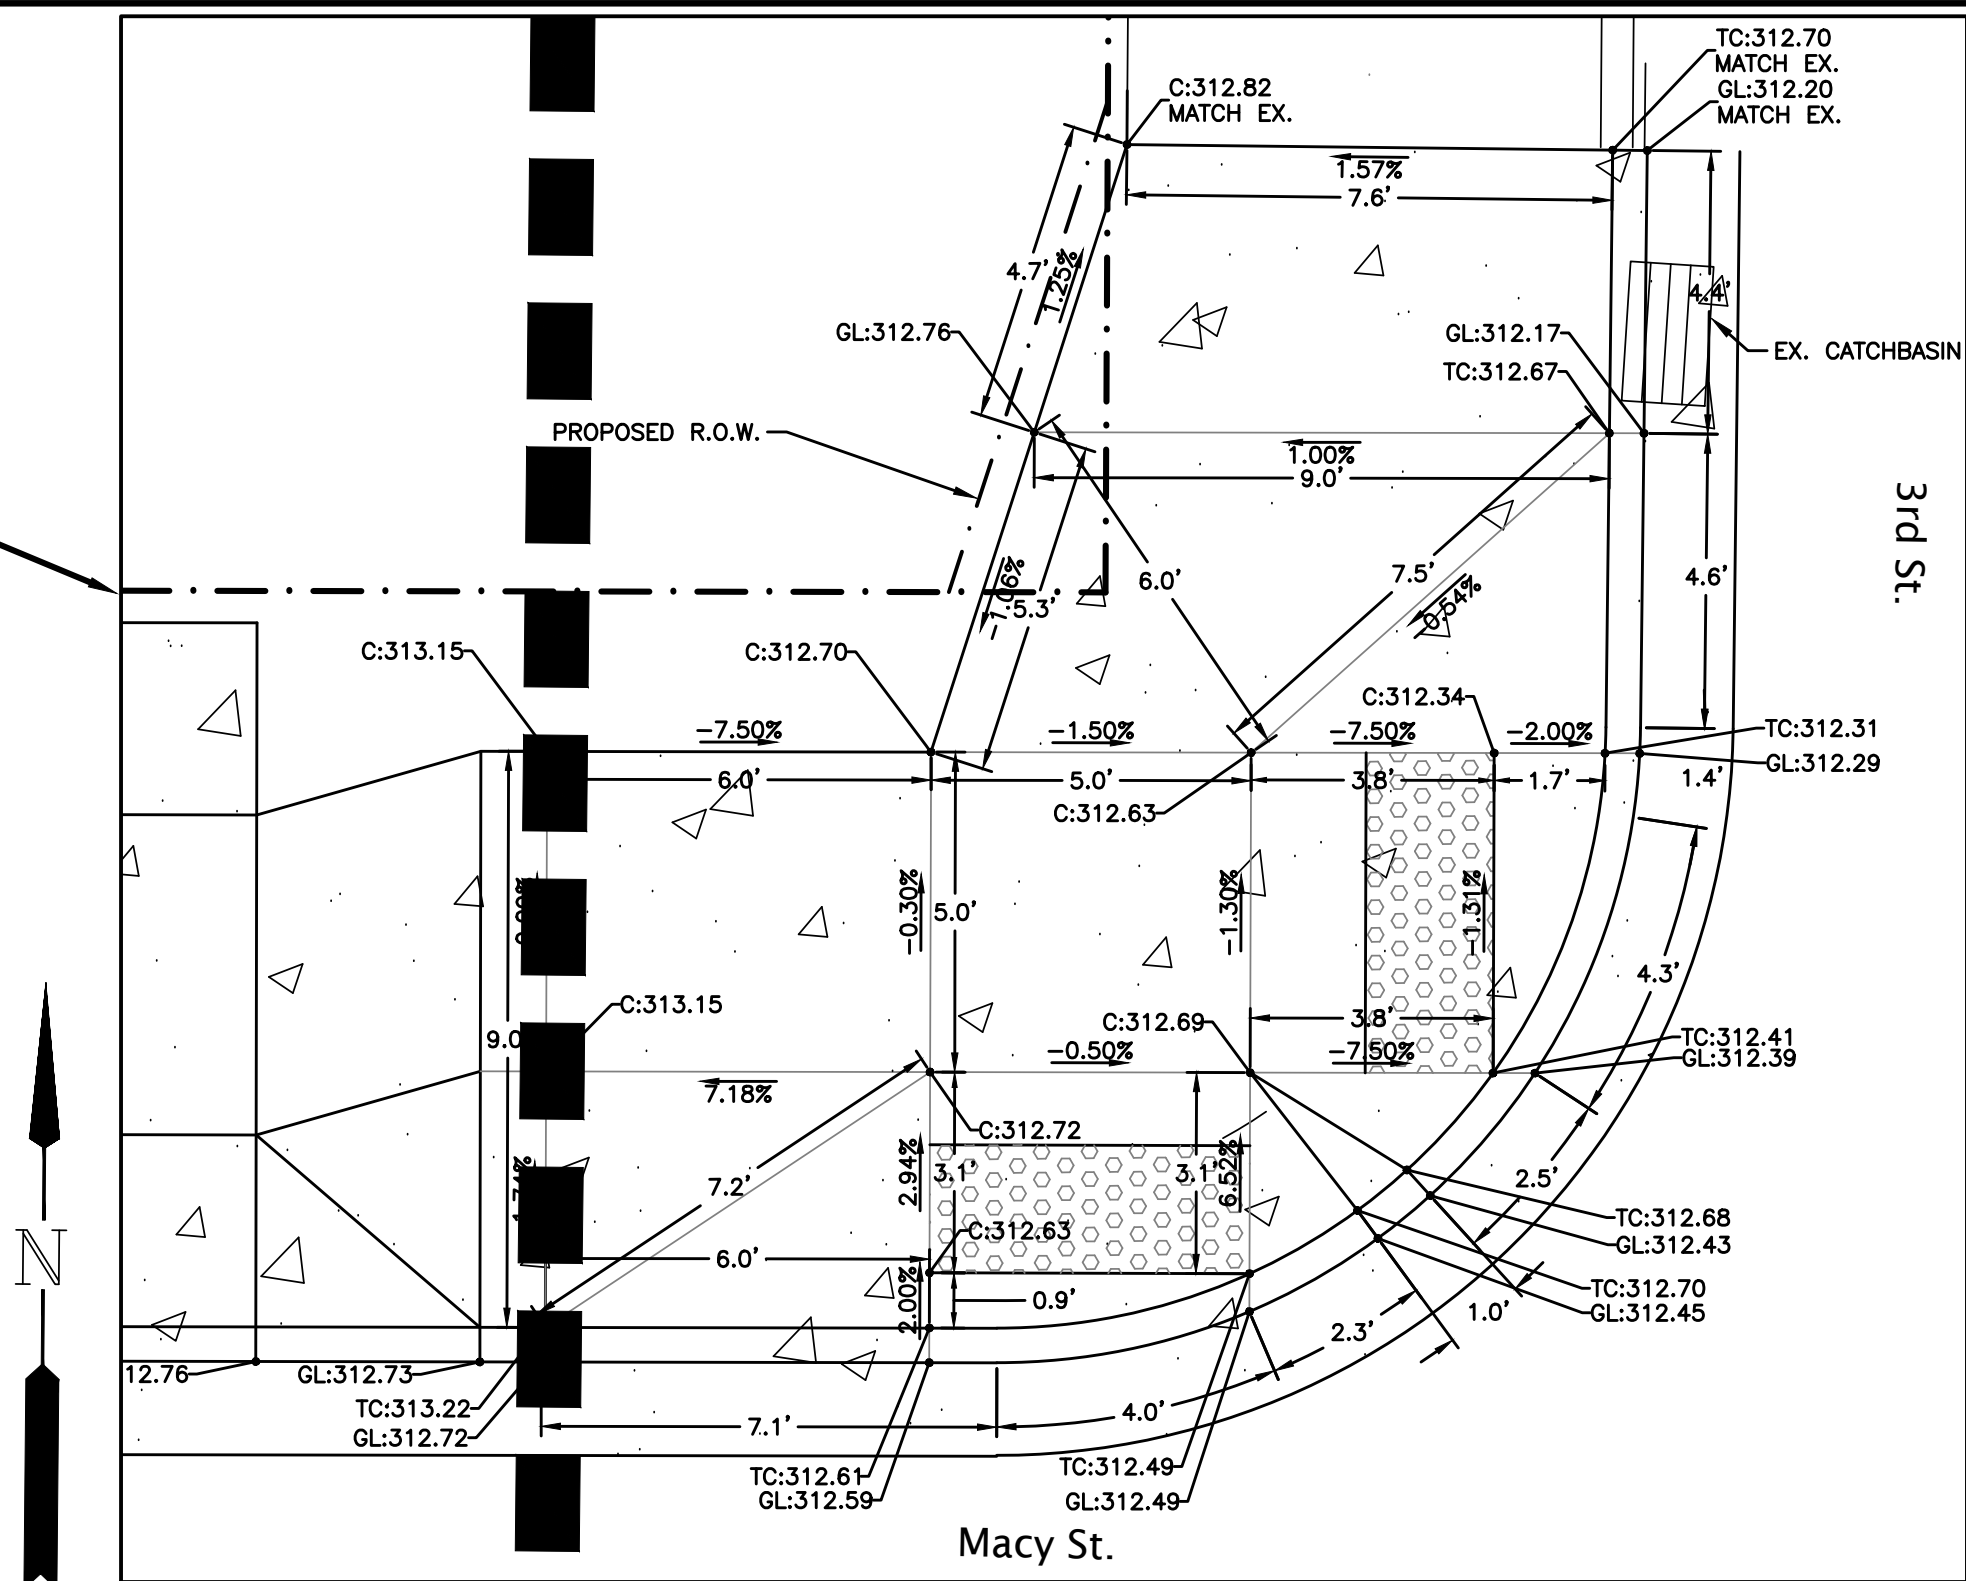


1
C16 SCALE: 1"=3'

ALTERNATE #1

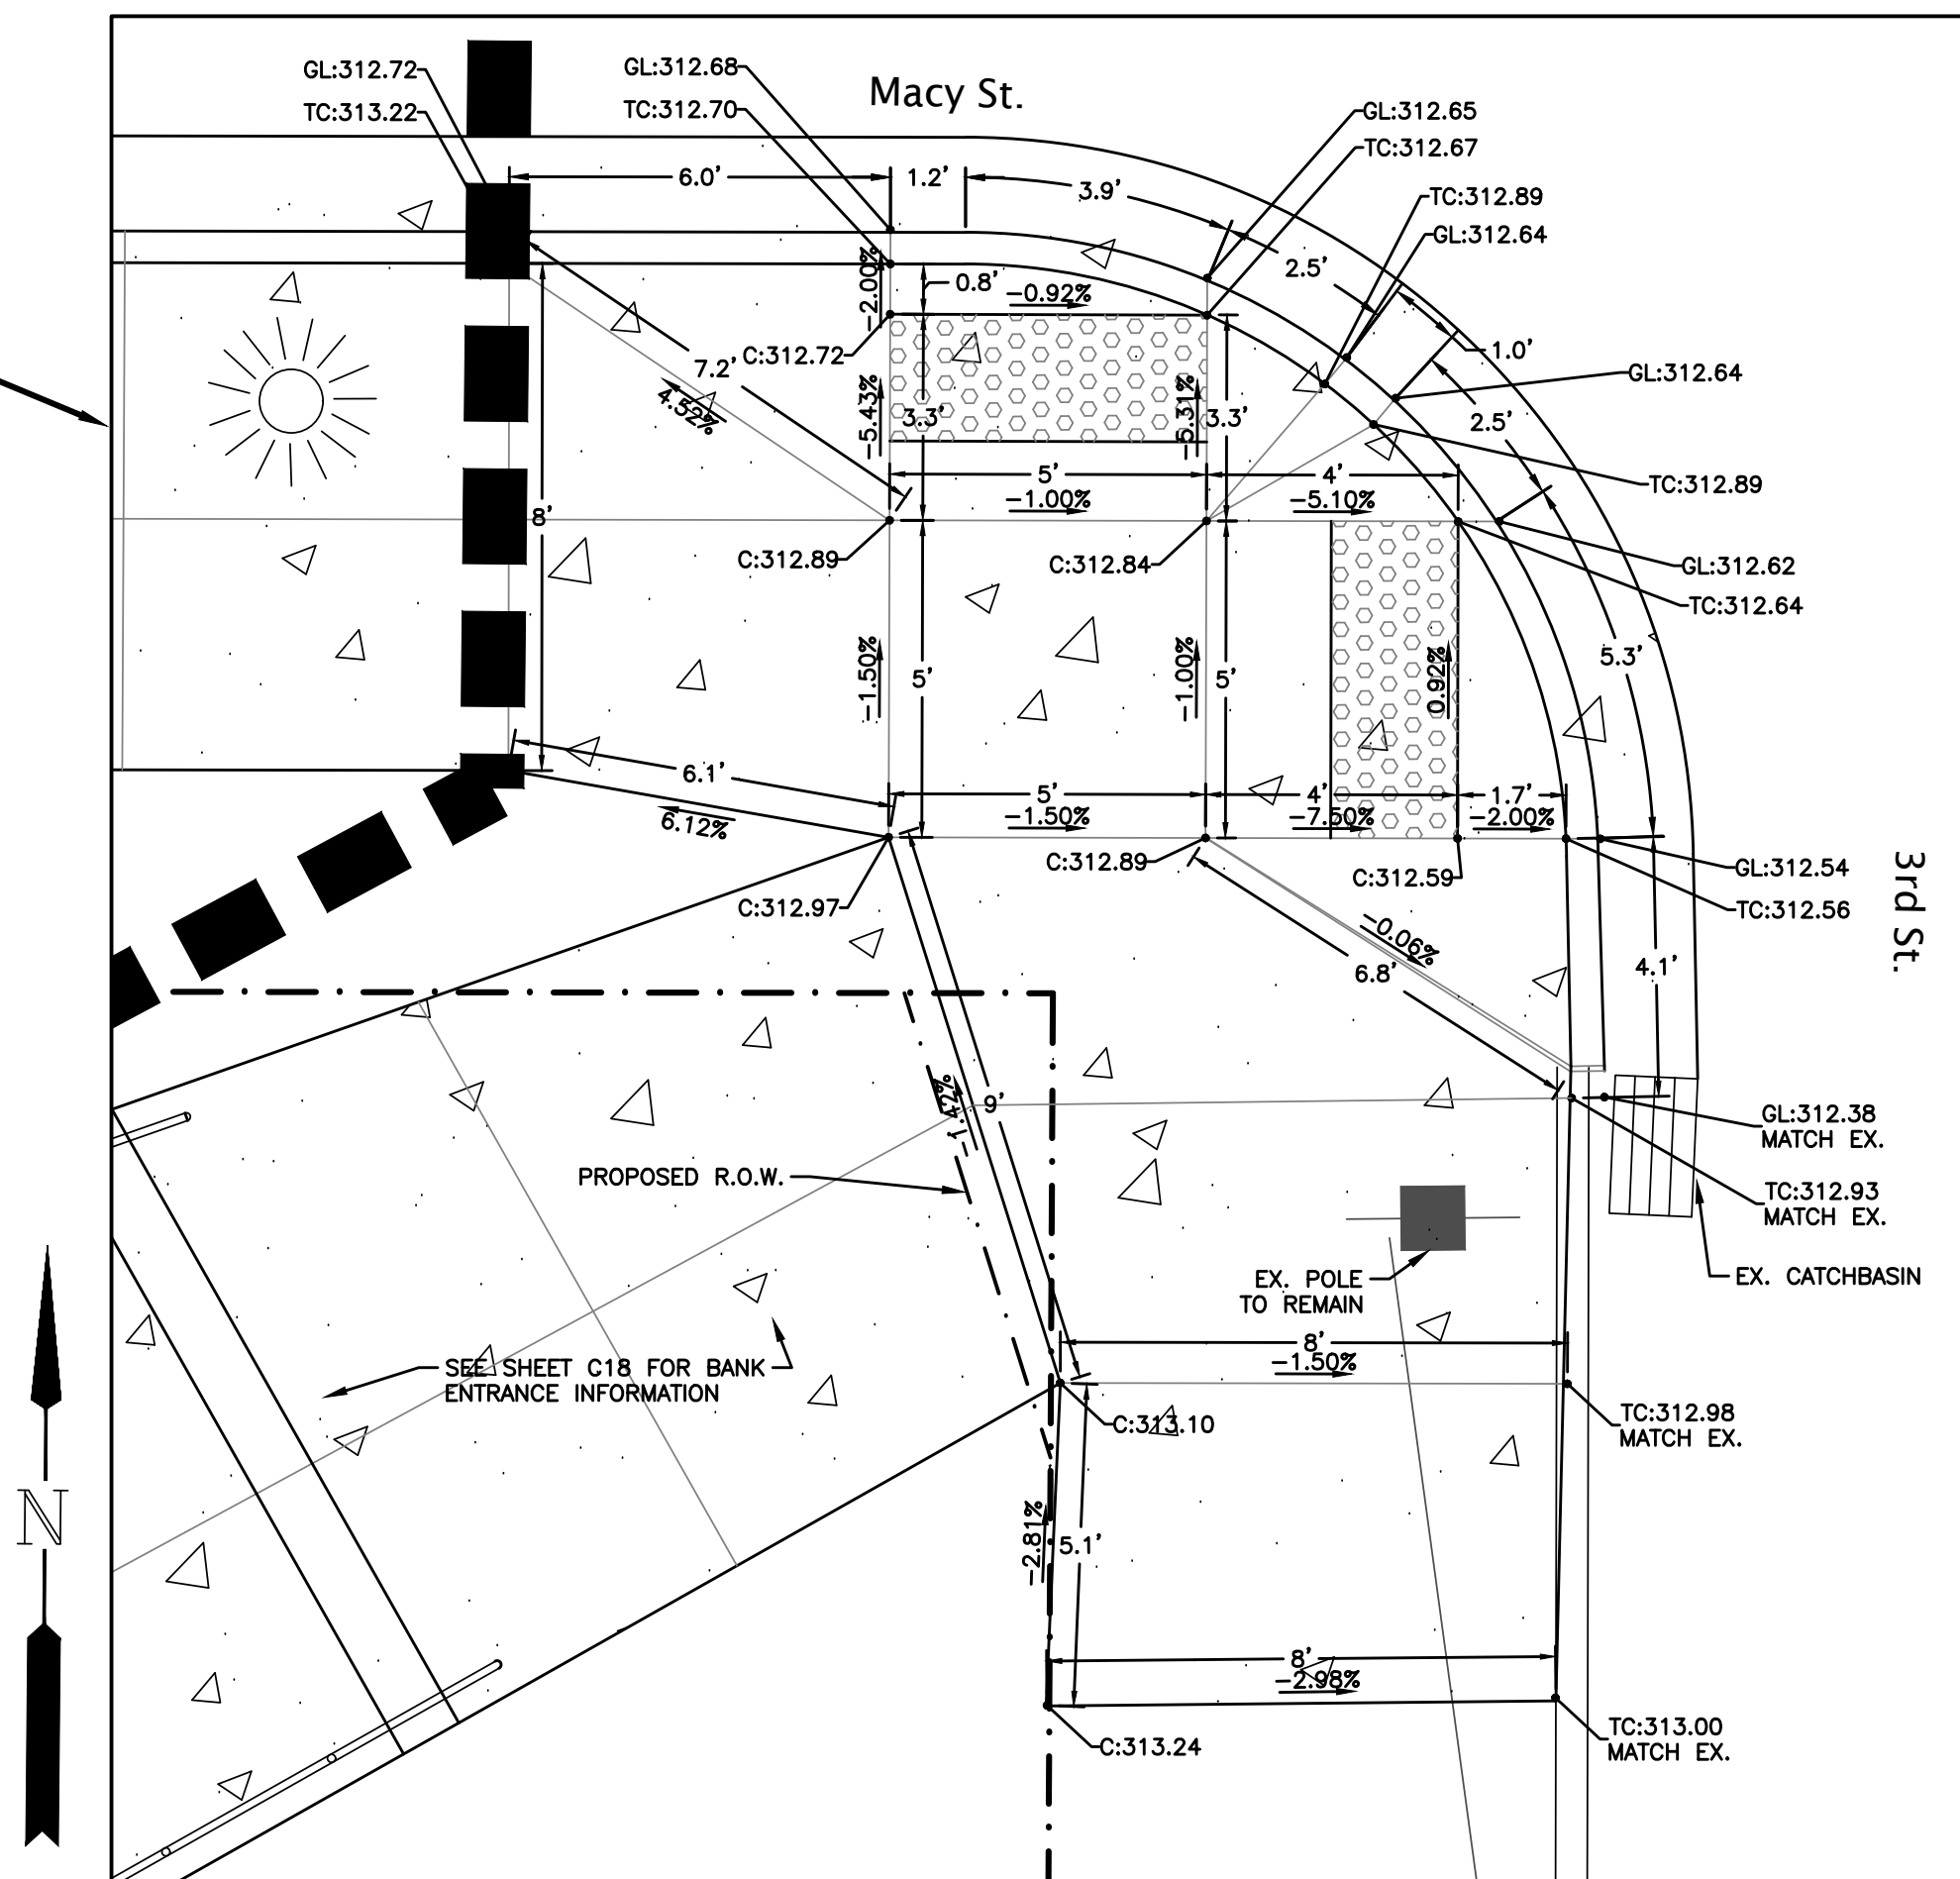


3
C16 SCALE: 1"=3'

ALTERNATE #1

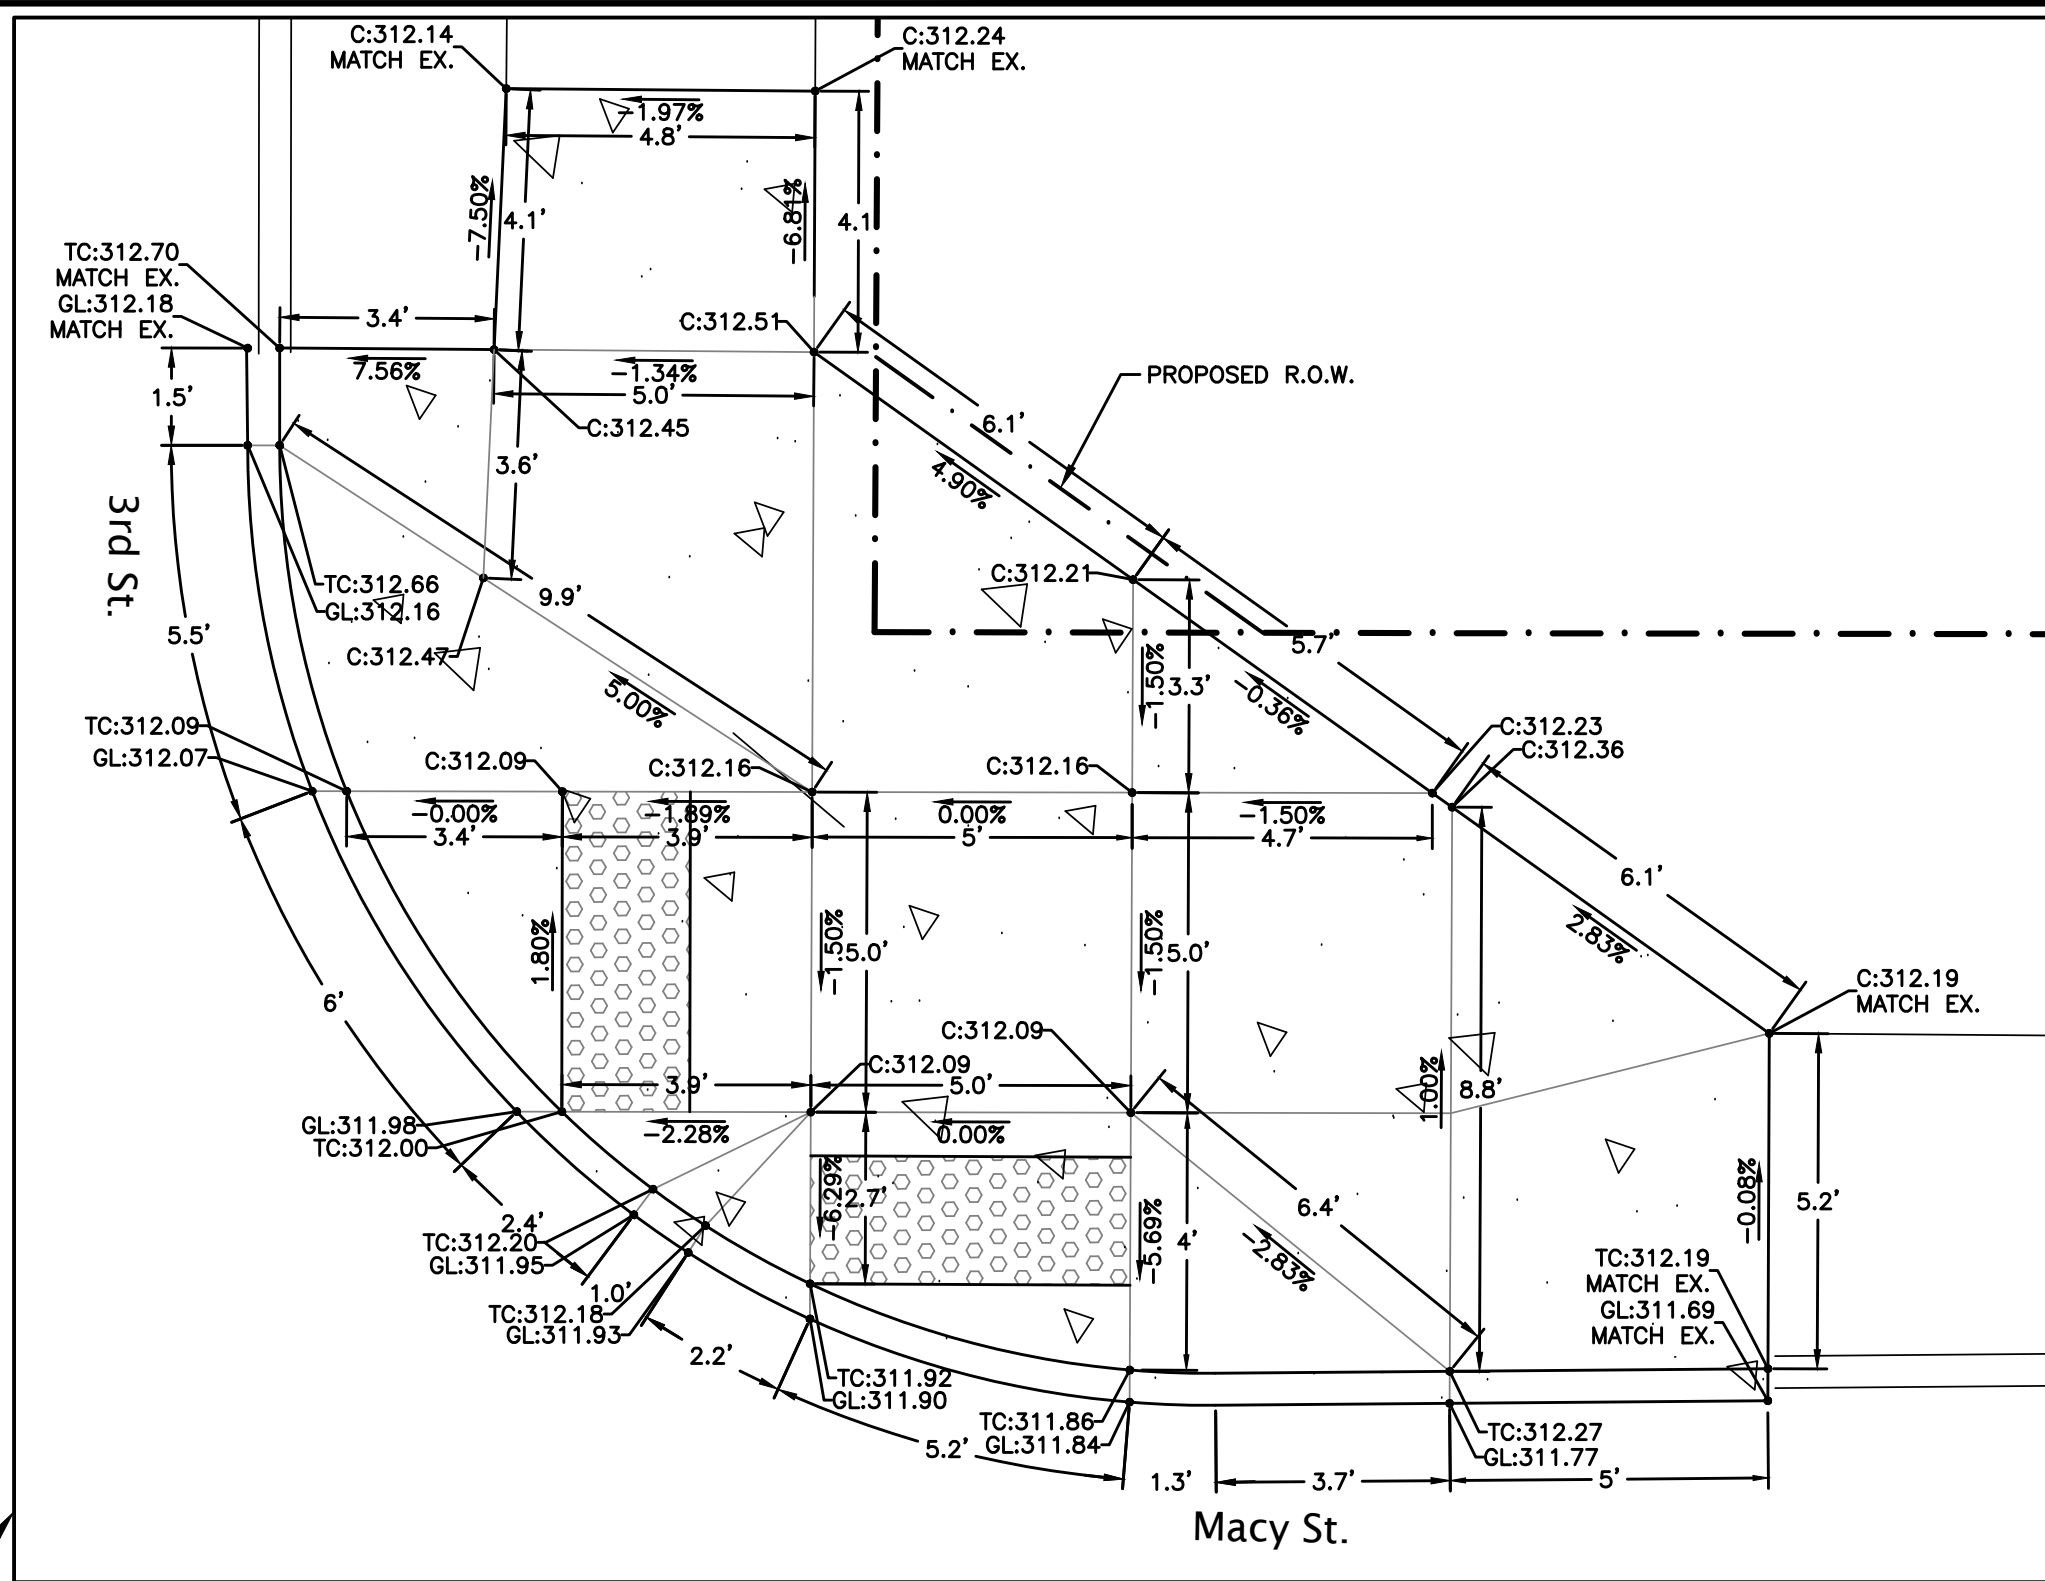

2
C16 SCALE: 1"=3'

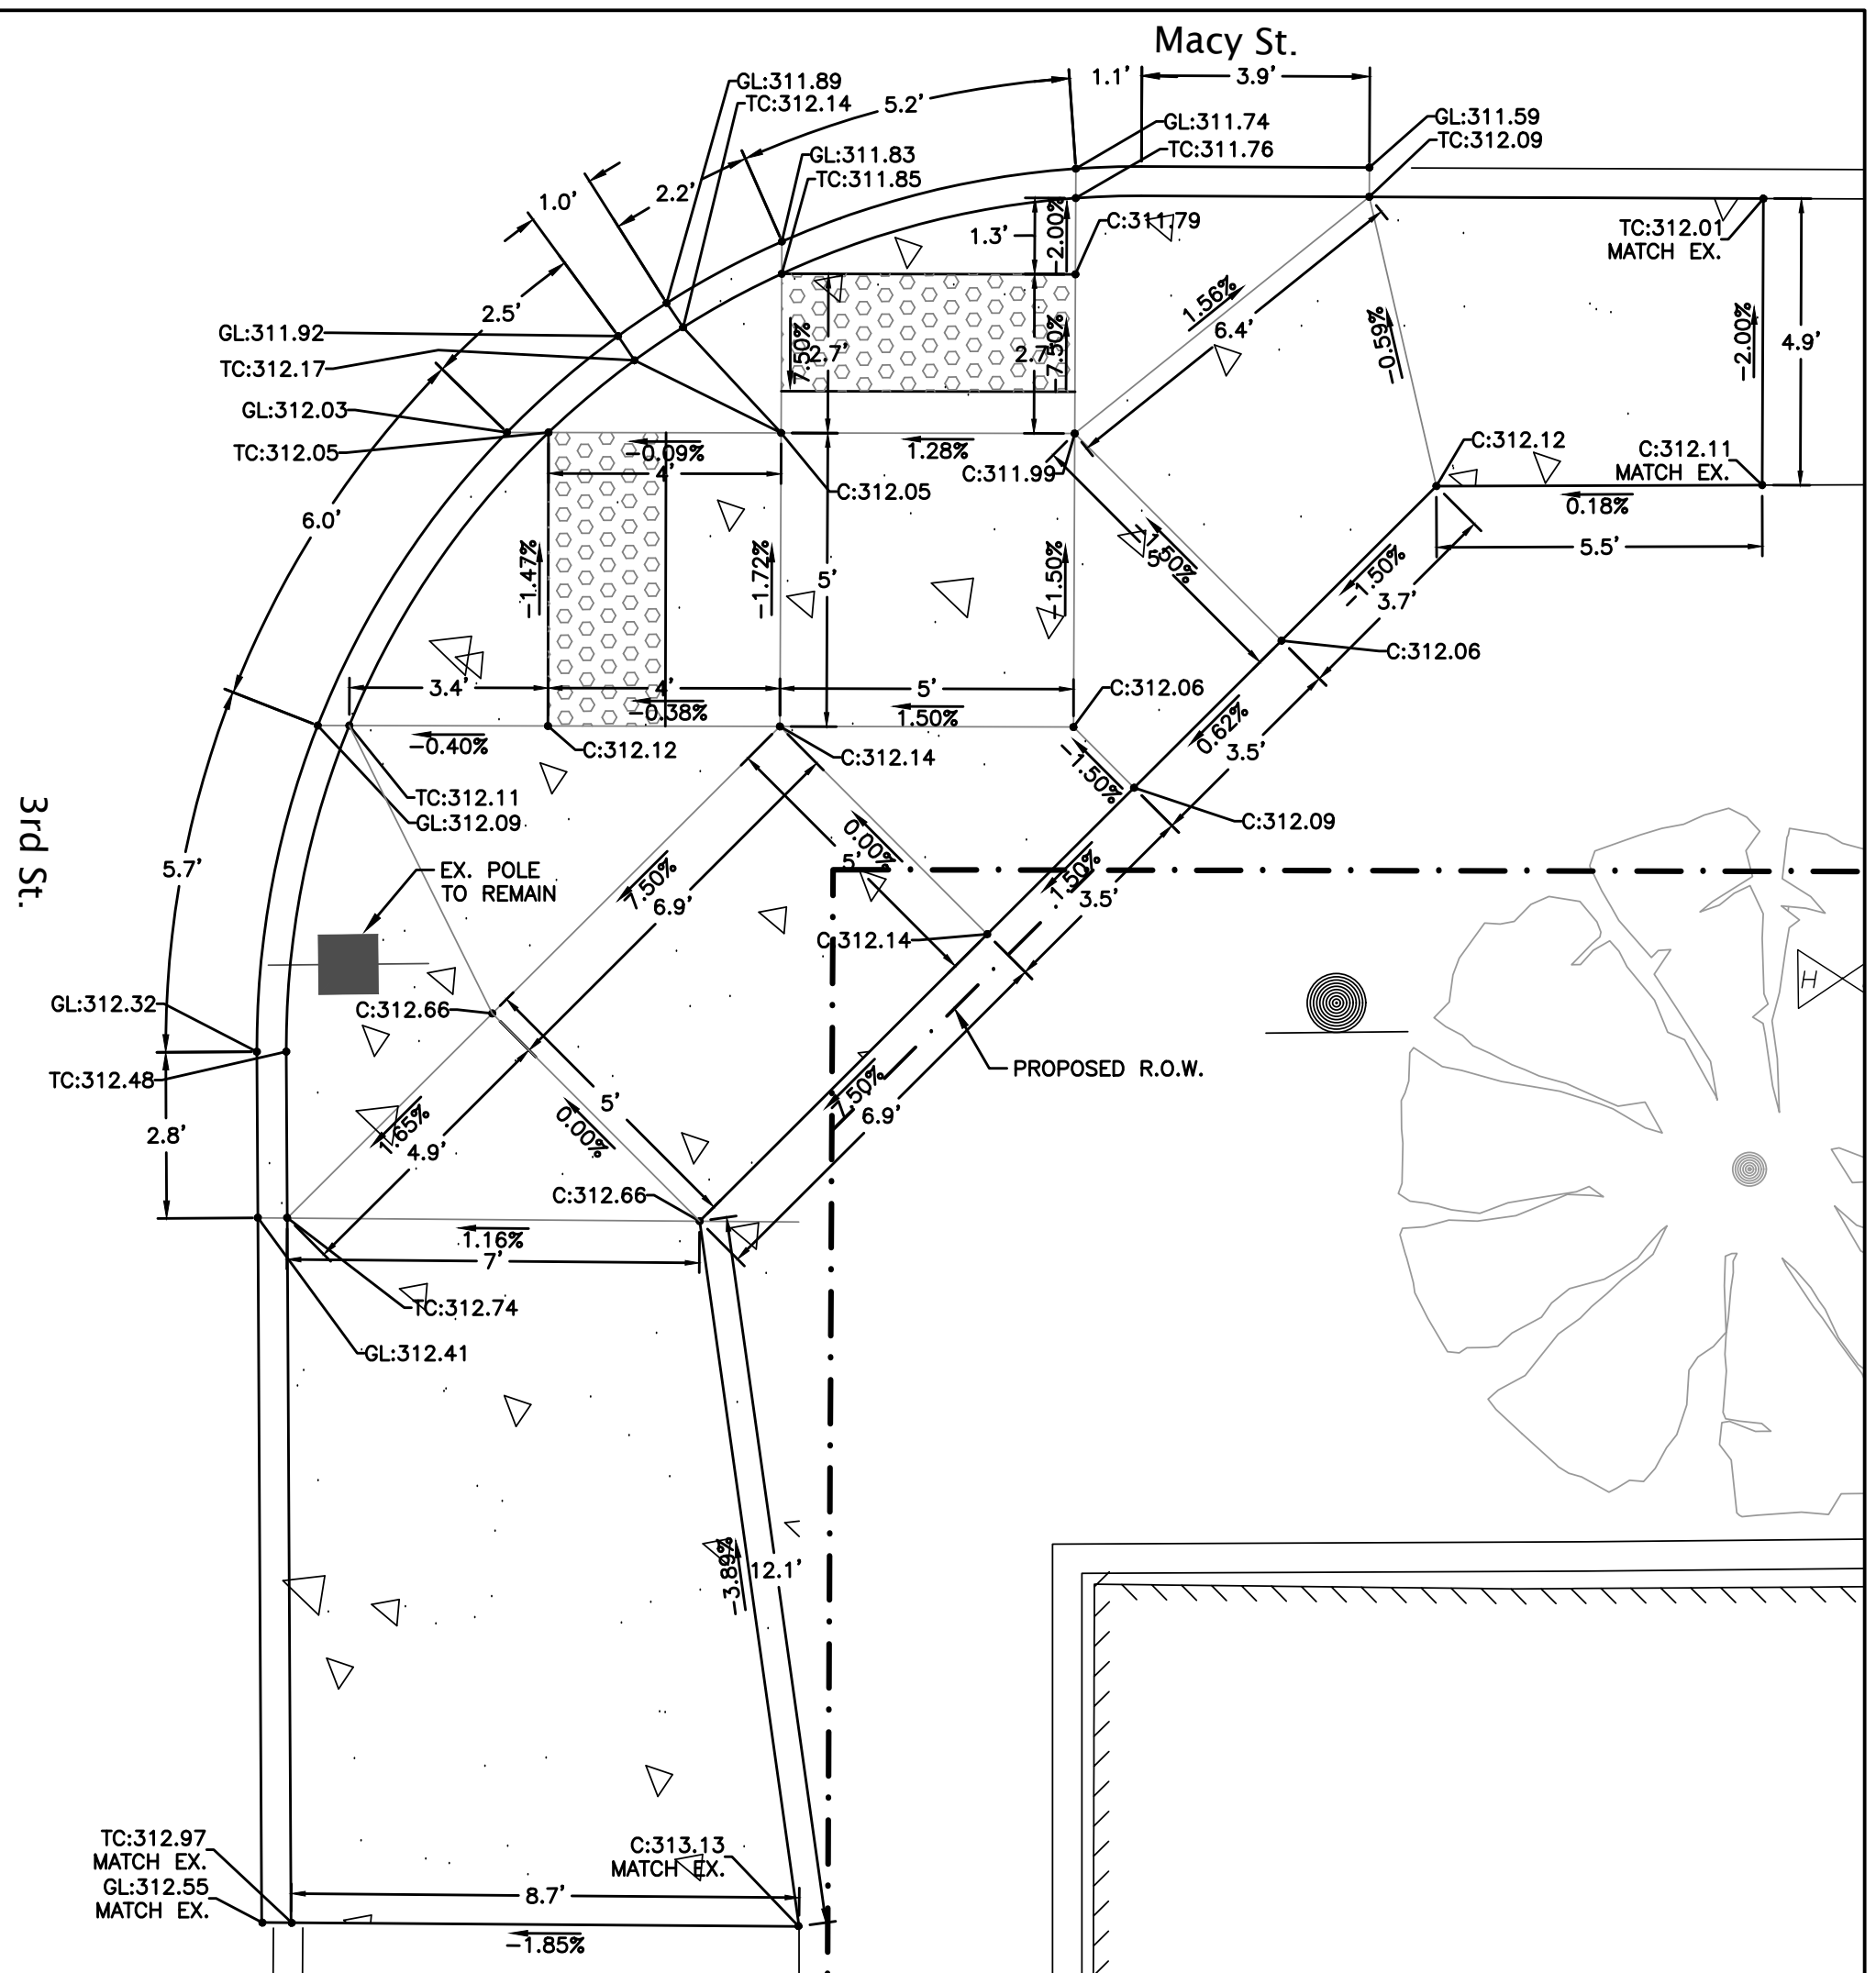

4
C16 SCALE: 1"=3'

EXPIRES: DECEMBER 31, 2020

project title:

CITY OF HARRISBURG Smith, Macy, & 2nd Street Rehabilitation

Smith - 1st To 3rd, Macy - 2nd To 3rd, 2nd - Smith To Macy
HARRISBURG, OREGON

revisions:

date: JANUARY 28, 2020
drawn by: GAM
designer: GAM
project no: 17-009F

Curb Return
ADA Ramp
Details

 
sheet:

C16



visions:

C17



1. CONTRACTOR TO VERIFY ALL DIMENSIONS PRIOR TO CONSTRUCTION.
2. USE ASTM A36 STEEL FOR PLATES
3. USE ASTM A53 GRADE B STEEL FOR PIPE SECTIONS
4. USE 70xx WELD ELECTRODES
5. USE TAMPER RESISTANT FASTENERS W/ STRENGTH AND DURABILITY SPECIFICATIONS MEETING OR EXCEEDING THOSE OF ASTM A307.
6. PROVIDE SPECIAL INSPECTIONS FOR STRUCTURAL WELDING AND ANCHOR INSTALLATION.
7. ALL RAIL & FASTENER COMPONENTS TO BE HOT DIPPED GALVANIZED IN ACCORDANCE W/ ASTM A123 & A153, U.N.O.
8. FIELD REPAIR ALL DAMAGED GALVANIZING AS REQUIRED AFTER CONSTRUCTION IN ACCORDANCE WITH ASTM A780.

project title:

CITY OF HARRISBURG
Smith, Macy, & 2nd Street Rehabilitation
Smith - 1st To 3rd, Macy - 2nd To 3rd, 2nd - Smith To Macy
HARRISBURG, OREGON


revisions:

date: JANUARY 28, 2020
drawn by: GAM
designer: GAM
project no: 17-009F


Macy Key Bank
Entrance Stairs &
Handrail Details
Alternate #1

sheet:


C18

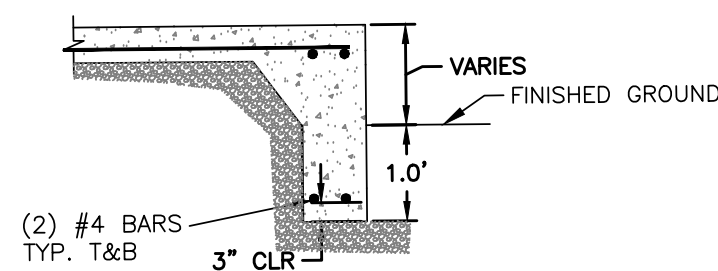

SECTION A-A
SCALE: N.T.S.

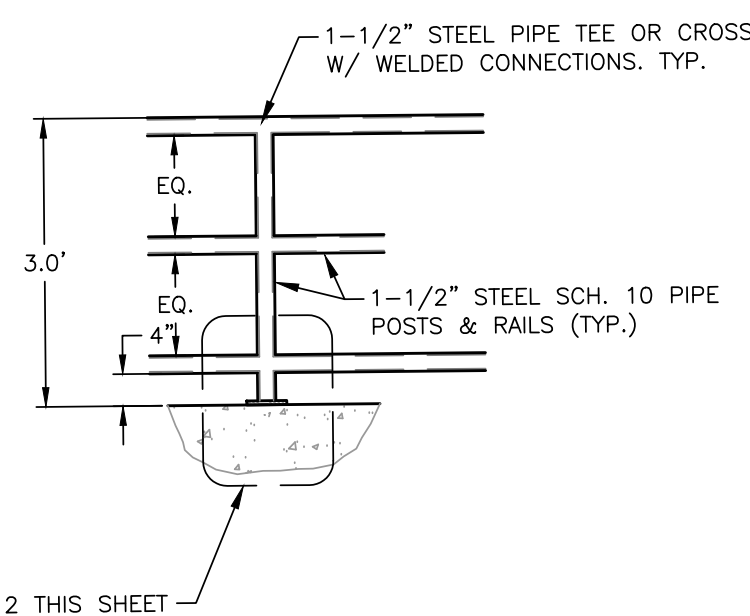


1 Macy Key Bank - Detail 1
SCALE: 1"=2"

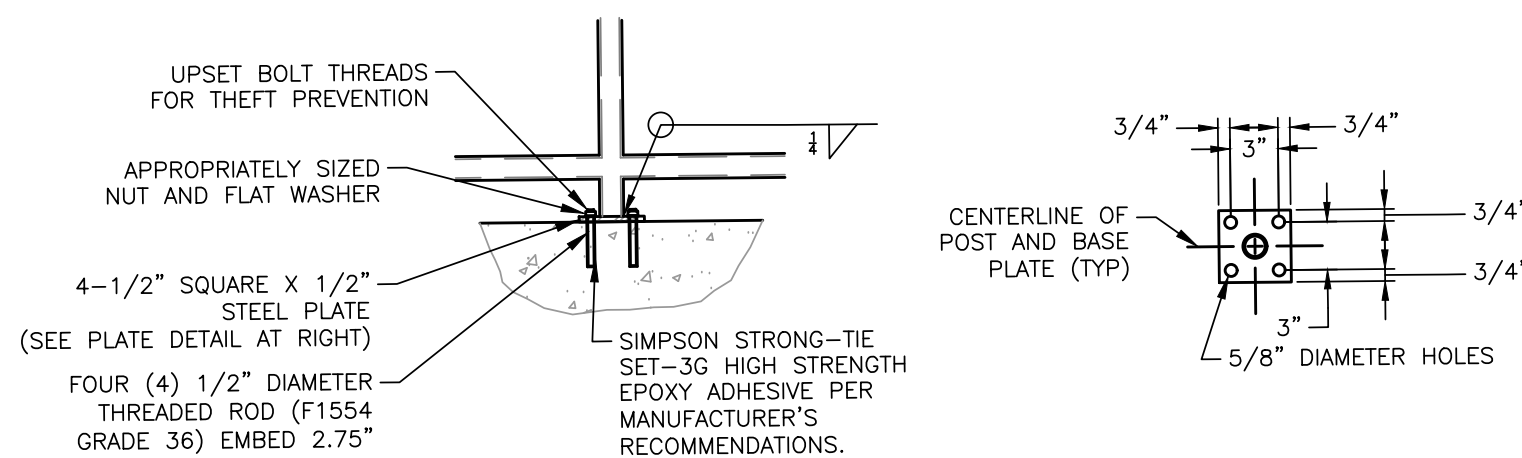


2 Macy Key Bank - Detail 2
SCALE: 1"=1'

STEEL FRAMING NOTES:


1. CONTRACTOR TO VERIFY ALL DIMENSIONS PRIOR TO CONSTRUCTION.
2. USE ASTM A36 STEEL FOR PLATES
3. USE ASTM A53 GRADE B STEEL FOR PIPE SECTIONS
4. USE 70xx WELD ELECTRODES
5. USE TAMPER RESISTANT FASTENERS W/ STRENGTH AND DURABILITY SPECIFICATIONS MEETING OR EXCEEDING THOSE OF ASTM A307.
6. PROVIDE SPECIAL INSPECTIONS FOR STRUCTURAL WELDING AND ANCHOR INSTALLATION.
7. ALL RAIL & FASTENER COMPONENTS TO BE HOT DIPPED GALVANIZED IN ACCORDANCE W/ ASTM A123 & A153, U.N.O.
8. FIELD REPAIR ALL DAMAGED GALVANIZING AS REQUIRED AFTER CONSTRUCTION IN ACCORDANCE WITH ASTM A780.

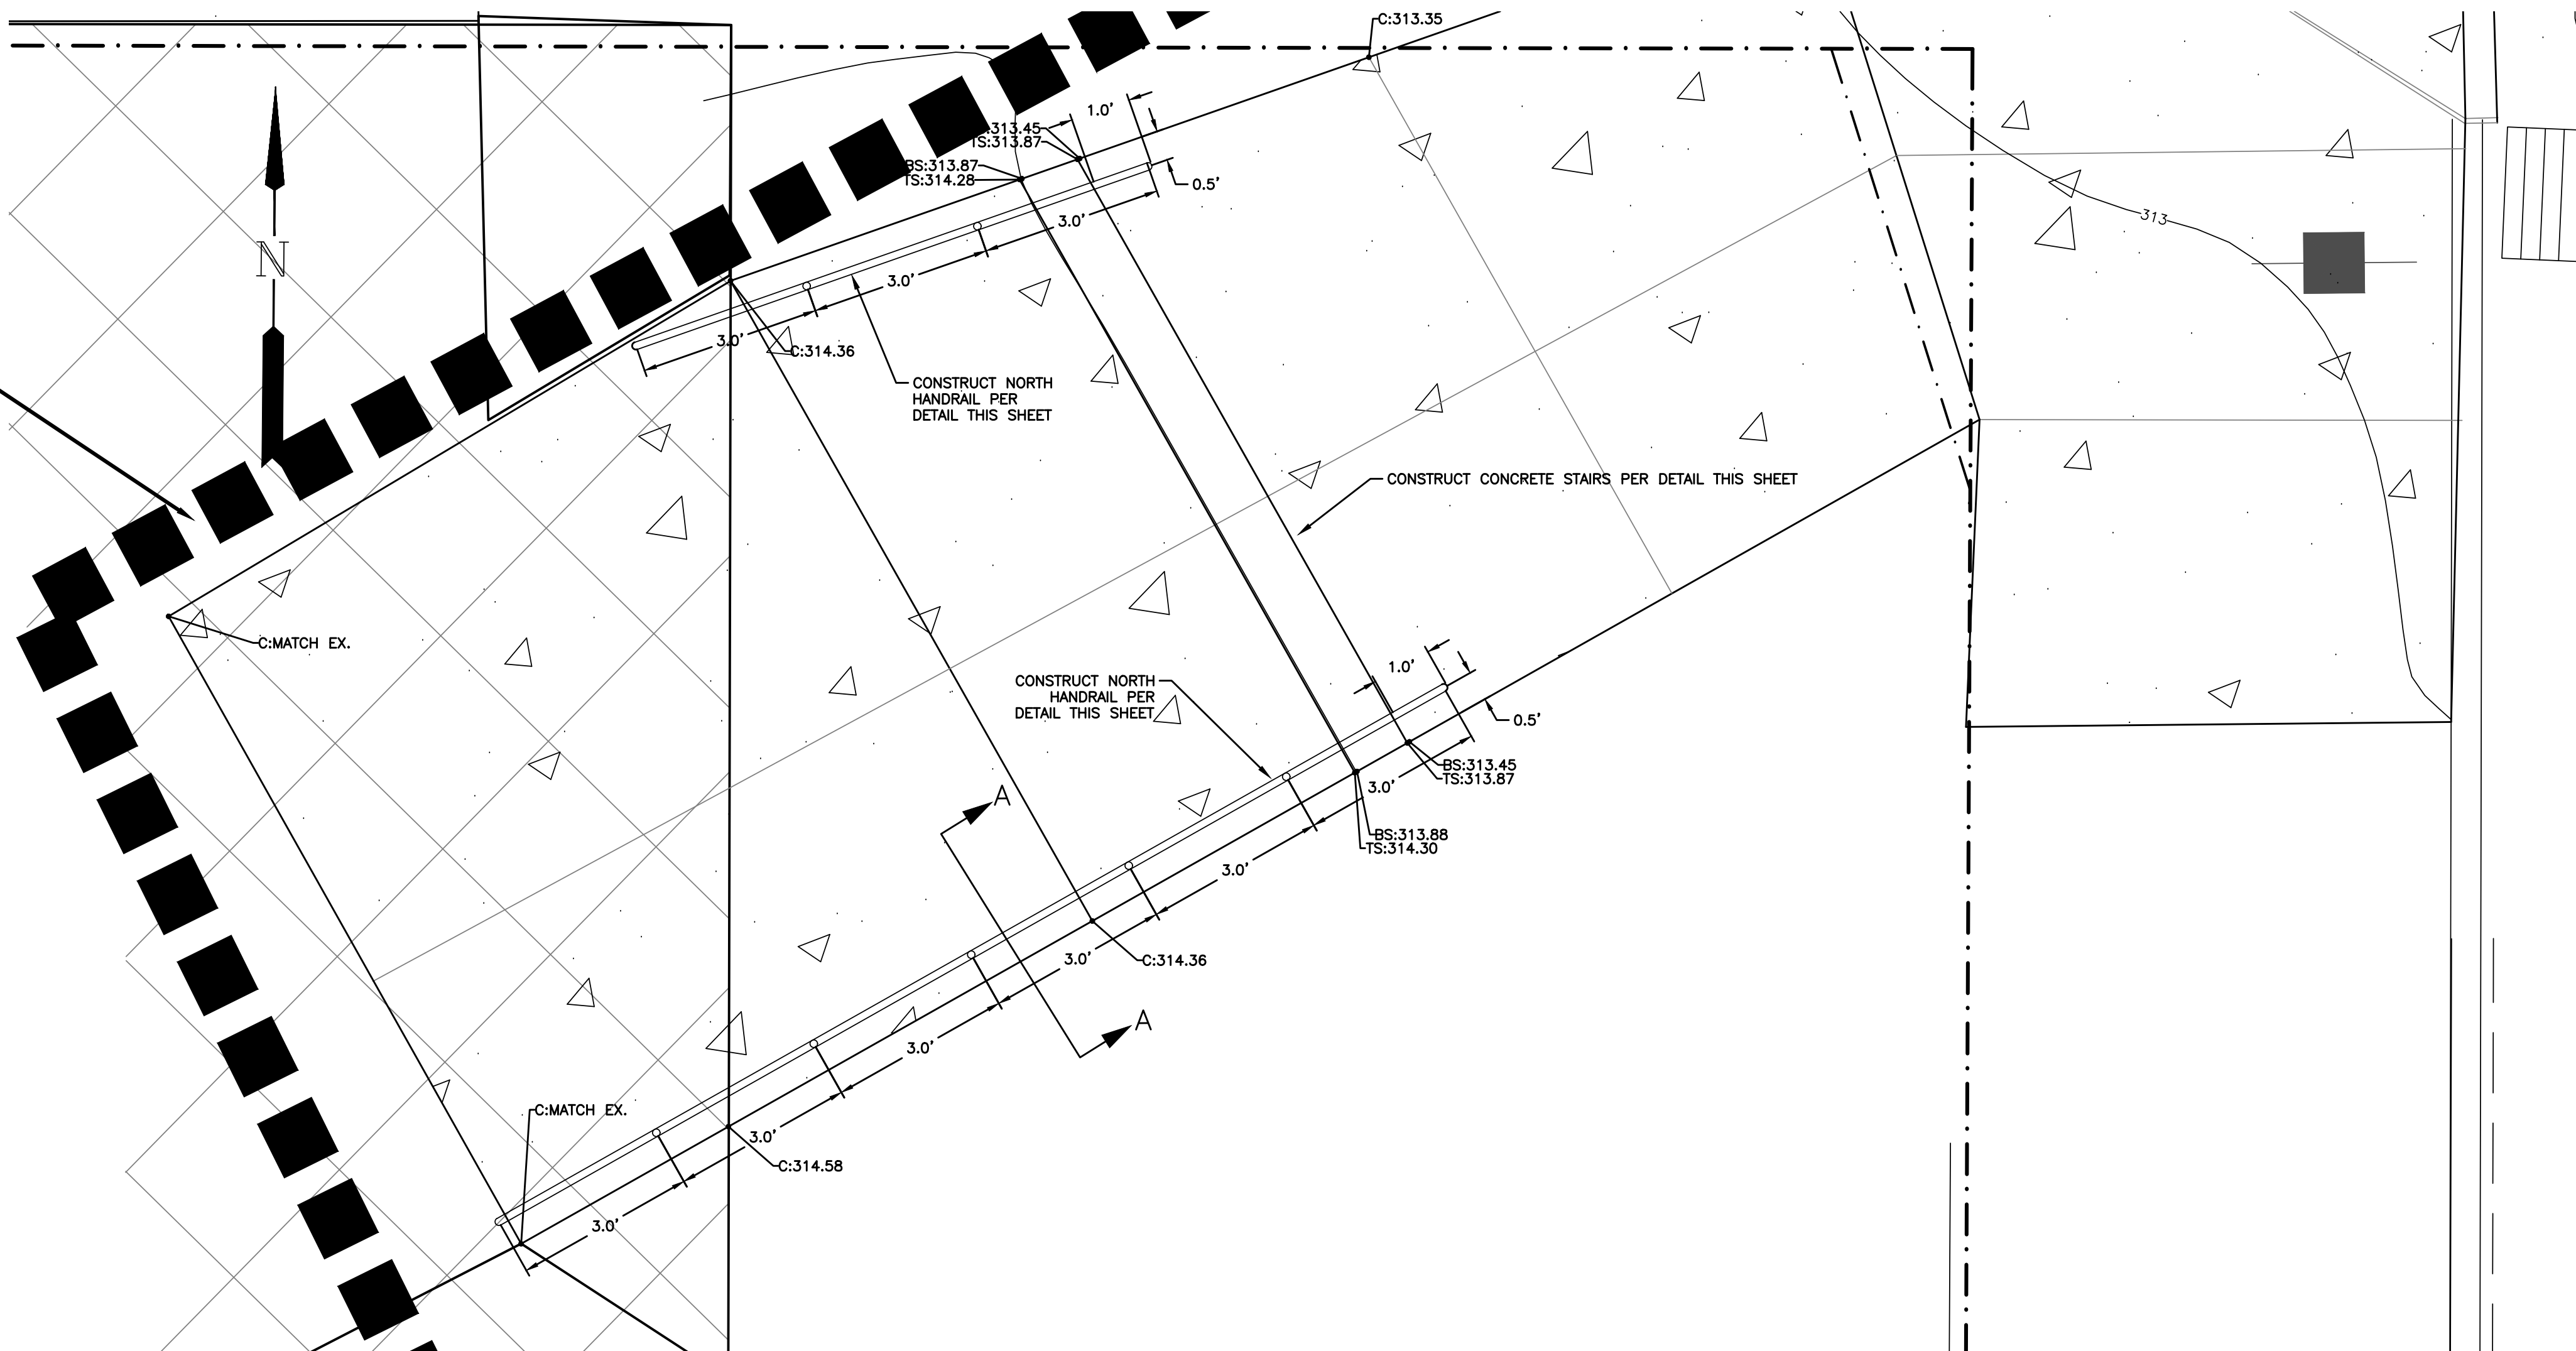


Plan C18
Macy Key Bank - Existing Ramp & New Hand Rail
SCALE: 1"=2"

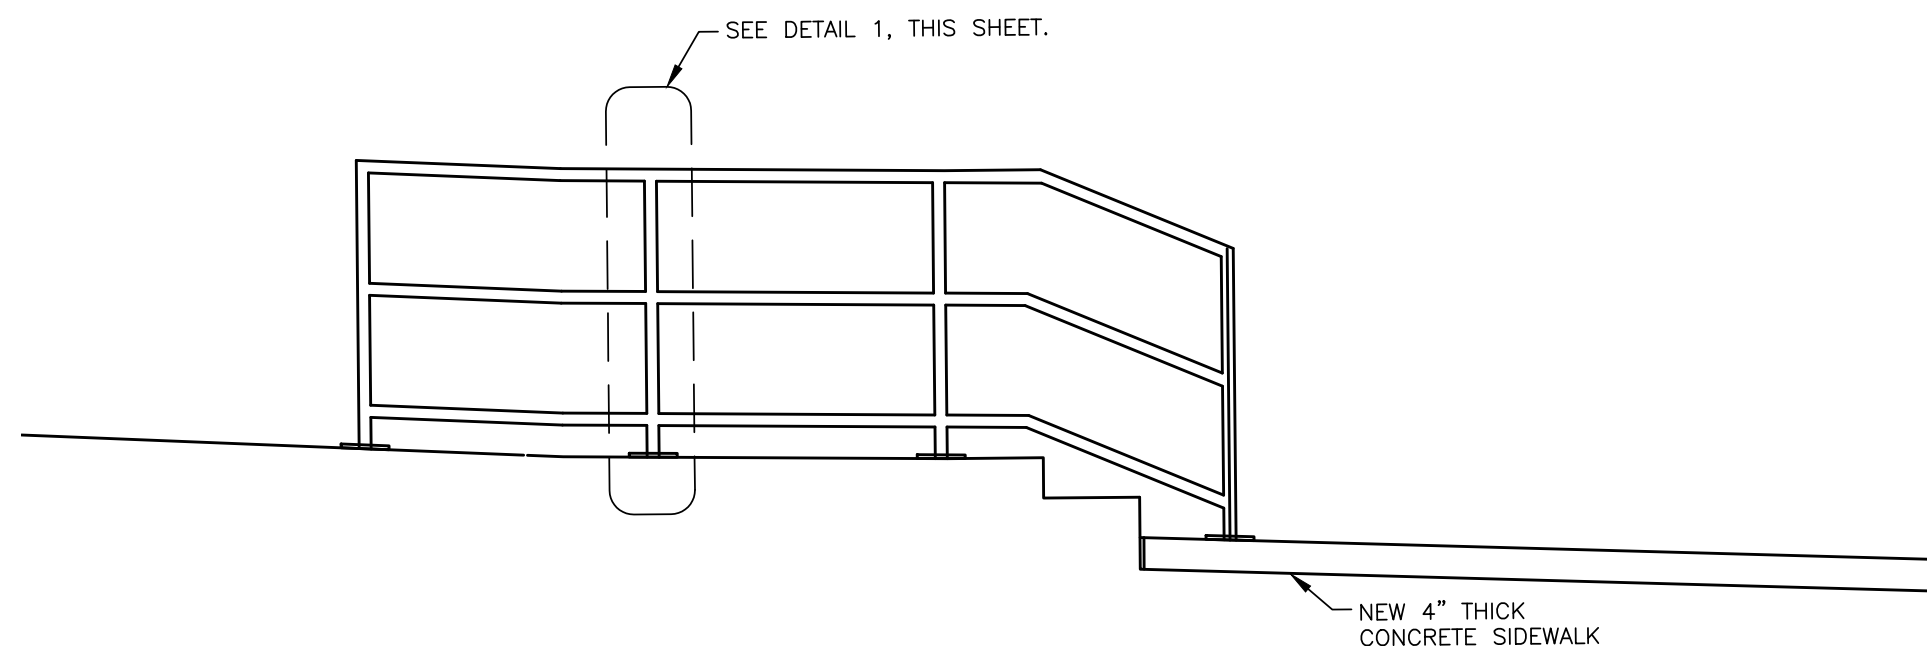

Elev C18
Macy Key Bank - North Hand Rail Elevation
SCALE: 1"=2"

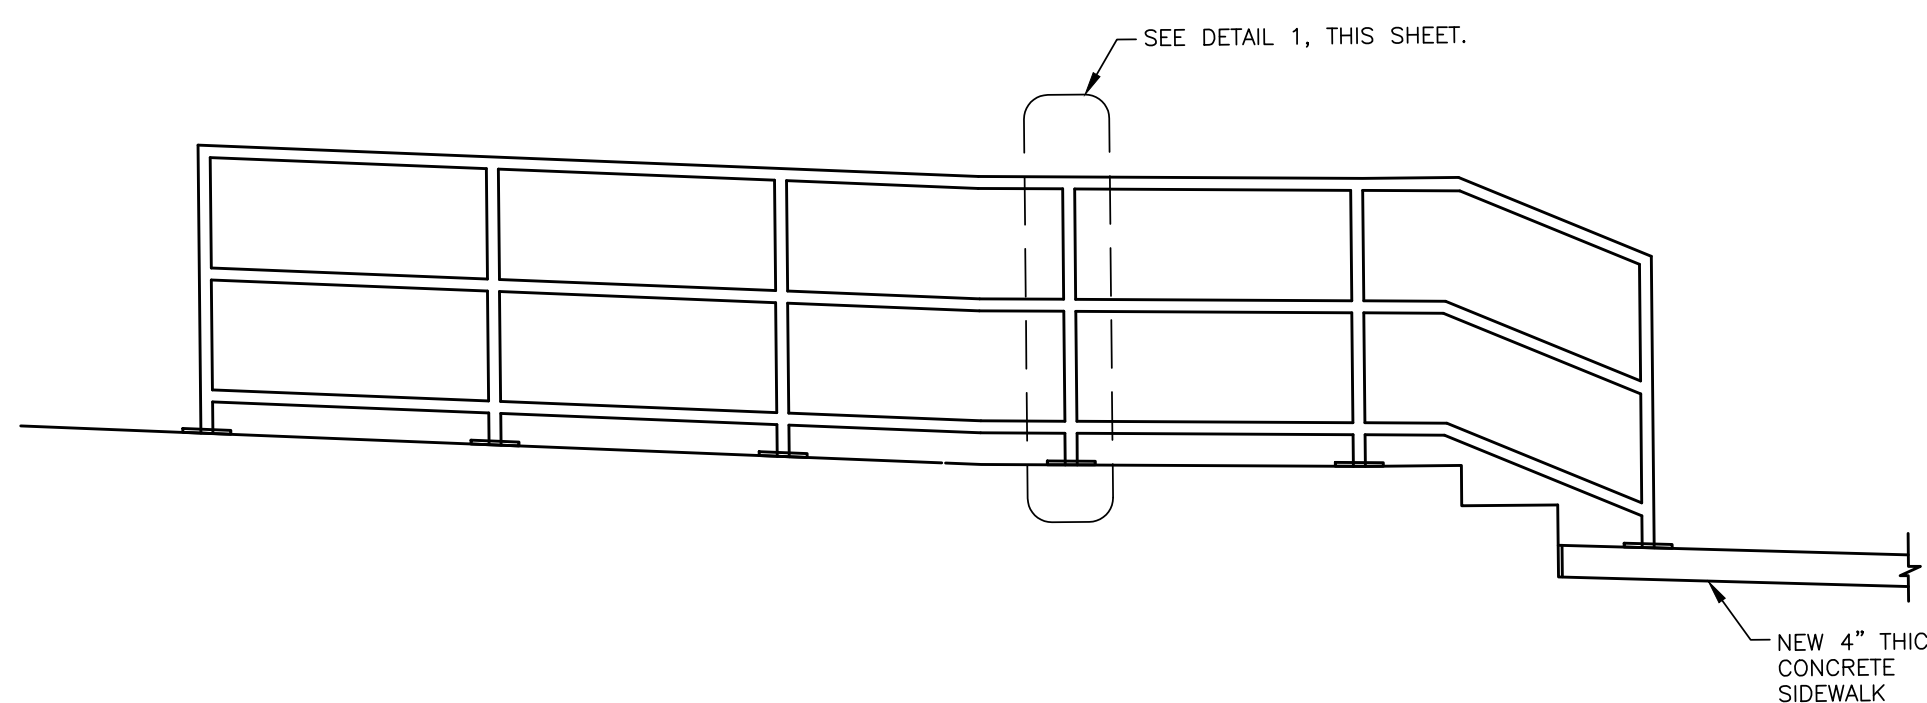

Elev C18
Macy Key Bank - South Hand Rail Elevation
SCALE: 1"=2"

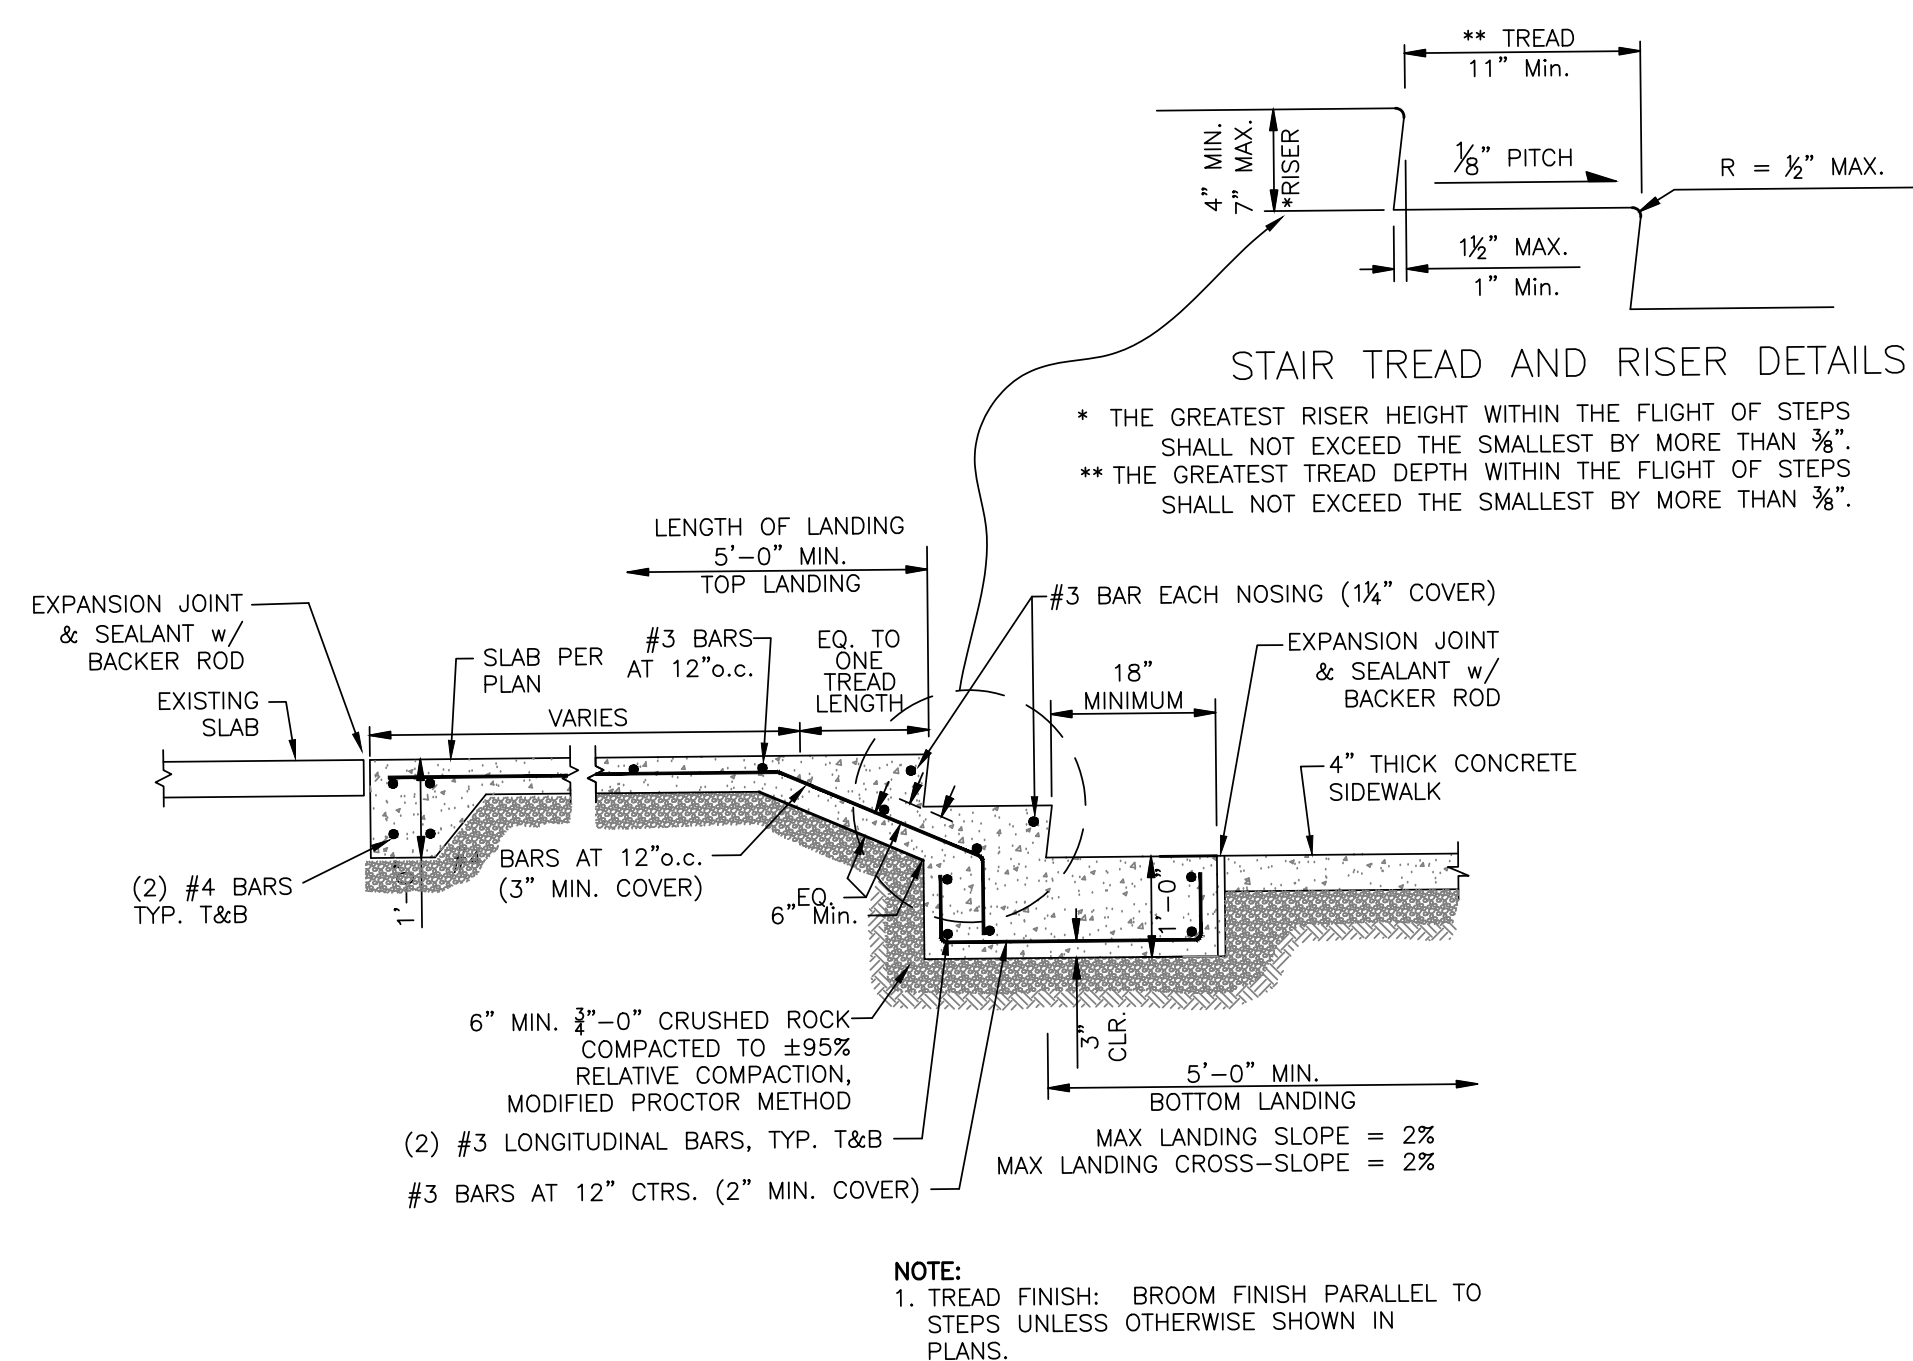

3 CONCRETE STAIR
SCALE: N.T.S.

200) - HOT TAP EXISTING 7" PVC WATERLINE WITH TAPPING SLEEVE (12"x8" MUELLER WITH MECHANICAL JOINT TAPPING SLEEVE OR APPROVED EQUAL) AND 8" TAPPING VALVE (MUELLER RESILIENT WEDGE TAPPING VALVE OR APPROVED EQUAL). PROVIDE MECHANICAL JOINT THRUST RESTRAINT.

201) - FURNISH AND INSTALL WATER VALVE BOX PER ODOT STD DWG RD258.

202) - FURNISH AND INSTALL 8" PVC C-900 WATERLINE. WATERLINE TRENCH PER ODOT STD DWG RD300. DEFLECT PIPE AT JOINTS AS REQUIRED TO ACHIEVE ALIGNMENT. PROVIDE MECHANICAL JOINT THRUST RESTRAINT. MINIMUM 36" OF COVER.

204) - CONNECT NEW 8" WATERLINE TO EXISTING 6" WATERLINE. INSTALL NEW 6" GATE VALVE (MUELLER A-23 RESILIENT WEDGE GATE VALVE OR APPROVED EQUAL) IN EXISTING 6" WATERLINE. INSTALL 8"x6" REDUCER RESTRAIN ALL JOINTS.

206) - INSTALL NEW 1" SERVICE CONNECTION FROM 8" MAIN TO EXISTING WATER METER. SEE ODOT STD DWG RD274. 8" SERVICE SADDLE (ROMAC INDUSTRIES 202N SERVICE SADDLE) FOR PVC WATER MAIN IS REQUIRED. USE 1" MUELLER BALL CORPORATION VALVE B-25029 AND 1" ADS POTABLE WATER SERVICE PIPE (IPS) SDR 7 FOR SERVICE LINE.



208) - ABANDON EXISTING 6" WATERLINE IN PLACE.

208) - FURNISH AND INSTALL NEW WATER SERVICE PER ODOT STD DWG RD274 WITH THE CITY OF HARRISBURG (PER APPROVED MATERIALS: METER BOX (ARMORCAST PRODUCTS 12"x20"x12" ROTOCAST BOX A6000485), WATER METER ID (ARMORCAST PRODUCTS 12"x20"x1-2" RPM COVER W/ TOUCH READ HOL A6000484-H2), NEW WATER METER (3/4" PEARL BY SENSUS), BALL ANGLE METER VALVE (1"x3/4" MUELLER 300 BALL ANGLE METER B-24259N), SERVICE PIPE (1" POLYETHYLENE SDR 7) AND CORPORATION STOP (1" MUELLER) SERVICE SADDLES.

209) - POTHOLE EXISTING WATER LINE AND VERIFY LOCATION, DEPTH, MATERIAL AND SIZE. NOTIFY ENGINEER OF ANY DISCREPANCIES.

210) - PROPOSED WATERLINE TO GO UNDER PROPOSED STORM LINE. PROVIDE 45° VERTICAL BENDS WITH MECHANICAL RESTRAINT TO ACHIEVE GOING UNDER PROPOSED STORM LINE. RESTRAIN ALL JOINTS 40 FEET FROM VERTICAL BEND.

211) - FURNISH AND INSTALL 45° HORIZONTAL BEND. PROVIDE MECHANICAL JOINT THRUST RESTRAINT.

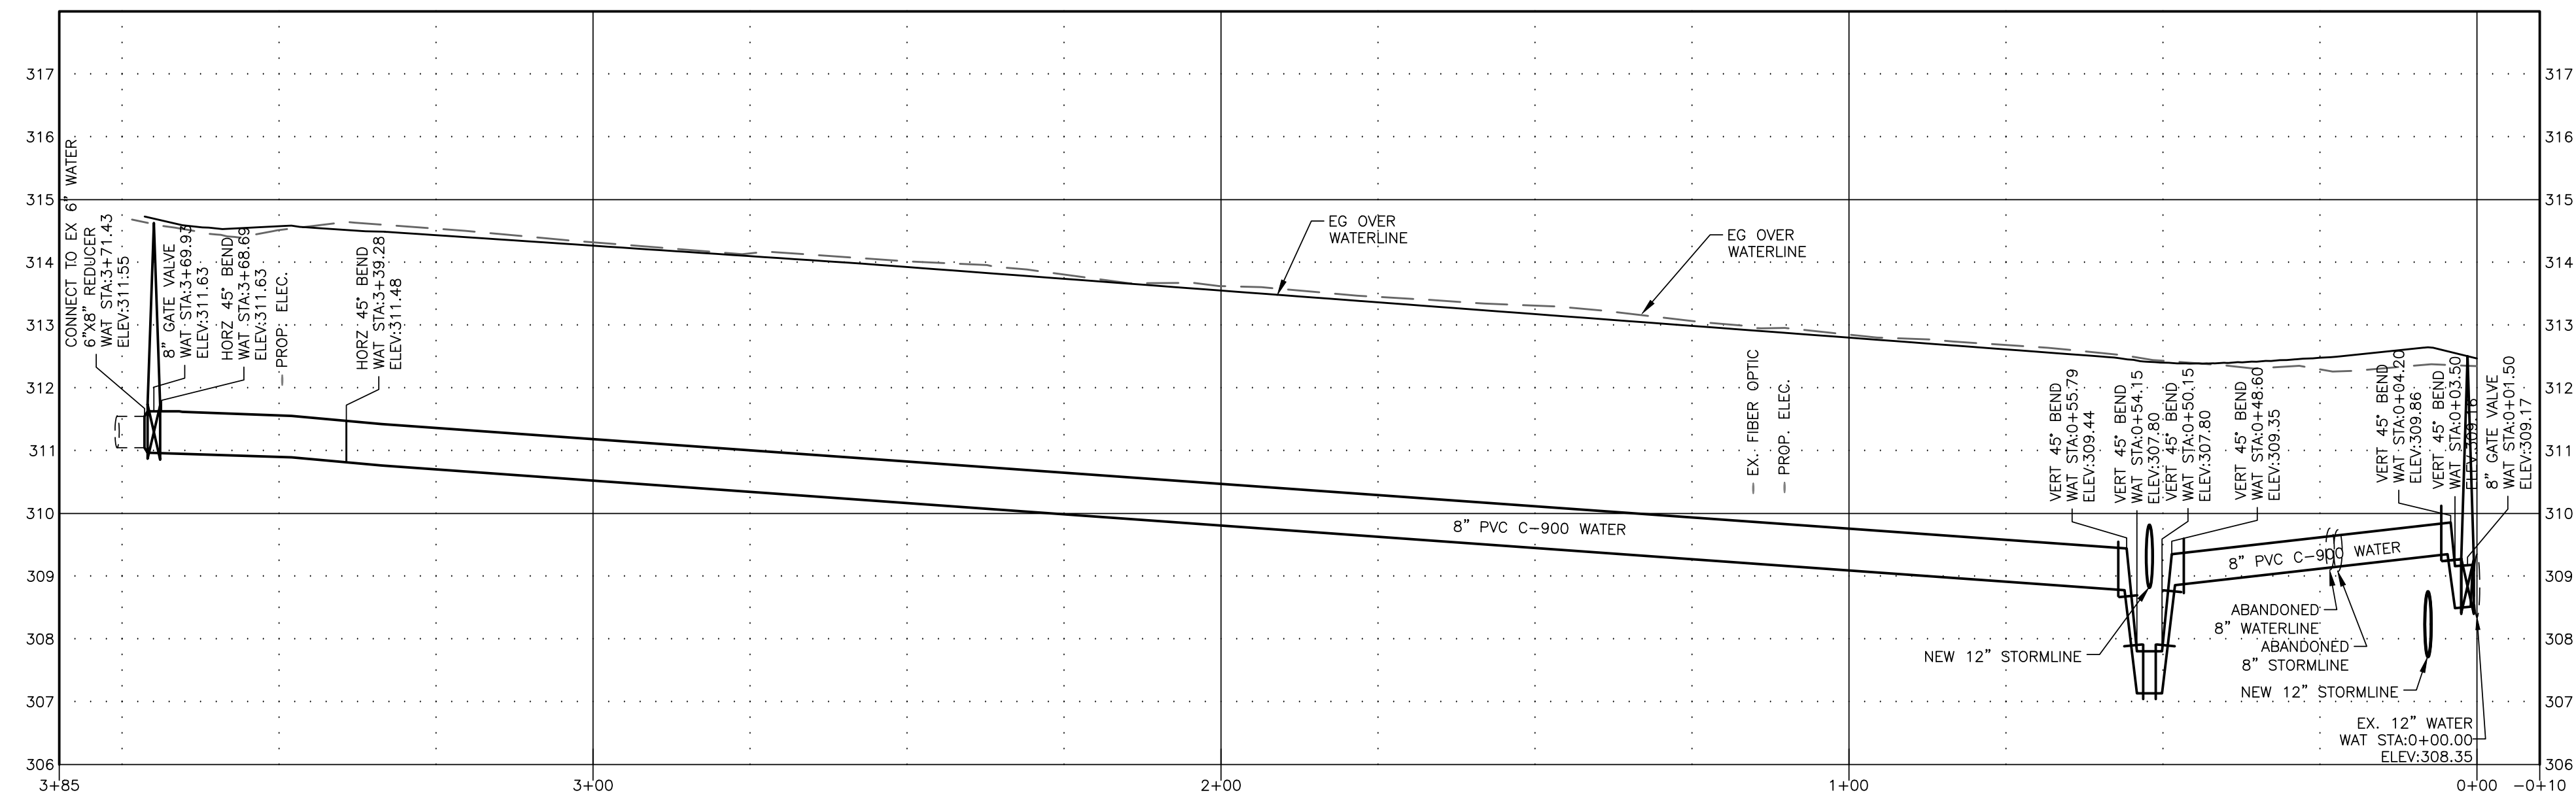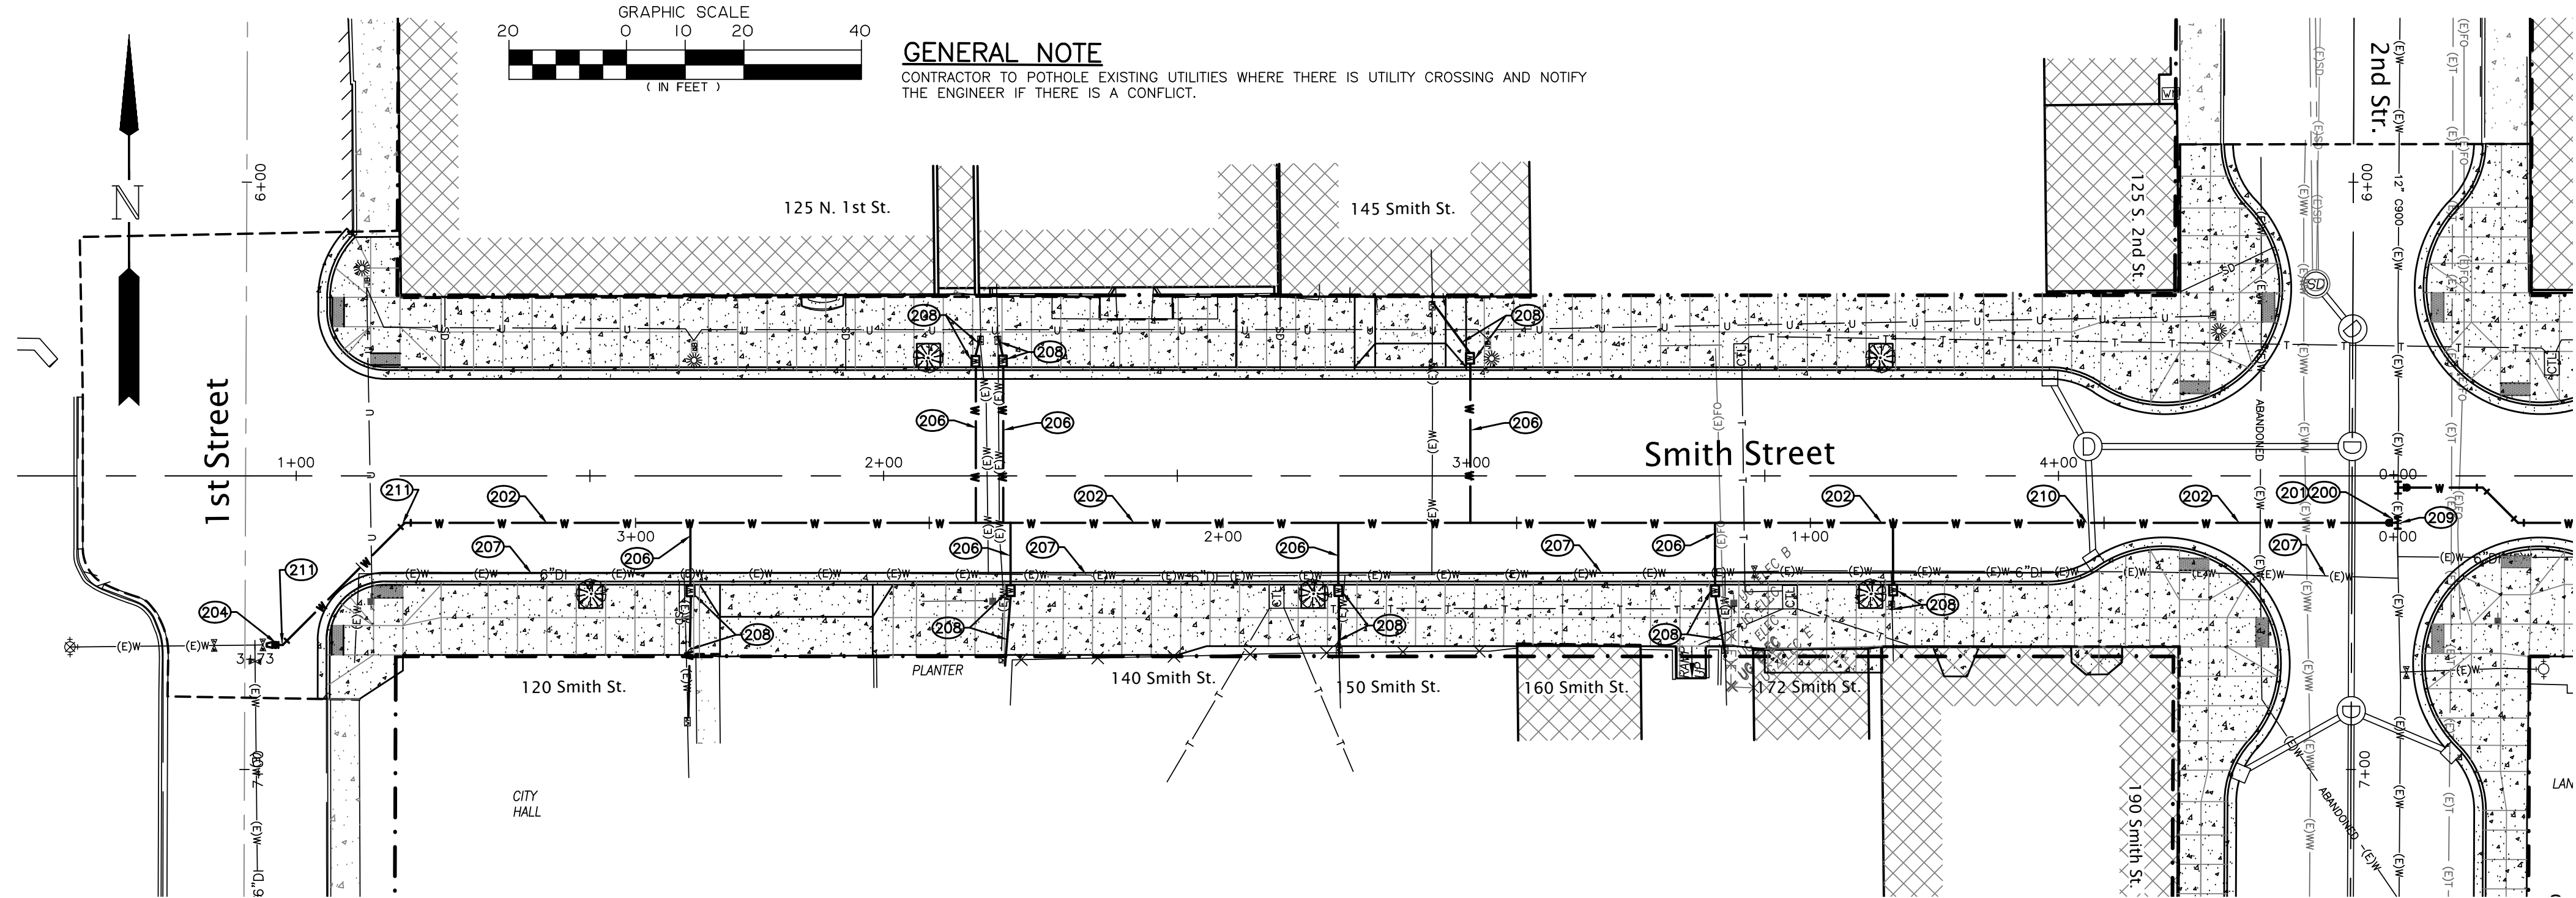

WEST SMITH WATERLINE PROFILE

2:\2017\17-009F Harrisburg Smith Street\Drawing\17-009F Street Improvements.dwg 1/28/2020 2:01 PM JULIE

copyright © 2016 Branch Engineering, Inc



Branch
ENGINEERING Inc.

Since 1977

civil • transportation
structural • geotechnical
SURVEYING

310 5th Street
Springfield, OR 97477
p. 541.746.0637

www.BranchEngineering.com
Springfield OR | Albany OR



EXPIRES: DECEMBER 31, 2020

project title:

project title:

**CITY OF HARRISBURG
Smith, Macy, & 2nd Street Rehabilitation**

Smith - 1st To 3rd, Macy - 2nd To 3rd, 2nd - Smith To Macy
HARRISBURG, OREGON

revisions:

date: JANUARY 28, 2020
drawn by: GAM
designer: GAM
project no: 17-009P

Smith Street Waterline Plan & Profile STA 0+00 to 3+85

sheet:



C19

CONSTRUCTION NOTES

- 200—HOT TAP EXISTING 12" PVC WATERLINE WITH TAPPING SLEEVE (12"x8" MUELLER WITH MECHANICAL JOINT TAPPING SLEEVE OR APPROVED EQUAL) AND 8" TAPPING VALVE (MUELLER RESILIENT WEDGE TAPPING VALVE OR APPROVED EQUAL). PROVIDE MECHANICAL JOINT THRUST RESTRAINT.
- 201—FURNISH AND INSTALL WATER VALVE BOX PER ODOT STD DWG RD258.
- 202—FURNISH AND INSTALL 8" PVC C-900 WATERLINE. WATERLINE TRENCH PER ODOT STD DWG RD300. DEFLECT PIPE AT JOINTS AS REQUIRED TO ACHIEVE ALIGNMENT. PROVIDE MECHANICAL JOINT THRUST RESTRAINT. MINIMUM 36" OF COVER.
- 203—FURNISH AND INSTALL 8"x6" REDUCER. PROVIDE MECHANICAL JOINT THRUST RESTRAINT.
- 204—CONNECT NEW 8" WATERLINE TO EXISTING 6" WATERLINE. RESTRAIN ALL JOINTS.
- 206—INSTALL NEW 1" SERVICE CONNECTION FROM 8" MAIN TO EXISTING WATER METER. SEE ODOT STD DWG RD274. 8" SERVICE SADDLE (ROMAC INDUSTRIES 202N SERVICE SADDLE) FOR PVC WATER MAIN IS REQUIRED. USE 1" MUELLER BALL CORPORATION VALVE B-25029 AND 1" ADS POTABLE WATER SERVICE PIPE (IPS) SDR 7 FOR SERVICE LINE.
- 207—ABANDON EXISTING 6" WATERLINE IN PLACE.
- 208—FURNISH AND INSTALL NEW WATER METER AND BOX PER ODOT STD DWG RD274 WITH THE CITY OF HARRISBURG PRE-APPROVED MATERIALS: METER BOX (ARMORCAST PRODUCTS 12"x20"x12" ROTOCAST BOX A6000485), WATER METER LID (ARMORCAST PRODUCTS 12"x20"x1-3/4" RPM COVER W/ TOUCH READ HOLE A6000484-H2), NEW WATER METER (3/4" iPEARL BY SENSUS), BALL ANGLE METER VALVE (1"x3/4" MUELLER 300 BALL ANGLE METER, B-24259N), SERVICE PIPE (1" POLYETHELYN SDR 7) AND CORPORATION STOP (1" MUELLER). CONNECT TO EXISTING SERVICE LINE BEHIND EXISTING WATER METER.
- 209—POTHOLE EXISTING WATER LINE AND VERIFY LOCATION, DEPTH, MATERIAL AND SIZE. NOTIFY ENGINEER OF ANY DISCREPANCIES.
- 211—FURNISH AND INSTALL 45' HORIZONTAL BEND. PROVIDE MECHANICAL JOINT THRUST RESTRAINT.

GENERAL NOTE

CONTRACTOR TO POTHOLE EXISTING UTILITIES WHERE THERE IS UTILITY CROSSING AND NOTIFY THE ENGINEER IF THERE IS A CONFLICT.

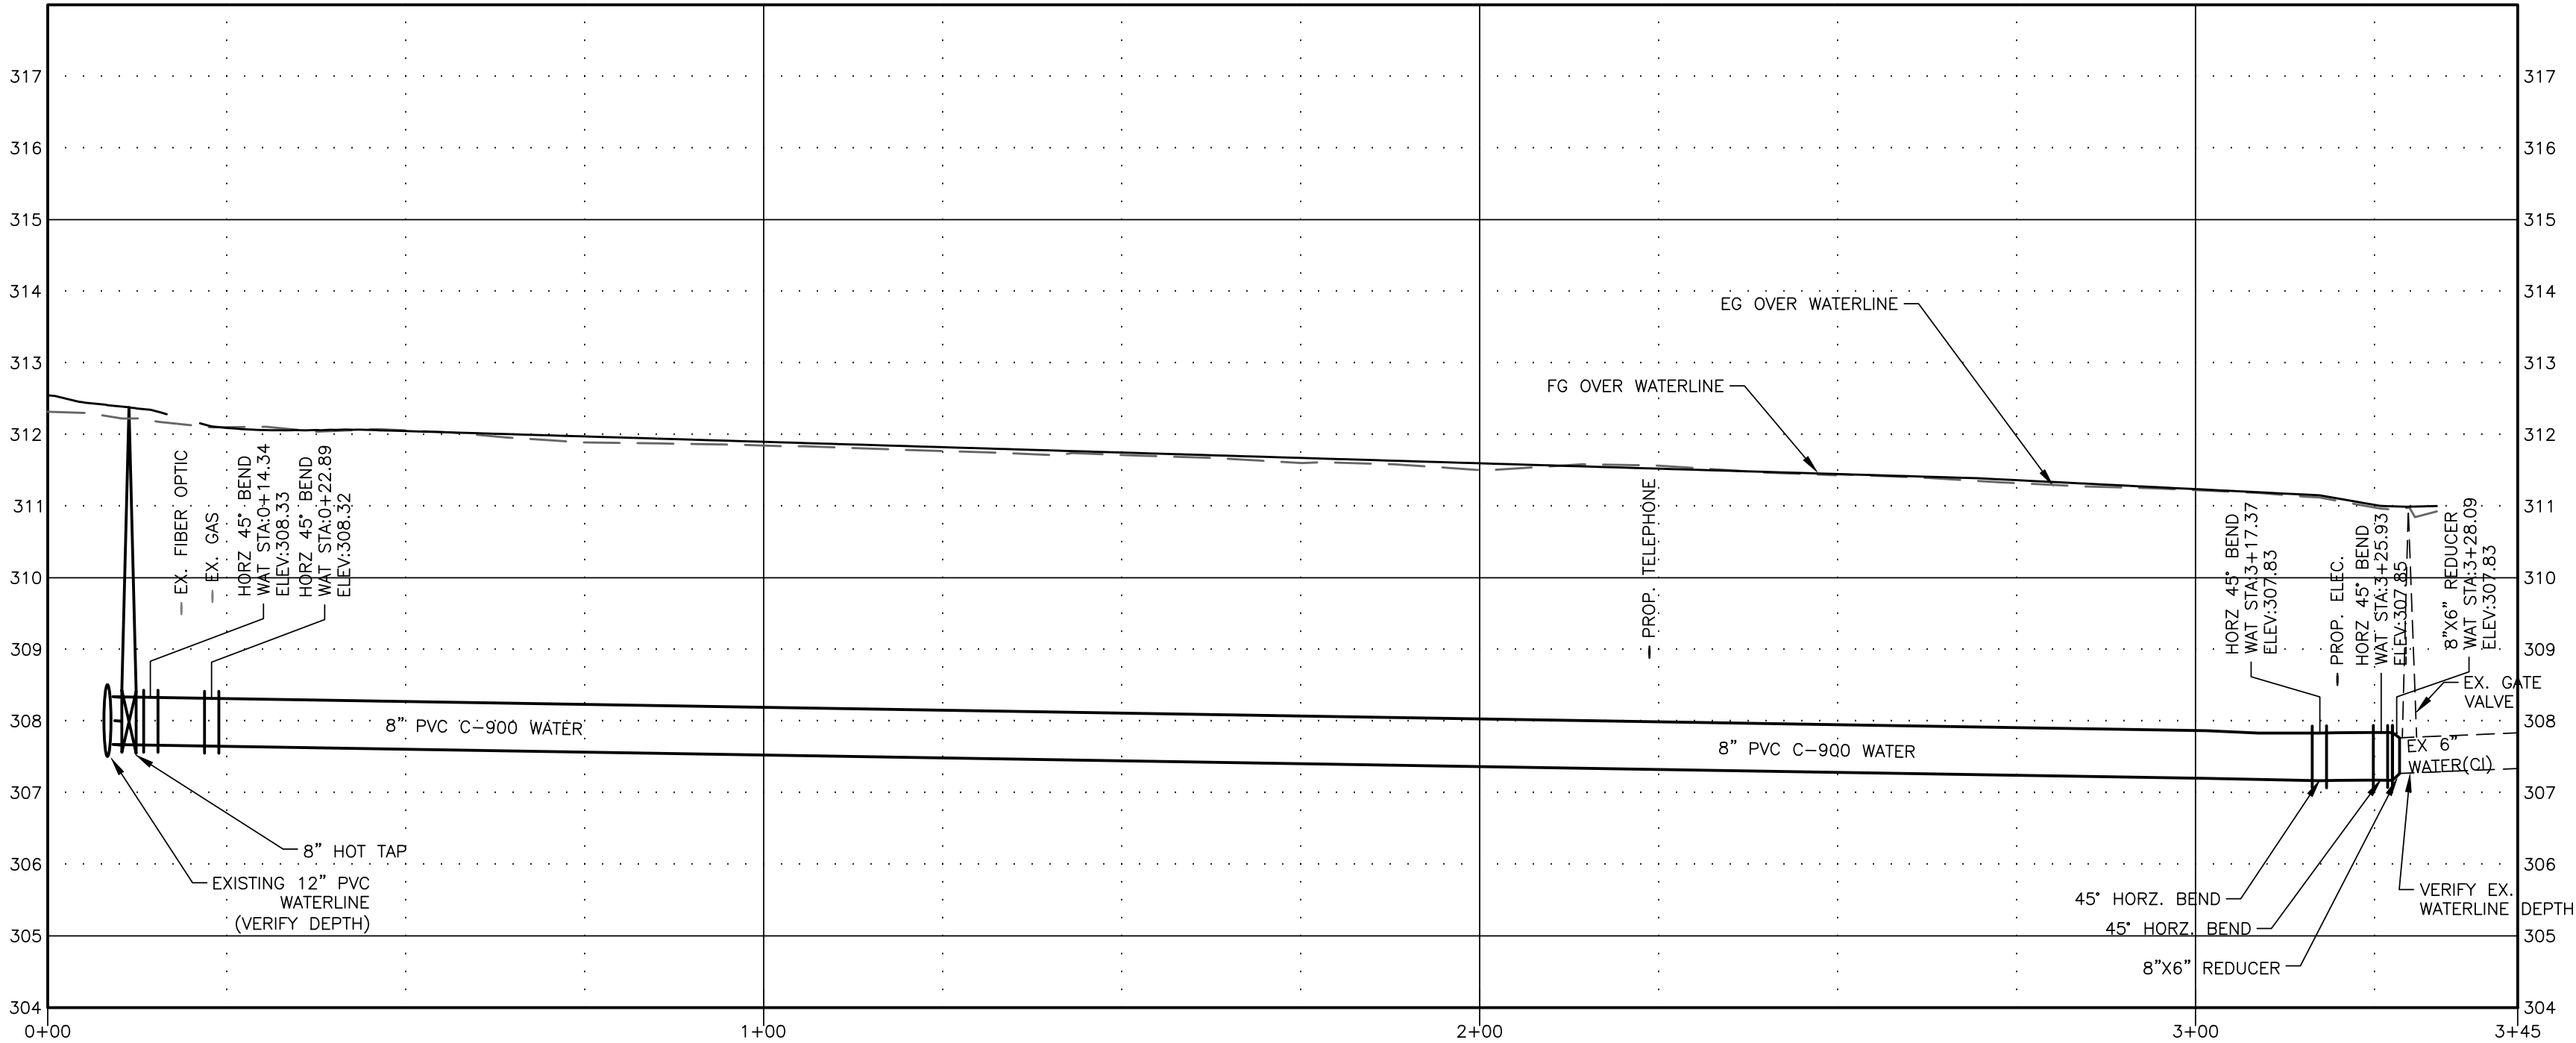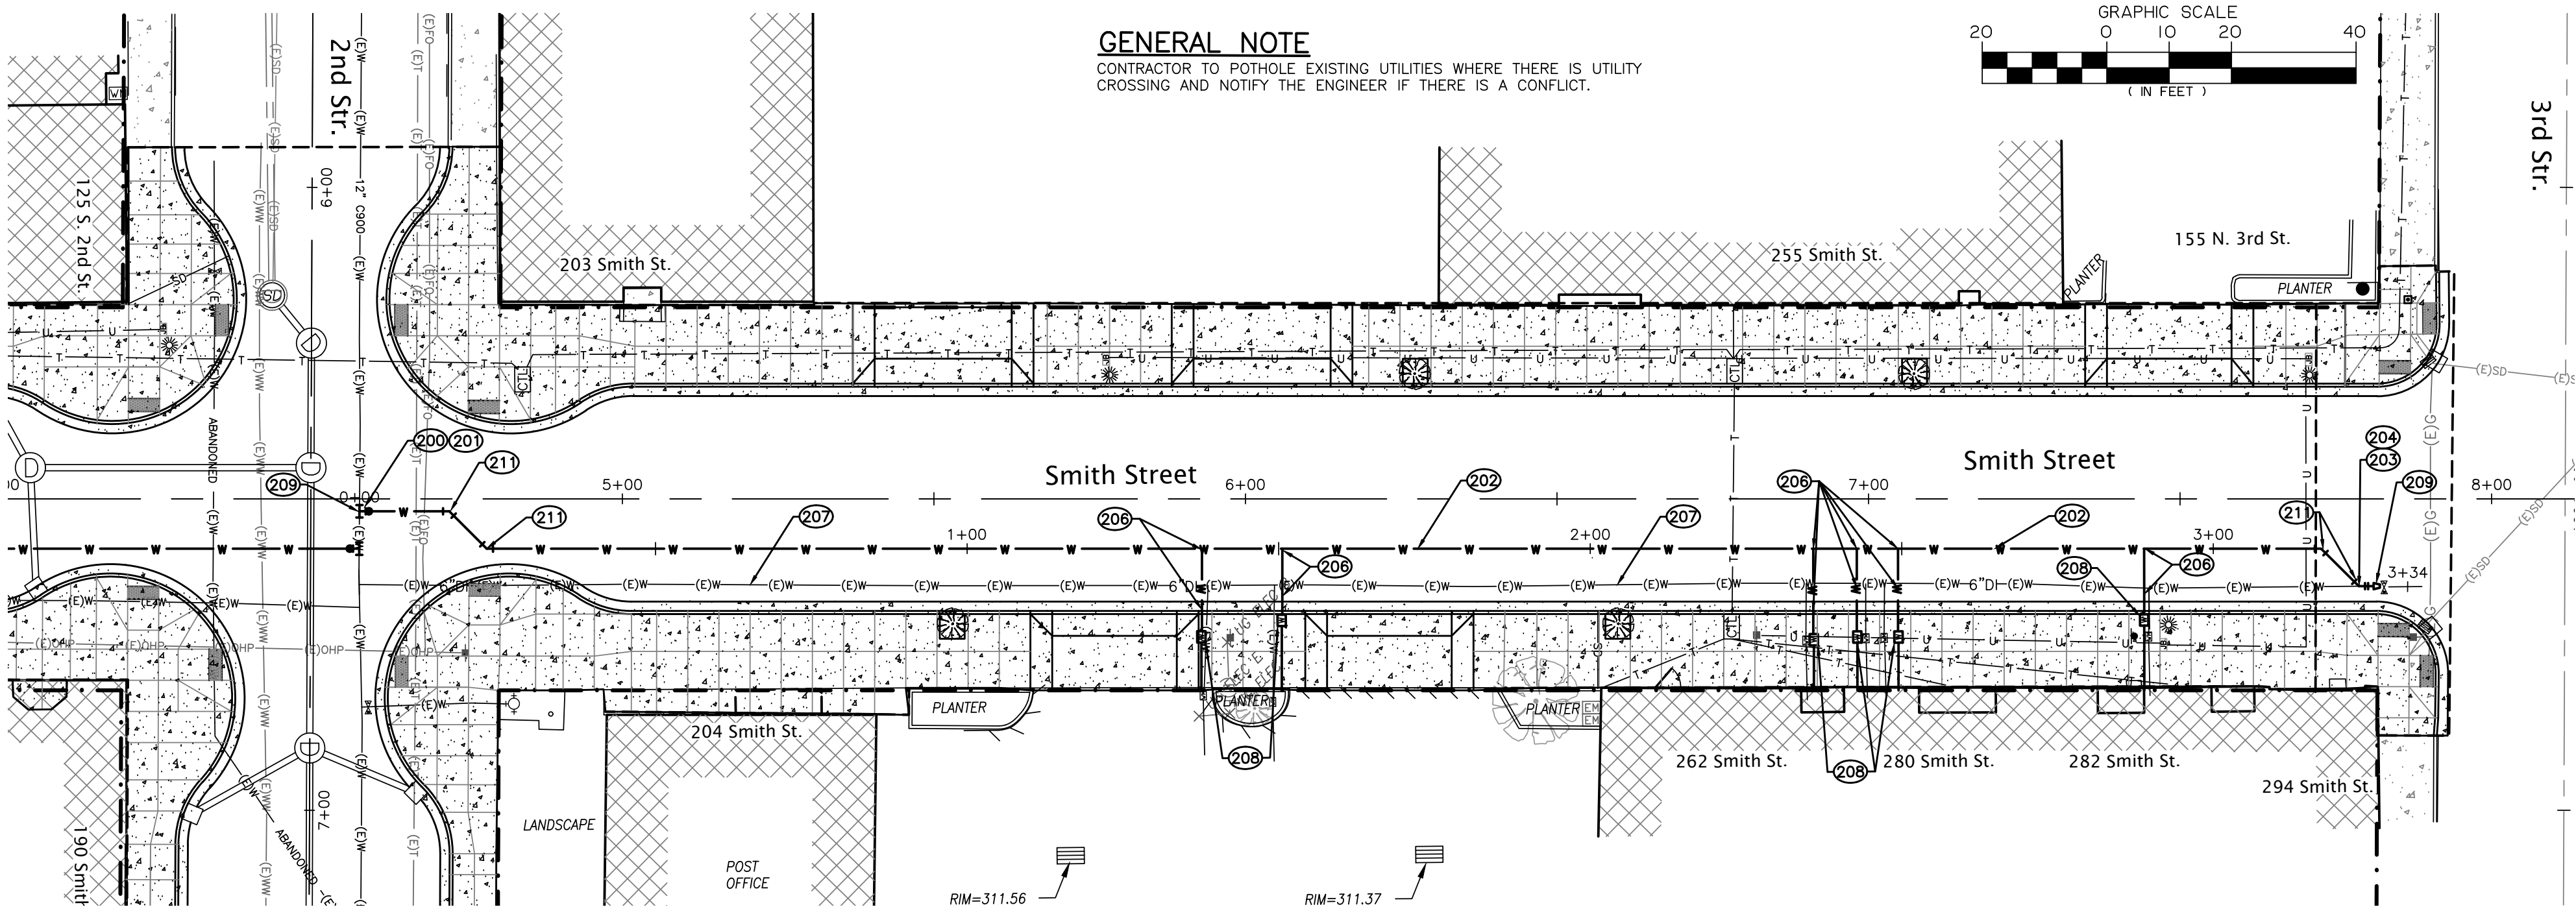

EAST SMITH WATERLINE PROFILE

SCALE: HORZ: 1" = 20'
VERT: 1" = 2'

Branch ENGINEERING INC
Since 1977
civil • transportation
structural • geotechnical
SURVEYING
310 5th Street
Springfield, OR 97477
p: 541.746.0637
www.BranchEngineering.com
Springfield OR | Albany OR

REGISTERED PROFESSIONAL
ENGINEER
#53,800
DIGITALLY SIGNED
OREGON
JULY 9, 2019
GREGORY A. MOWER
EXPIRES: DECEMBER 31, 2020

project title:
**CITY OF HARRISBURG
Smith, Macy, & 2nd Street Rehabilitation**
Smith - 1st To 3rd, Macy - 2nd To 3rd, 2nd - Smith To Macy
HARRISBURG, OREGON

revisions:

date: JANUARY 28, 2020
drawn by: GYM
designer: GYM
project no: 17-009F


Smith Street
Waterline
Plan & Profile
STA 0+00 to 5+50

sheet:

C20




Z:\2017\17-009F Harrisburg Smith Street\Drawing\17-009F Street Improvements.dwg / 2/8/2020 2:01 PM JAL/E

copyright © 2016 Branch Engineering, Inc.

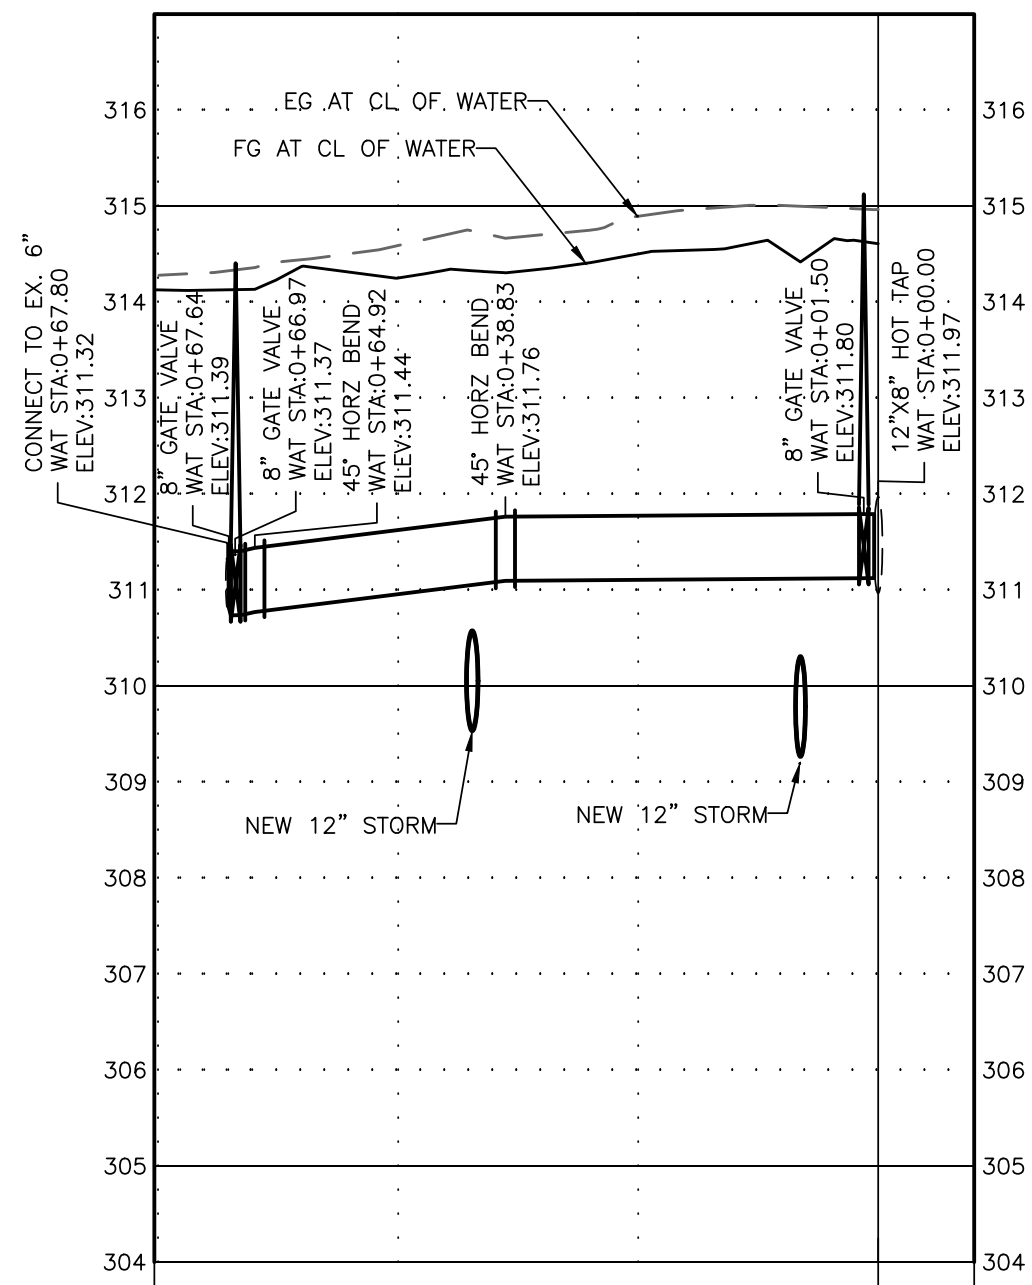

WEST MACY WATERLINE PROFILE

SCALE: HORIZ: 1" = 20'
VERT: 1" = 2'

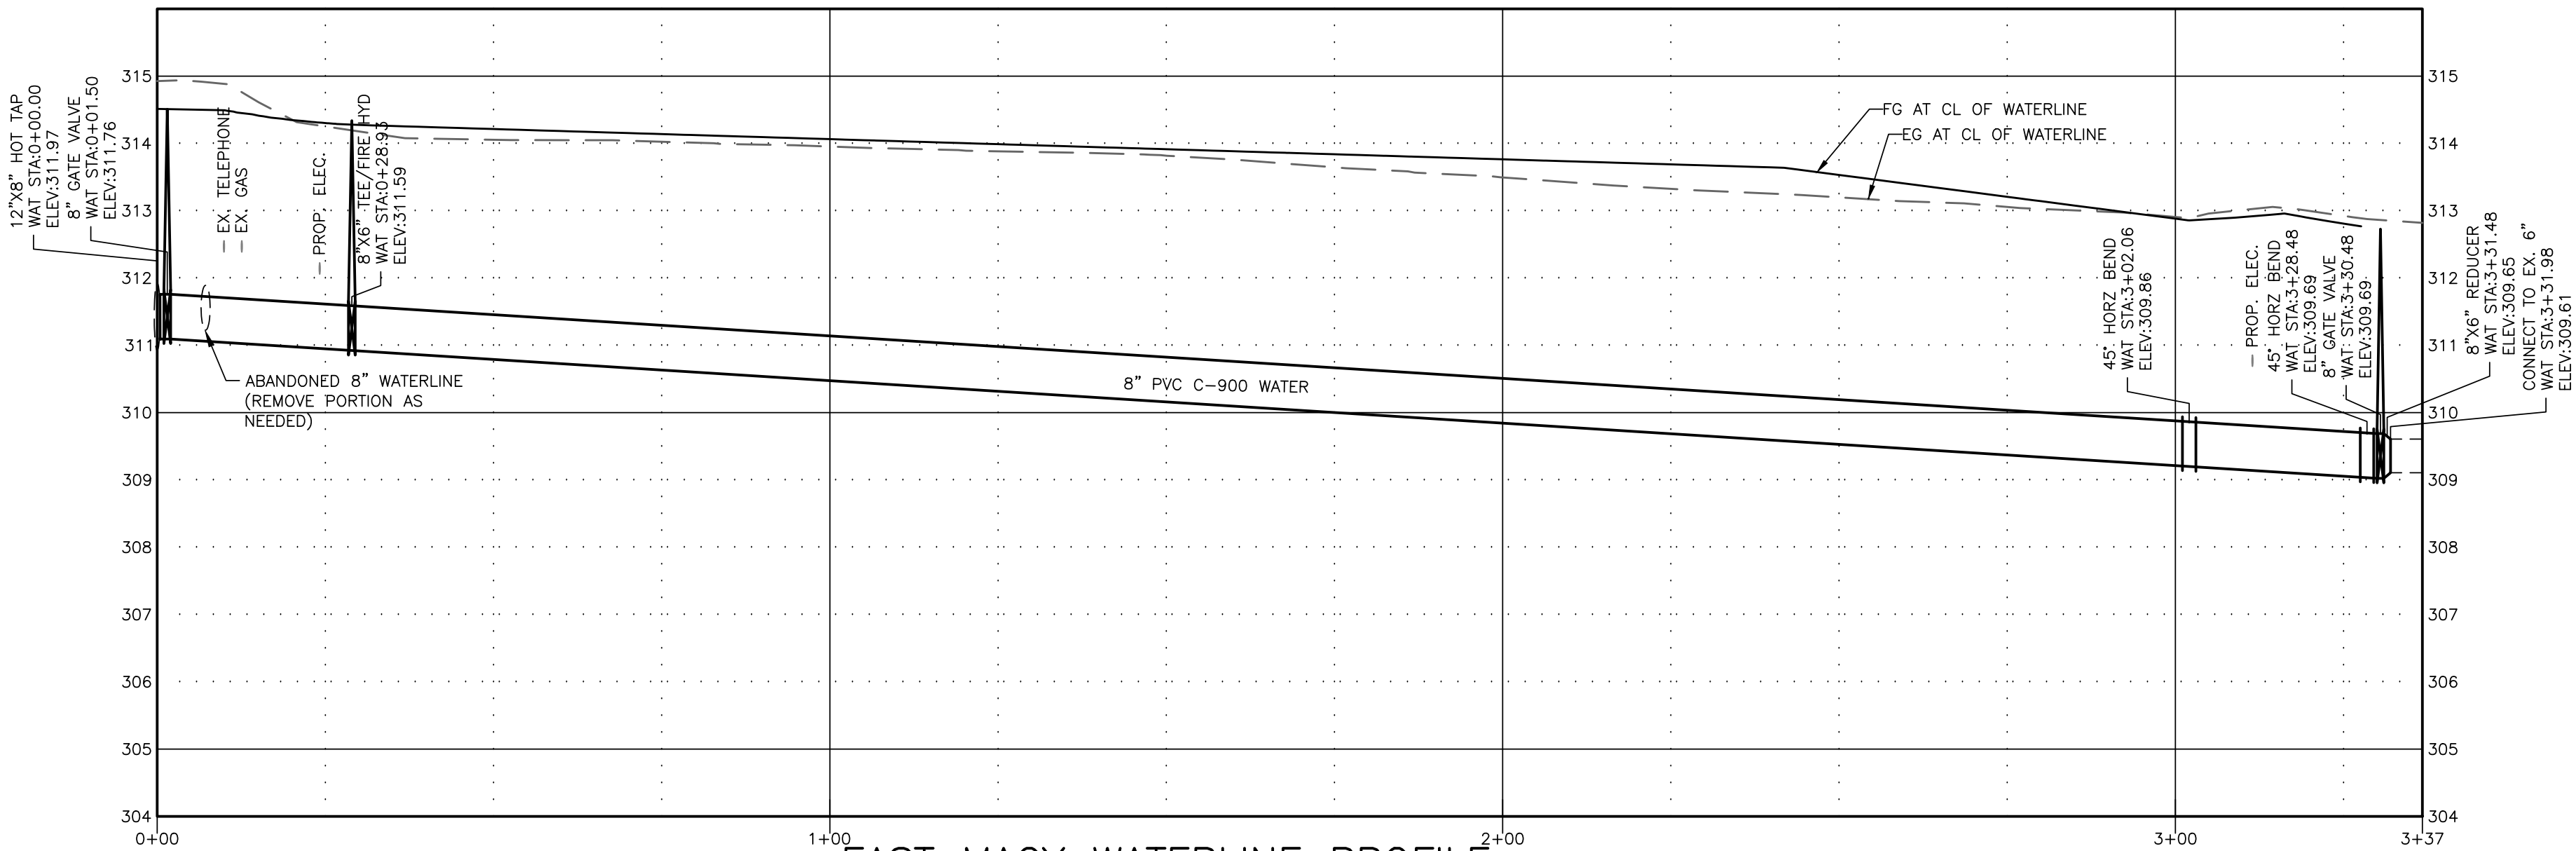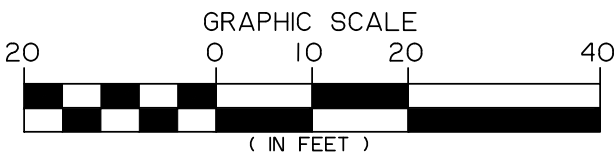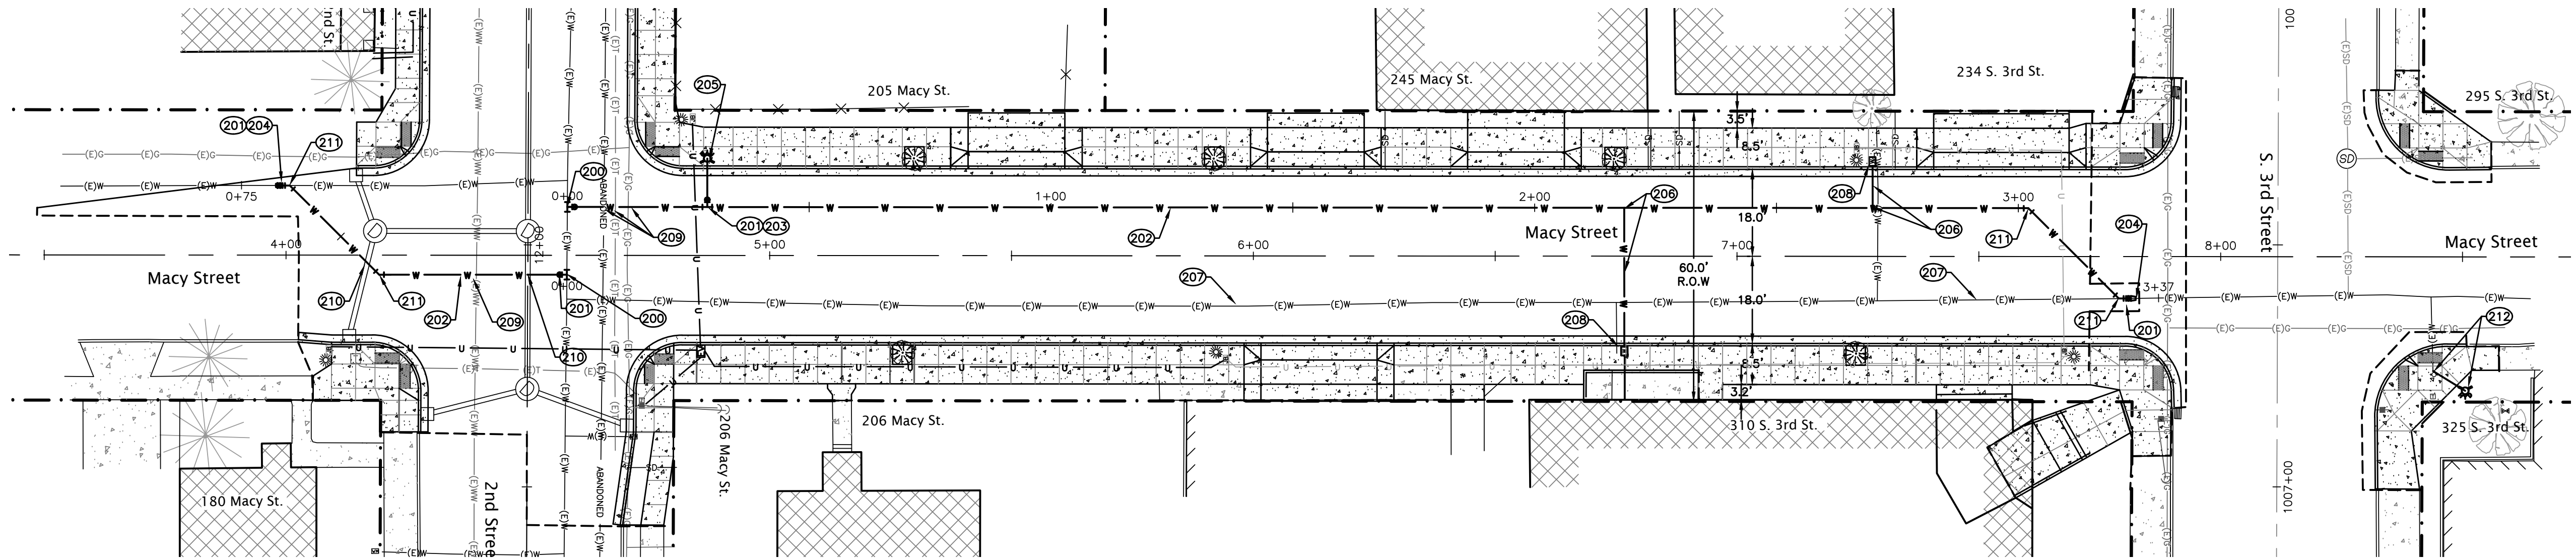

EAST MACY WATERLINE PROFILE

SCALE: HORIZ: 1" = 20'
VERT: 1" = 2'

GENERAL NOTE

CONTRACTOR TO POTHOLE EXISTING UTILITIES WHERE THERE IS UTILITY CROSSING AND NOTIFY THE ENGINEER IF THERE IS A CONFLICT.

CONSTRUCTION NOTES

- 200—HOT TAP EXISTING 12" PVC WATERLINE WITH TAPPING SLEEVE (12"x8" MUELLER WITH MECHANICAL JOINT TAPPING SLEEVE OR APPROVED EQUAL) AND 8" TAPPING VALVE (MUELLER RESILIENT WEDGE TAPPING VALVE OR APPROVED EQUAL). PROVIDE MECHANICAL JOINT THRUST RESTRAINT.
- 201—FURNISH AND INSTALL WATER VALVE BOX PER ODOT STD DWG RD258.
- 202—FURNISH AND INSTALL 8" PVC C-900 WATERLINE. WATERLINE TRENCH PER ODOT STD DWG RD300. DEFLECT PIPE AT JOINTS AS REQUIRED TO ACHIEVE ALIGNMENT. PROVIDE MECHANICAL JOINT THRUST RESTRAINT. MINIMUM 30" OF COVER.
- 203—FURNISH AND INSTALL 8"x6" TEE. PROVIDE MECHANICAL JOINT THRUST RESTRAINT.
- 204—CONNECT NEW 8" WATERLINE TO EXISTING 6" WATERLINE. INSTALL NEW 8" GATE VALVE (MUELLER A-2361 RESILIENT WEDGE GATE VALVE OR APPROVED EQUAL) WITH 8"x6" REDUCER ON EXISTING 6" WATERLINE. RESTRAIN ALL JOINTS.
- 205—FURNISH AND INSTALL FIRE HYDRANT ASSEMBLY (MUELLER 5 1/2" A423 SUPER CENTURION "250" WITH TWO HOSE NOZZLES AND ONE PUMPER NOZZLE WITH 4" INTEGRAL STORZ CONNECTION) AND 6" GATE VALVE (MUELLER A-2361 RESILIENT WEDGE GATE VALVE). HYDRANT TO BE PAINTED YELLOW WITH APPROVED PAINT. SEE ODOT STD DWG RD254.
- 206—INSTALL NEW 1" SERVICE CONNECTION FROM 8" MAIN TO EXISTING WATER METER. SEE ODOT STD DWG RD274. 8" SERVICE SADDLE (ROMAC INDUSTRIES 202N SERVICE SADDLE) FOR PVC WATER MAIN IS REQUIRED. USE 1" MUELLER BALL CORPORATION VALVE B-25029 AND 1" ADS POTABLE WATER SERVICE PIPE (IPS) SDR 7 FOR SERVICE LINE.
- 207—ABANDON EXISTING 6" WATERLINE IN PLACE.
- 208—FURNISH AND INSTALL NEW WATER SERVICE PER ODOT STD DWG RD274 WITH THE CITY OF HARRISBURG PRE-APPROVED MATERIALS: METER BOX (ARMORCAST PRODUCTS 12"x20"x12" ROTOCASE BOX A6000485), WATER METER LID (ARMORCAST PRODUCTS 12"x20"x1-1/2" RPM COVER W/ TOUCH READ HOLE A6000484-H2), NEW WATER METER (3/4" iPEARL BY SENSUS), BALL ANGLE METER VALVE (1"X3/4" MUELLER 300 BALL ANGLE METER, B-24259N), SERVICE PIPE (1" POLYETHYLENE SDR 7) AND CORPORATION STOP (1" MUELLER) SERVICE SADDLES.
- 209—POTHOLE EXISTING WATER LINE AND AND VERIFY LOCATION, DEPTH, MATERIAL AND SIZE. NOTIFY ENGINEER OF ANY DISCREPANCIES.
- 210—PROPOSED WATERLINE TO GO OVER PROPOSED STORM LINE. PROVIDE 45° VERTICAL BENDS WITH MECHANICAL RESTRAINT TO ACHIEVE GOING UNDER PROPOSED STORM LINE.
- 211—FURNISH AND INSTALL 45° HORIZONTAL BEND. PROVIDE MECHANICAL JOINT THRUST RESTRAINT.
- 212—REMOVE EXISTING FIRE HYDRANT AND CONNECT TO EXISTING FIRE HYDRANT STUB WITH APPROPRIATE FITTINGS AND CONNECTIONS. EXTEND PIPING WITH 6" PVC C-900 AND RECONNECT EXISTING FIRE HYDRANT. PROVIDE MECHANICAL JOINT THRUST RESTRAINT.

project title:

CITY OF HARRISBURG Smith, Macy, & 2nd Street Rehabilitation

Smith - 1st To 3rd, Macy - 2nd To 3rd, 2nd - Smith To Macy
HARRISBURG, OREGON

revisions:

date: JANUARY 28, 2020
drawn by: GAM
designer: GAM
project no: 17-009F




Macy Street
Waterline
Plan & Profile
STA 0+00 to 5+50

sheet:

C21

Z:\2017\17-009F Harrisburg Smith Street\Drawing\17-009F Street Improvements.dwg / 2/8/2020 2:01 PM JLL/E

copyright © 2016 Branch Engineering, Inc.

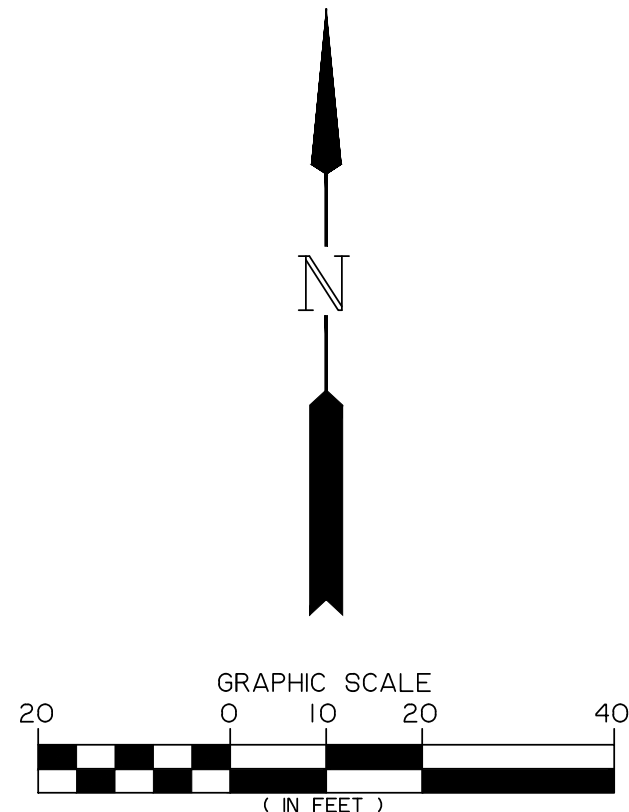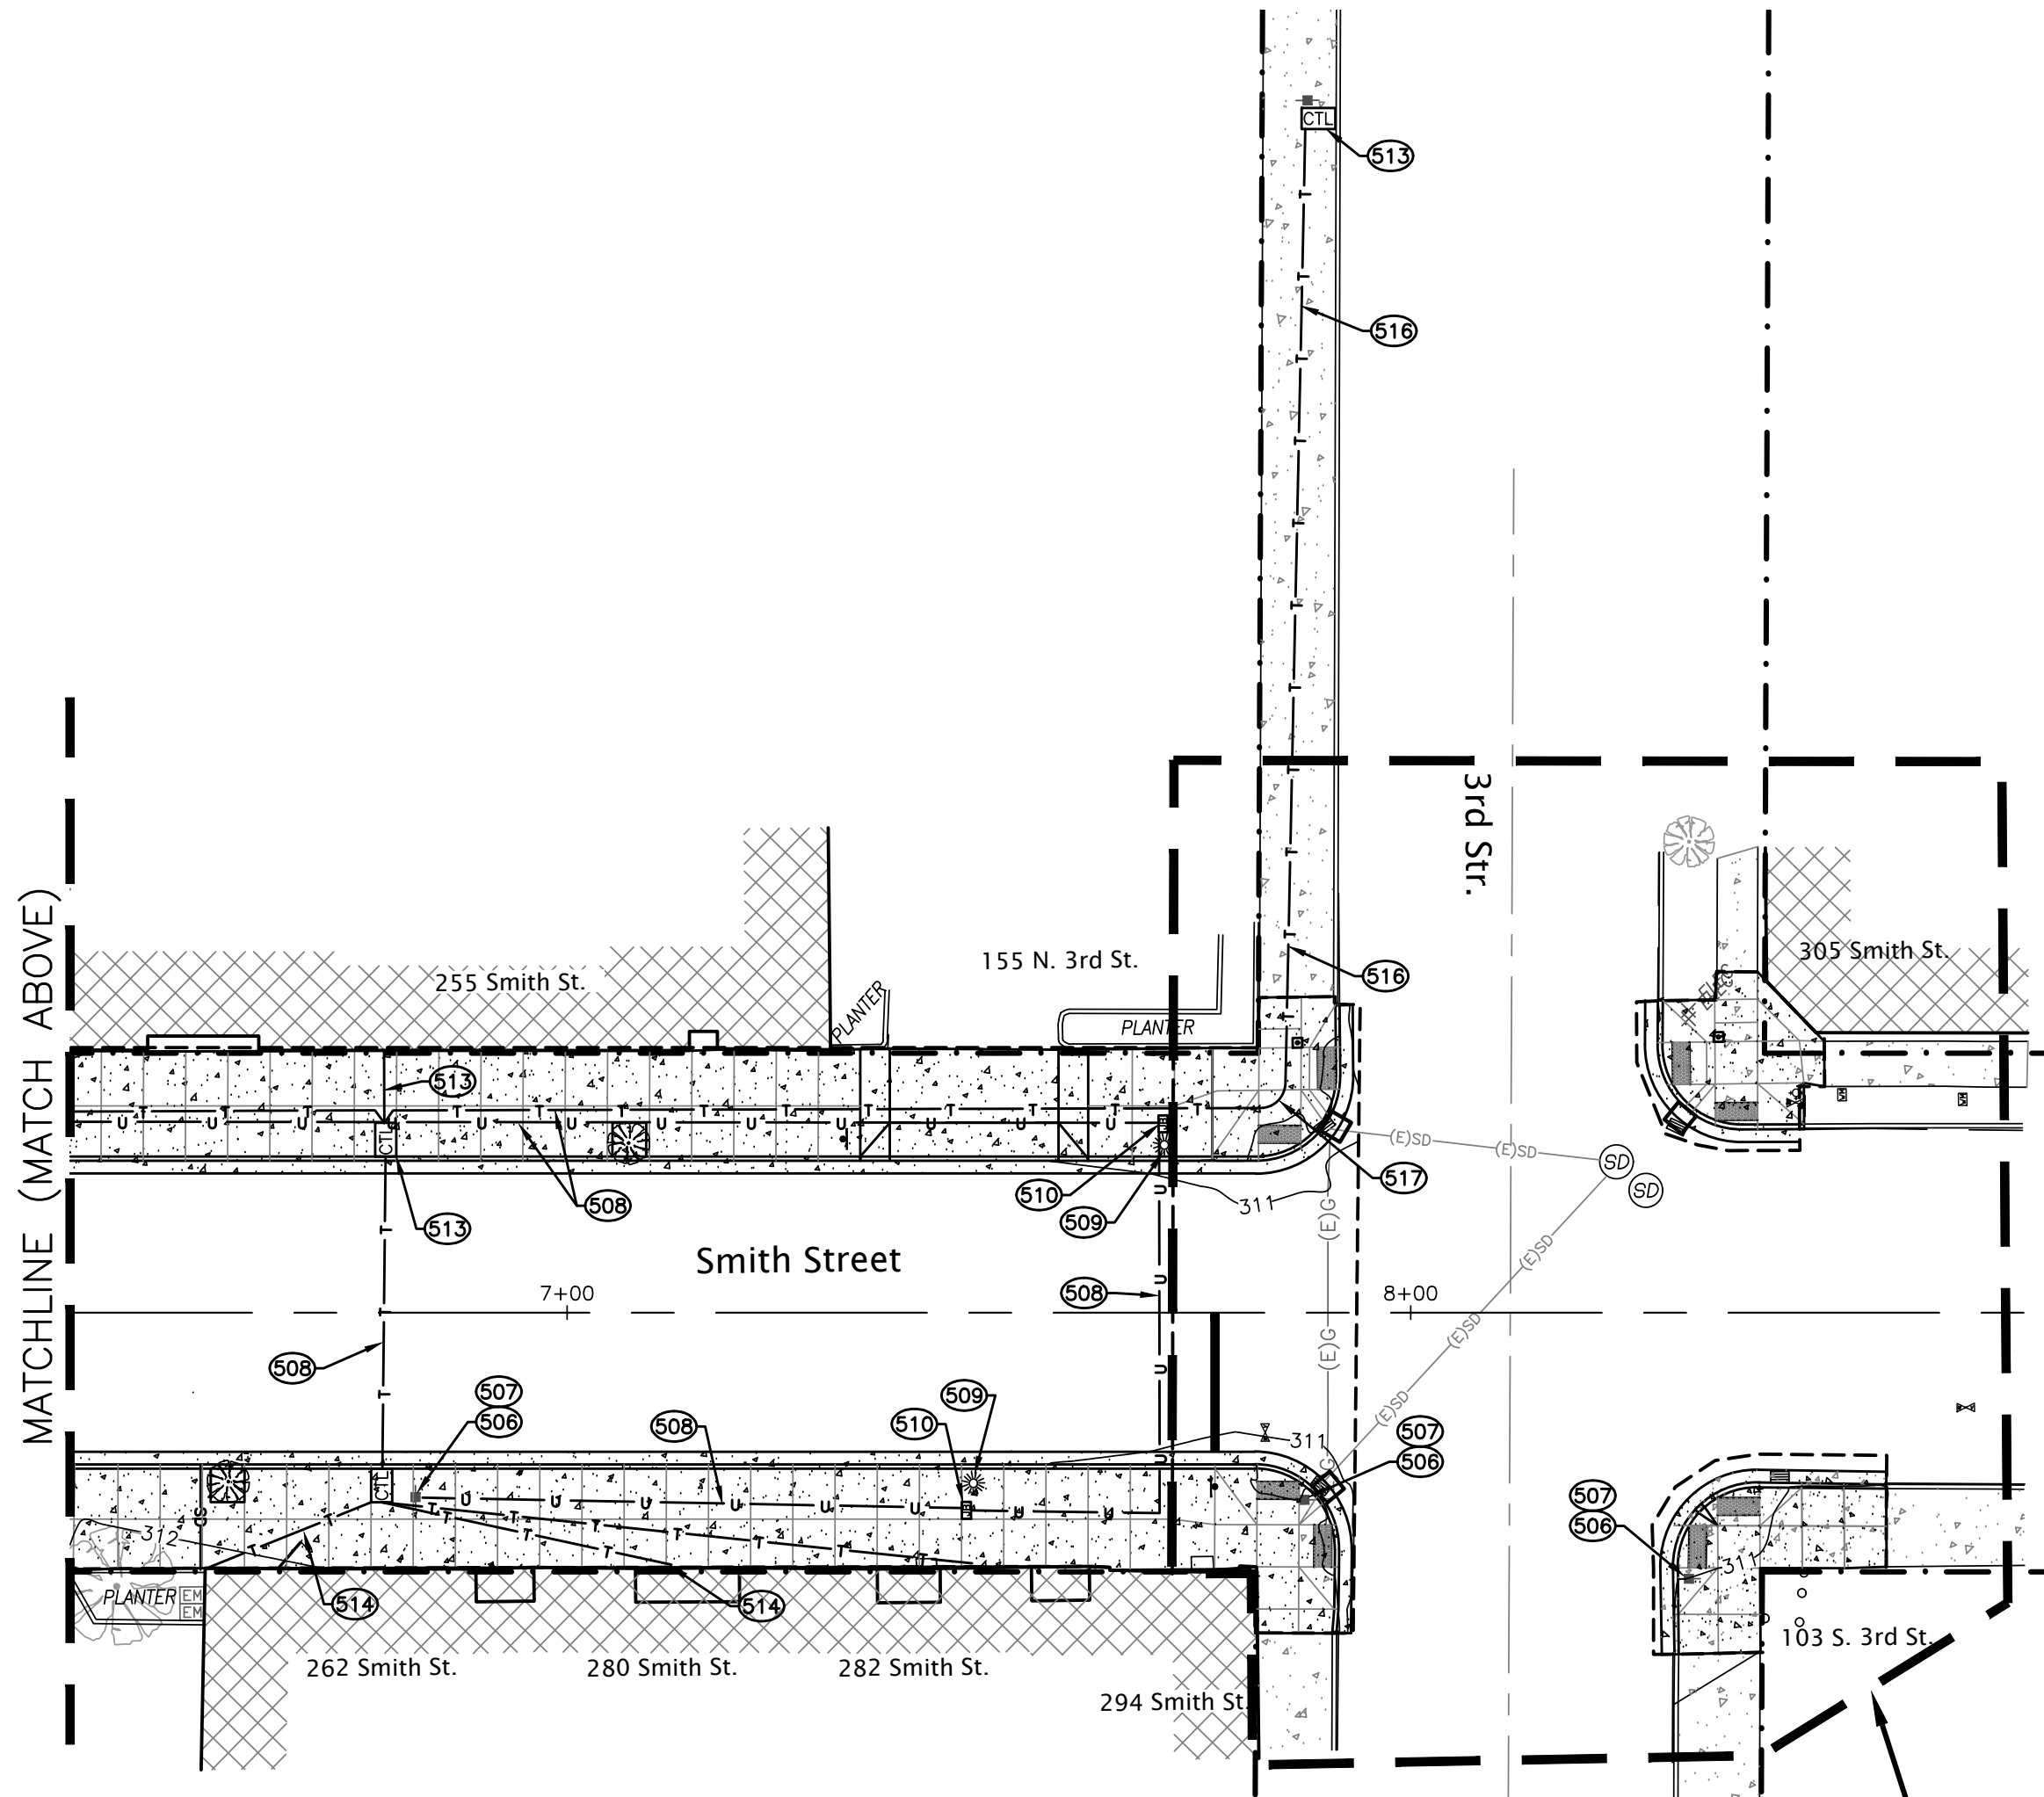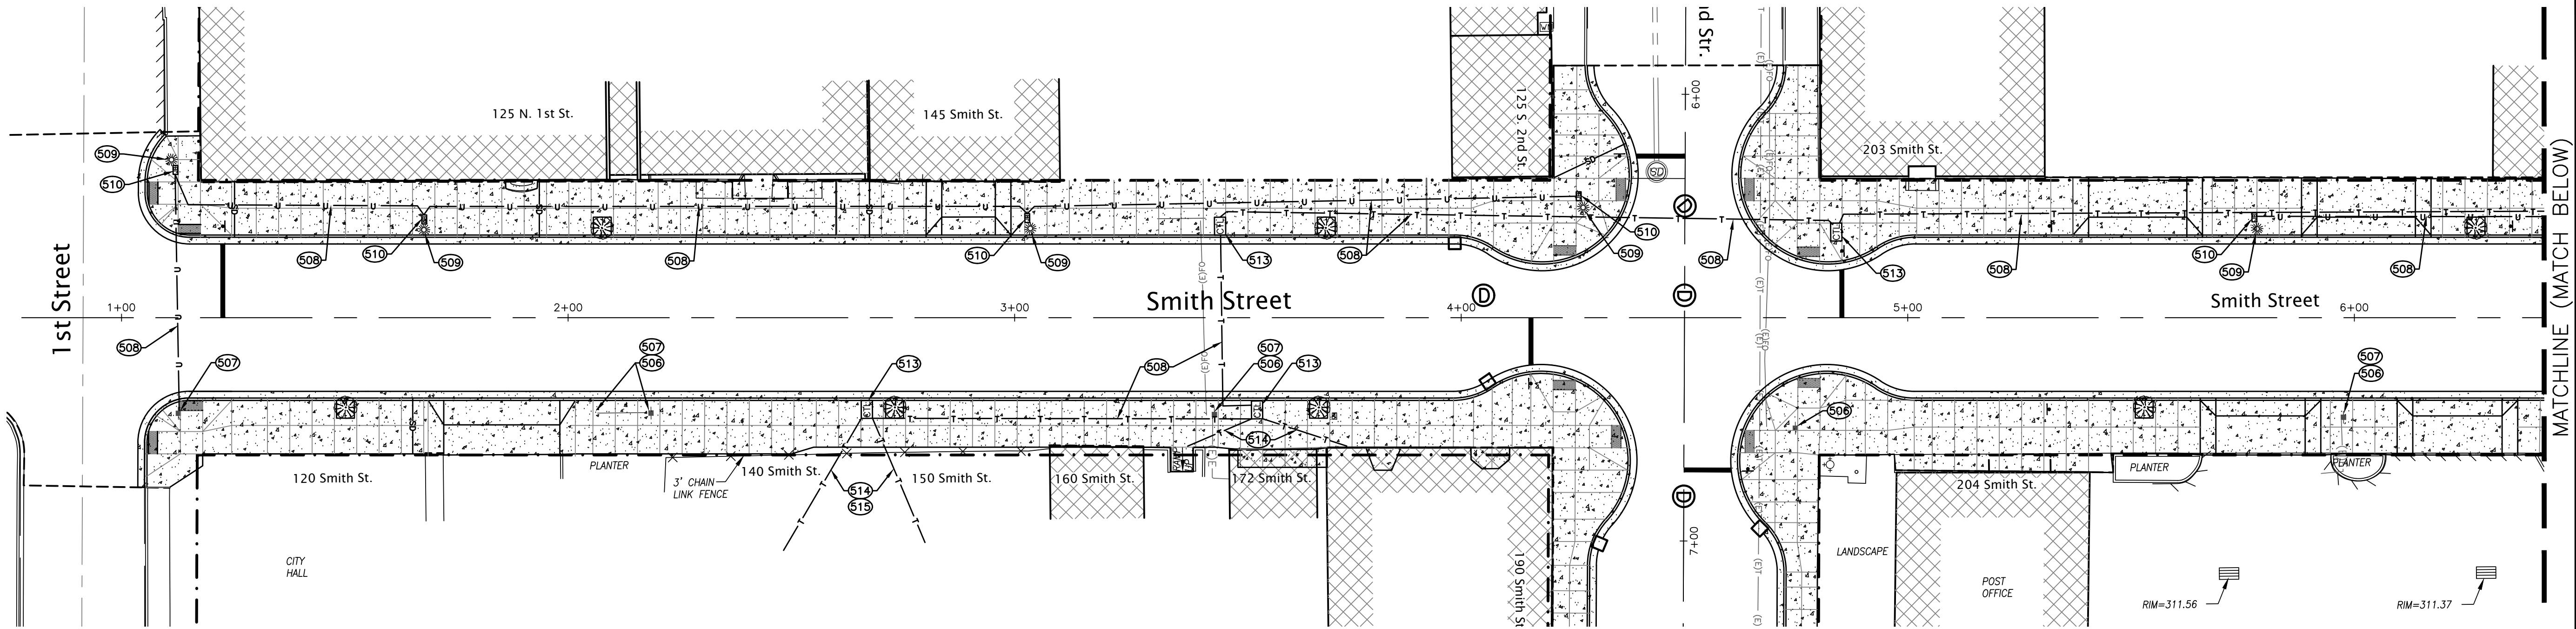

CONSTRUCTION NOTES

- 506—EXISTING POWER POLE (AND ANCHOR) TO REMAIN. CONTRACTOR TO COORDINATE WITH PACIFIC POWER AND LIGHT (CONTACT ELKE VATH 541-967-6160)
- 507—PACIFIC POWER TO REPLACE EXISTING OVERHEAD LIGHT WITH NEW ARLINGTON HEAD. CONTRACTOR TO COORDINATE WITH PACIFIC POWER AND LIGHT (CONTACT ELKE VATH 541-967-6160)
- 508—CONTRACTOR TO INSTALL UTILITY CONDUITS IN JOINT UTILITY TRENCH. UTILITY CONDUIT AND SIZE AS INDICATED ON PACIFIC POWER, COMCAST AND CENTURYLINK PLANS. SEE GENERAL NOTES BELOW.
- 509—CONTRACTOR TO FURNISH AND INSTALL PRECAST FOOTING FOR LIGHT POLE (OLDCASTLE PRECAST 5CL-LB WITH 11" DIAMETER BOLT CIRCLE AND 1" DIA BOLTS, 36" LONG WITH 4" HOOK, GALVANIZED). CONTRACTOR TO PROVIDE 1" PVC SCH40 GRAY CONDUIT FROM LIGHT POLE FOUNDATION TO ADJACENT HANDHOLE. COORDINATE WITH PP&L.
- 510—CONTRACTOR TO INSTALL PP&L PROVIDED JUNCTION BOXES AS REQUIRED. CONTRACTOR TO COORDINATE WITH PACIFIC POWER (CONTACT ELKE VATH 541-967-6160).
- 512—CONTRACTOR TO INSTALL NEW SINGLE PHASE CT METER FOR UNDERGROUND ELECTRICAL SERVICE. CONTRACTOR TO ALSO INSTALL NEW 400 AMP ELECTRICAL PANEL. COORDINATE SERVICE CONNECTION WITH PACIFIC POWER (ELKE VATH 541-967-6160)
- 513—CONTRACTOR TO COORDINATE WITH UTILITY PROVIDER FOR INSTALLATION OF UTILITY PROVIDER'S JUNCTION BOXES, VAULTS AND EQUIPMENT. SEE UTILITY PROVIDERS CONSTRUCTION PLANS. JUNCTION BOXES AND VAULTS TO BE FLUSH AND MATCH SLOPE WITH FINISHED GRADE.
- 514—CONTRACTOR TO PROVIDE CONDUIT TO EXISTING BUILDING.
- 515—CONTRACTOR TO RESTORE TRENCHING IMPACT TO EXISTING SURFACE TO ORIGINAL OR BETTER CONDITION. COORDINATE WITH CITY AND PROPERTY OWNER.
- 516—CONTRACTOR TO BORE TWO CONDUITS (4" PER CENTURY LINK) UNDER EXISTING SIDEWALK. THIS WORK SHALL BE COMPLETED REGARDLESS IF ALTERNATE #1 WORK IS APPROVED
- 517—CONTRACTOR TO POUR NEW CONCRETE SIDEWALK PANELS AFTER INSTALLATION OF UTILITY CONDUITS AND VAULTS. THIS WORK SHALL BE COMPLETED REGARDLESS IF ALTERNATE #1 WORK IS APPROVED.

- GENERAL NOTE:
1. PACIFIC POWER AND LIGHT TO SHARE JOINT UTILITY TRENCH WITH CENTURYLINK, COMCAST AND OTHERS AS REQUIRED. CONTRACTOR TO COORDINATE WITH ALL UTILITIES AND THEIR REQUIREMENTS.
PACIFIC POWER & LIGHT (ELKE VATH 541-967-6160)
CENTURYLINK (LUKE PILON 541-484-8887)
COMCAST (GABE NORBURY 541-731-1498)
 2. COMCAST TO FURNISH ALL COMCAST CONDUIT AND SWEEPS TO CONTRACTOR FOR INSTALLATION AS IDENTIFIED. COORDINATE WITH COMCAST (GABE NORBURY 541-731-1498) FOR CONDUIT AND SWEEPS.
 3. COMCAST TO FURNISH AND INSTALL COMCAST VAULTS. COORDINATE WITH COMCAST (GABE NORBURY 541-731-1498)
 4. COMCAST TO FURNISH AND INSTALL COMCAST JUNCTION BOXES. COORDINATE WITH COMCAST (GABE NORBURY 541-731-1498)
 5. CENTURYLINK TO FURNISH AND INSTALL CONDUIT, JUNCTION BOXES AND VAULTS FOR CENTURYLINK EQUIPMENT. COORDINATE WITH CENTURYLINK (LUKE PILON 541-484-8887)
 6. CONTRACTOR TO SUPPLY PACIFIC POWER CONDUITS AS REQUIRED PER PACIFIC POWER SPECIFICATIONS. CONTACT ELKE VATH 541-967-6160)

GENERAL NOTE

CONTRACTOR TO POTHOLE EXISTING UTILITIES WHERE THERE IS UTILITY CROSSING AND NOTIFY THE ENGINEER IF THERE IS A CONFLICT.

ALTERNATE #1

project title:

CITY OF HARRISBURG Smith, Macy, & 2nd Street Rehabilitation

Smith - 1st To 3rd, Macy - 2nd To 3rd, 2nd - Smith To Macy
HARRISBURG, OREGON

revisions:

date: JANUARY 28, 2020
drawn by: GAM
designer: GAM
project no: 17-009F

Electrical &
Communications
Plan

sheet:


C22

CONSTRUCTION NOTES

- 508—CONTRACTOR TO INSTALL UTILITY CONDUITS IN JOINT UTILITY TRENCH. UTILITY CONDUIT AND SIZE AS INDICATED ON PACIFIC POWER, COMCAST AND CENTURYLINK PLANS. SEE GENERAL NOTES BELOW.
- 509—CONTRACTOR TO FURNISH AND INSTALL PRECAST FOOTING FOR LIGHT POLE (OLDCASTLE PRECAST 5CL-LB WITH 11" DIAMETER BOLT CIRCLE AND 1" DIA BOLTS, 36" LONG WITH 4" HOOK, GALVANIZED). CONTRACTOR TO PROVIDE 1" PVC SCH40 GRAY CONDUIT FROM LIGHT POLE FOUNDATION TO ADJACENT HANDHOLE. COORDINATE WITH PP&L.
- 510—CONTRACTOR TO INSTALL PP&L PROVIDED JUNCTION BOXES AS REQUIRED. CONTRACTOR TO COORDINATE WITH PACIFIC POWER AND LIGHT (CONTACT ELKE VATH 541-967-6160).
- 512—CONTRACTOR TO INSTALL NEW SINGLE PHASE CT METER FOR UNDERGROUND ELECTRICAL SERVICE AT ADDRESS INDICATED. CONTRACTOR TO ALSO INSTALL NEW XXX AMP ELECTRICAL PANEL (AMPERAGE SHOWN ON PLANS). COORDINATE SERVICE CONNECTION WITH PACIFIC POWER (ELKE VATH 541-967-6160).
- 513—CONTRACTOR TO COORDINATE WITH UTILITY PROVIDER FOR INSTALLATION OF UTILITY PROVIDER'S JUNCTION BOXES, VAULTS AND EQUIPMENT. SEE UTILITY PROVIDERS CONSTRUCTION PLANS. JUNCTION BOXES AND VAULTS TO BE FLUSH AND MATCH SLOPE WITH FINISHED GRADE.
- 514—CONTRACTOR TO PROVIDE CONDUIT TO EXISTING BUILDING.


GENERAL NOTE:

- PACIFIC POWER AND LIGHT TO SHARE JOINT UTILITY TRENCH WITH CENTURYLINK, COMCAST AND OTHERS AS REQUIRED. CONTRACTOR TO COORDINATE WITH ALL UTILITIES AND THEIR REQUIREMENTS.
PACIFIC POWER & LIGHT (ELKE VATH 541-967-6160)
CENTURYLINK (LUKE PILON 541-484-8887)
COMCAST (GABE NORBURY 541-731-1498).
- COMCAST TO FURNISH ALL COMCAST CONDUIT AND SWEEPS TO CONTRACTOR FOR INSTALLATION AS IDENTIFIED. COORDINATE WITH COMCAST (GABE NORBURY 541-731-1498) FOR CONDUIT AND SWEEPS.
- COMCAST TO FURNISH AND INSTALL COMCAST VAULTS. COORDINATE WITH COMCAST (GABE NORBURY 541-731-1498).
- COMCAST TO FURNISH AND INSTALL COMCAST JUNCTION BOXES. COORDINATE WITH COMCAST (GABE NORBURY 541-731-1498).
- CENTURYLINK TO FURNISH AND INSTALL CONDUIT, JUNCTION BOXES AND VAULTS FOR CENTURYLINK EQUIPMENT. COORDINATE WITH CENTURYLINK (LUKE PILON 541-484-8887).
- CONTRACTOR TO SUPPLY PACIFIC POWER CONDUITS AS REQUIRED PER PACIFIC POWER SPECIFICATIONS. CONTACT ELKE VATH 541-967-6160).

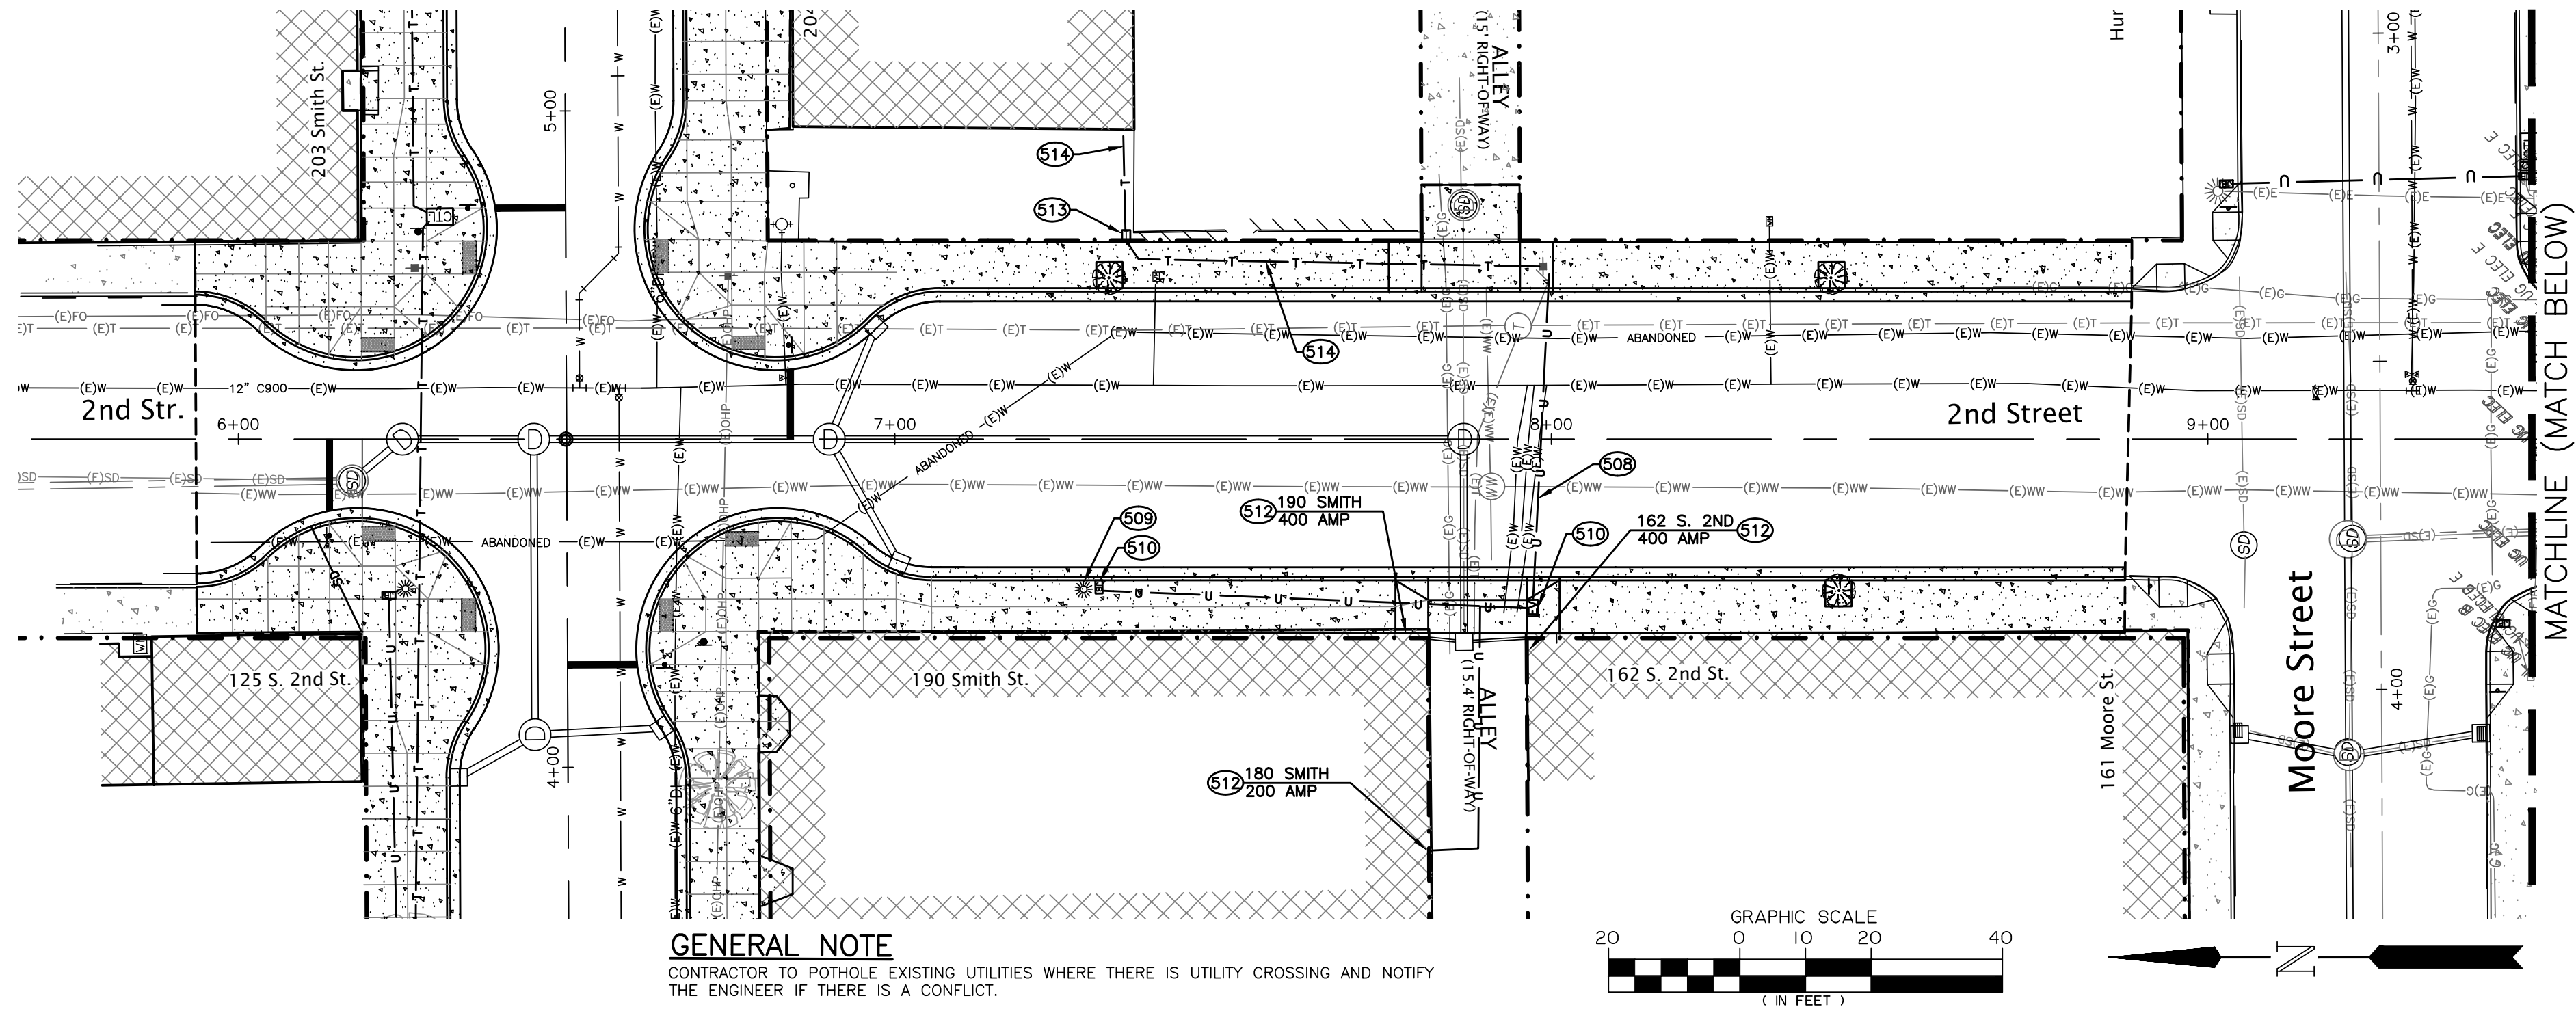

GENERAL NOTE

CONTRACTOR TO POTHOLE EXISTING UTILITIES WHERE THERE IS UTILITY CROSSING AND NOTIFY THE ENGINEER IF THERE IS A CONFLICT.

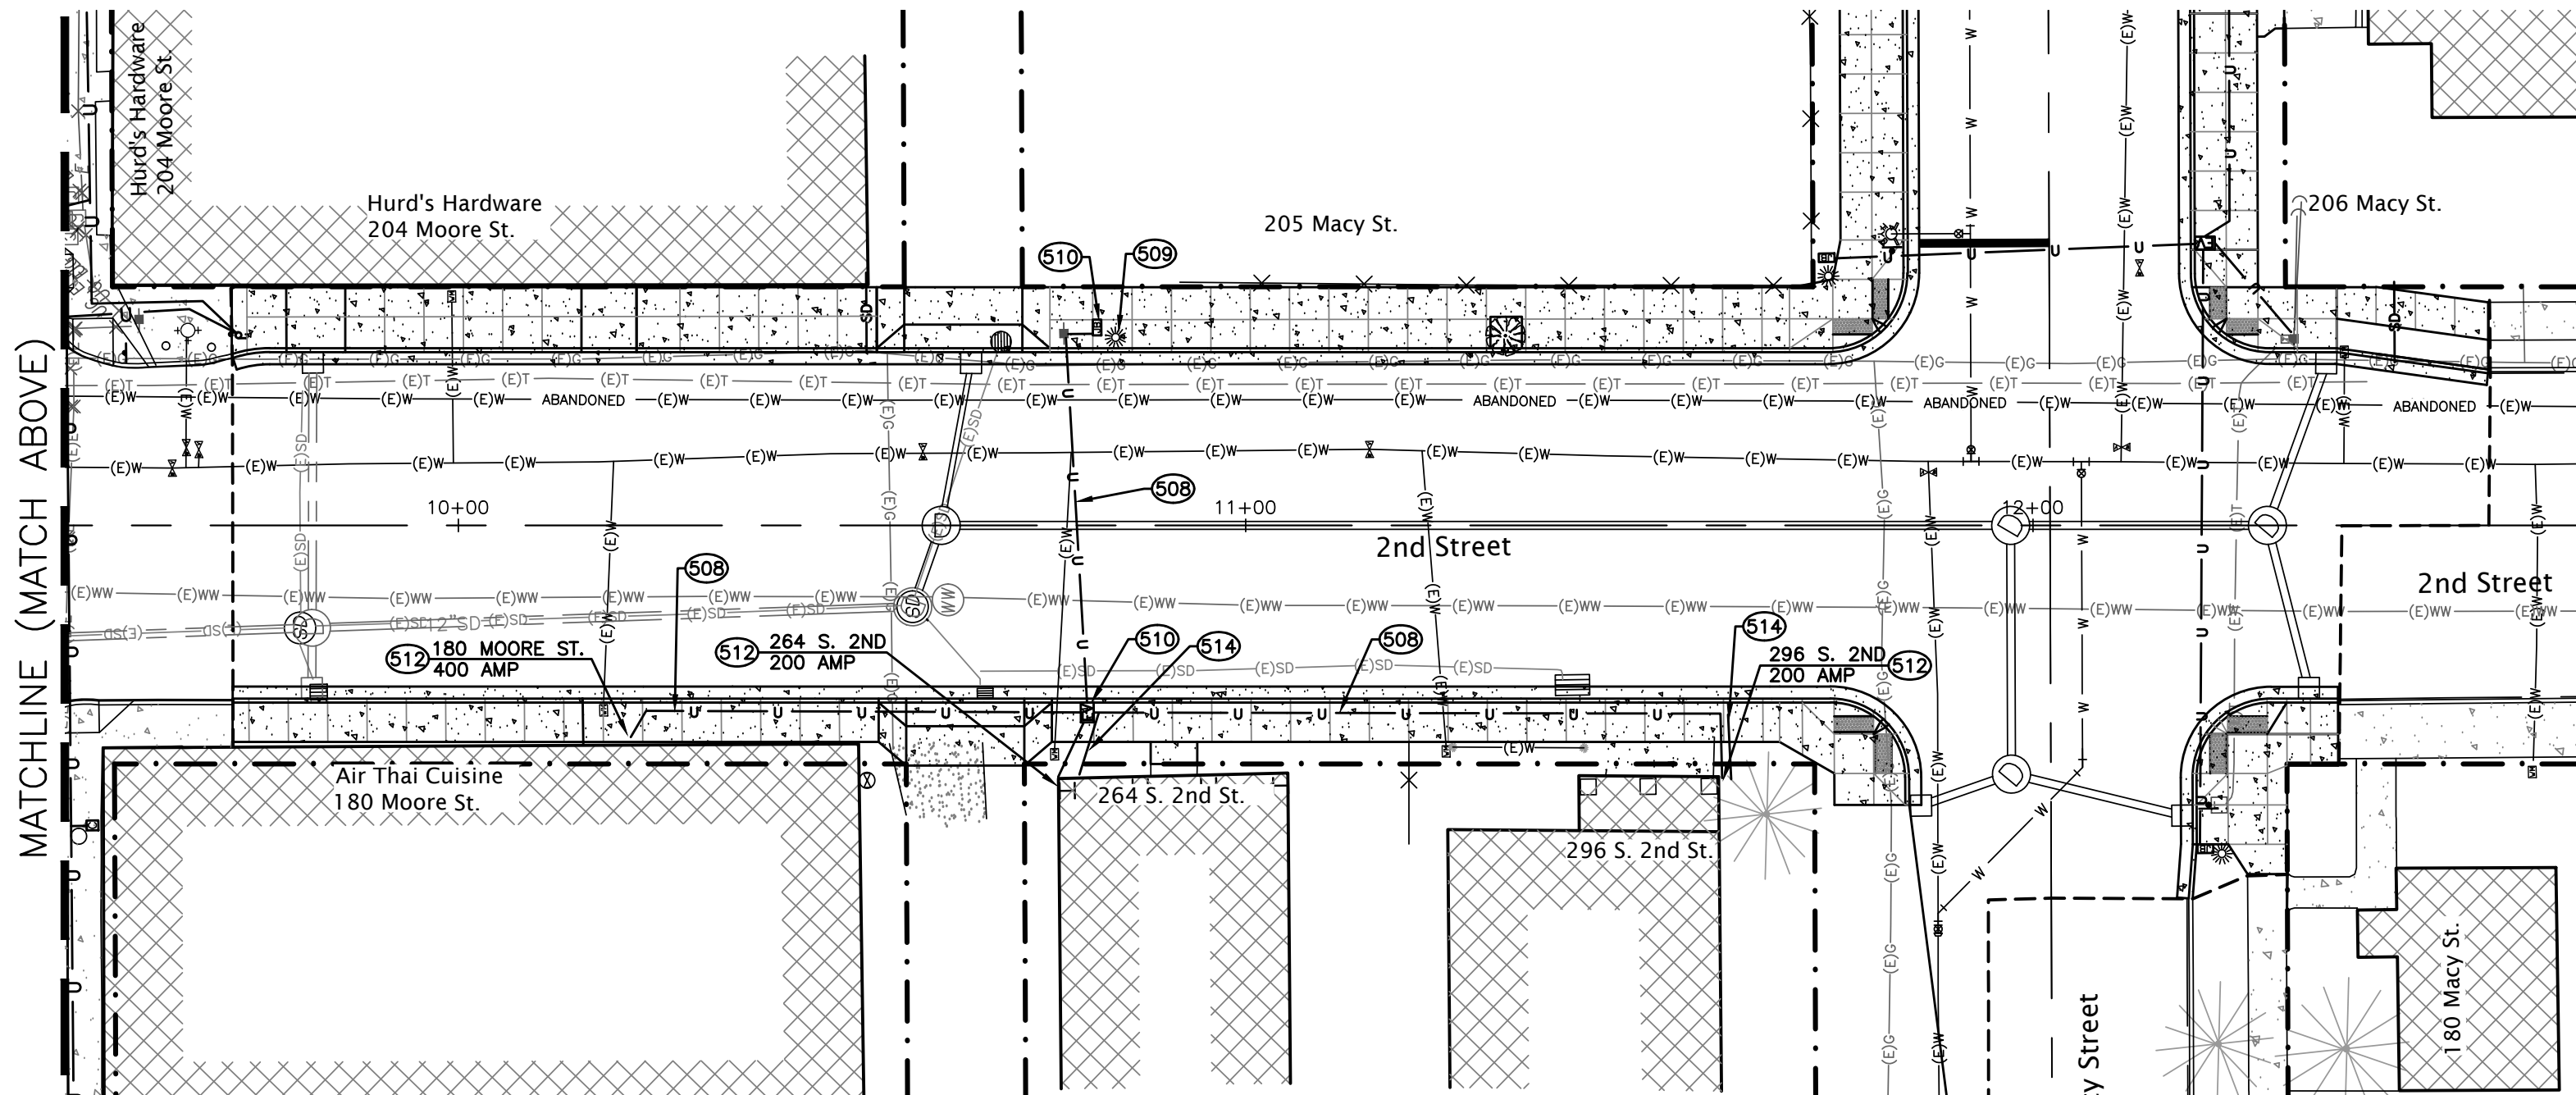

project title:

CITY OF HARRISBURG Smith, Macy, & 2nd Street Rehabilitation

Smith - 1st To 3rd, Macy - 2nd To 3rd, 2nd - Smith To Macy
HARRISBURG, OREGON

revisions:

date: JANUARY 28, 2020
drawn by: GAM
designer: GAM
project no: 17-009F


Electrical &
Communications
Plan

sheet:

C23

Z:\2017\17-009F Harrisburg Smith Street\Drawing\17-009F Street Improvements.dwg / 2/5/2020 2:01 PM JLL/E

copyright © 2016 Branch Engineering, Inc.

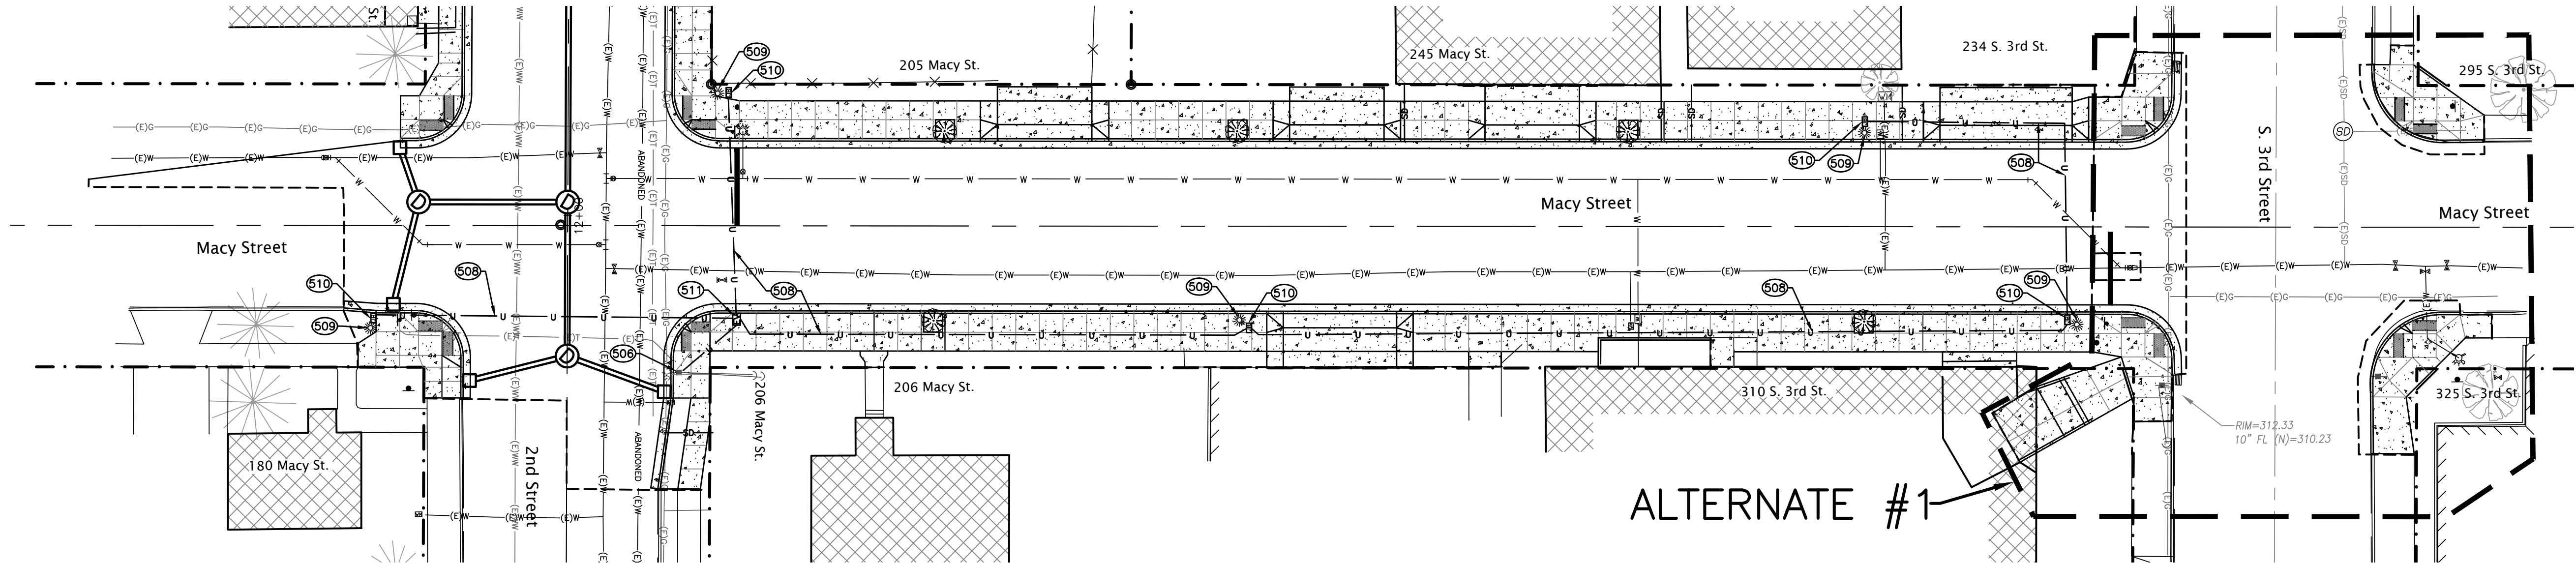

GENERAL NOTE


CONTRACTOR TO POTHOLE EXISTING UTILITIES WHERE THERE IS UTILITY CROSSING AND NOTIFY THE ENGINEER IF THERE IS A CONFLICT.

CONSTRUCTION NOTES

- 508—EXISTING POWER POLE (AND ANCHOR) TO REMAIN. CONTRACTOR TO COORDINATE WITH PACIFIC POWER AND LIGHT (CONTACT ELKE VATH 541-967-6160)
- 508—CONTRACTOR TO INSTALL UTILITY CONDUITS IN JOINT UTILITY TRENCH. UTILITY CONDUIT AND SIZE AS INDICATED ON PACIFIC POWER, COMCAST AND CENTURYLINK PLANS. SEE GENERAL NOTES BELOW.
- 509—CONTRACTOR TO FURNISH AND INSTALL PRECAST FOOTING FOR LIGHT POLE (OLDCASTLE PRECAST 5CL-LB WITH 11" DIAMETER BOLT CIRCLE AND 1" DIA BOLTS, 36" LONG WITH 4" HOOK, GALVANIZED). CONTRACTOR TO PROVIDE 1" PVC SCH40 GRAY CONDUIT FROM LIGHT POLE FOUNDATION TO ADJACENT HANDHOLE. COORDINATE WITH PP&L.
- 510—CONTRACTOR TO INSTALL PP&L PROVIDED JUNCTION BOXES AS REQUIRED. CONTRACTOR TO COORDINATE WITH PACIFIC POWER AND LIGHT (CONTACT ELKE VATH 541-967-6160).
- 511—CONTRACTOR TO INSTALL PP&L PROVIDED ABOVE GROUND SECONDARY PEDESTAL BOX. CONTRACTOR TO COORDINATE WITH PACIFIC POWER AND LIGHT (CONTACT ELKE VATH 541-967-6160).

GENERAL NOTE:

- PACIFIC POWER AND LIGHT TO SHARE JOINT UTILITY TRENCH WITH CENTURYLINK, COMCAST AND OTHERS AS REQUIRED. CONTRACTOR TO COORDINATE WITH ALL UTILITIES AND THEIR REQUIREMENTS.
PACIFIC POWER & LIGHT (ELKE VATH 541-967-6160)
CENTURYLINK (LUKE PILON 541-484-8887)
COMCAST (GABE NORBURY 541-731-1498).
- COMCAST TO FURNISH ALL COMCAST CONDUIT AND SWEEPS TO CONTRACTOR FOR INSTALLATION AS IDENTIFIED. COORDINATE WITH COMCAST (GABE NORBURY 541-731-1498) FOR CONDUIT AND SWEEPS.
- COMCAST TO FURNISH AND INSTALL COMCAST VAULTS. COORDINATE WITH COMCAST (GABE NORBURY 541-731-1498)
- COMCAST TO FURNISH AND INSTALL COMCAST JUNCTION BOXES. COORDINATE WITH COMCAST (GABE NORBURY 541-731-1498)
- CENTURYLINK TO FURNISH AND INSTALL CONDUIT, JUNCTION BOXES AND VAULTS FOR CENTURYLINK EQUIPMENT. COORDINATE WITH CENTURYLINK (LUKE PILON 541-484-8887)
- CONTRACTOR TO SUPPLY PACIFIC POWER CONDUITS AS REQUIRED PER PACIFIC POWER SPECIFICATIONS. CONTACT ELKE VATH 541-967-6160)

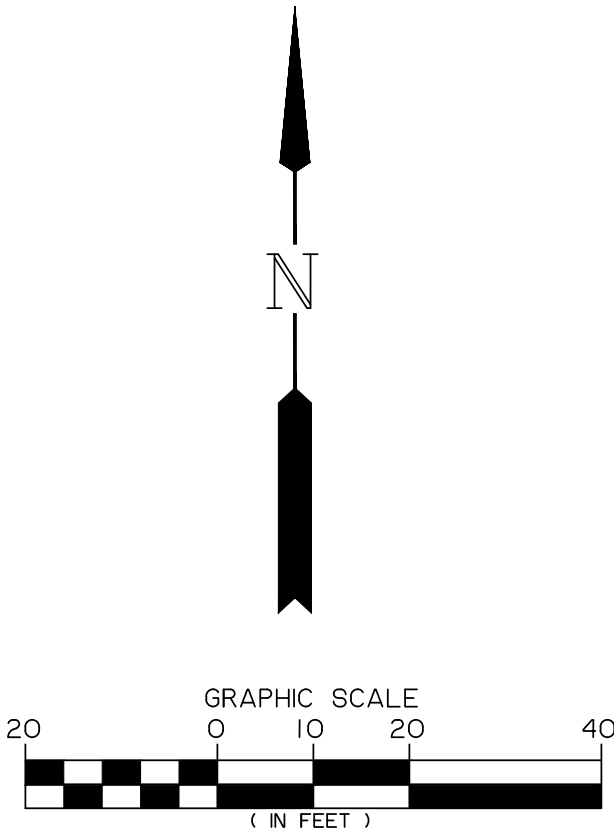

project title:

CITY OF HARRISBURG Smith, Macy, & 2nd Street Rehabilitation

Smith - 1st To 3rd, Macy - 2nd To 3rd, 2nd - Smith To Macy
HARRISBURG, OREGON

 
revisions:

date: JANUARY 28, 2020
drawn by: GAM
designer: GAM
project no: 17-009F

Electrical &
Communications
Plan

sheet:

C24



GRAPHIC SCALE

(IN FEET)



EX	
	T

R_X


(CW-SC)

S


FXM


$$N$$

W3-3

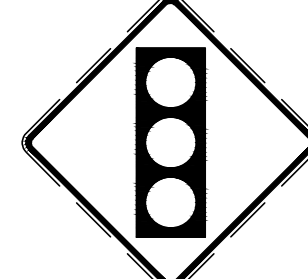

SIGN
NO. 1

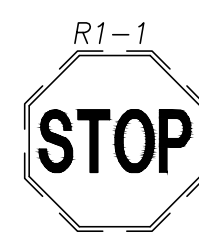


SIGN
NO. 2




SCHOOL
CROSSING



SIGN
NO. 4

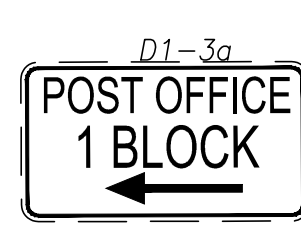

SIGN
NO. 5

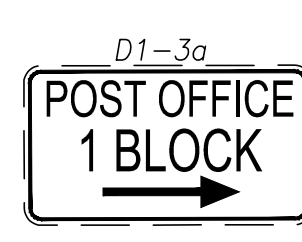

SIGN NO.



SIGN NO. 7




SIGN
NO. 8




NO. 9



NO. 10

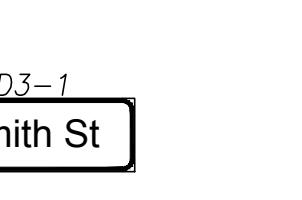


2-SIDED

 

SIGN
NO. 12
2-SIDED

C25

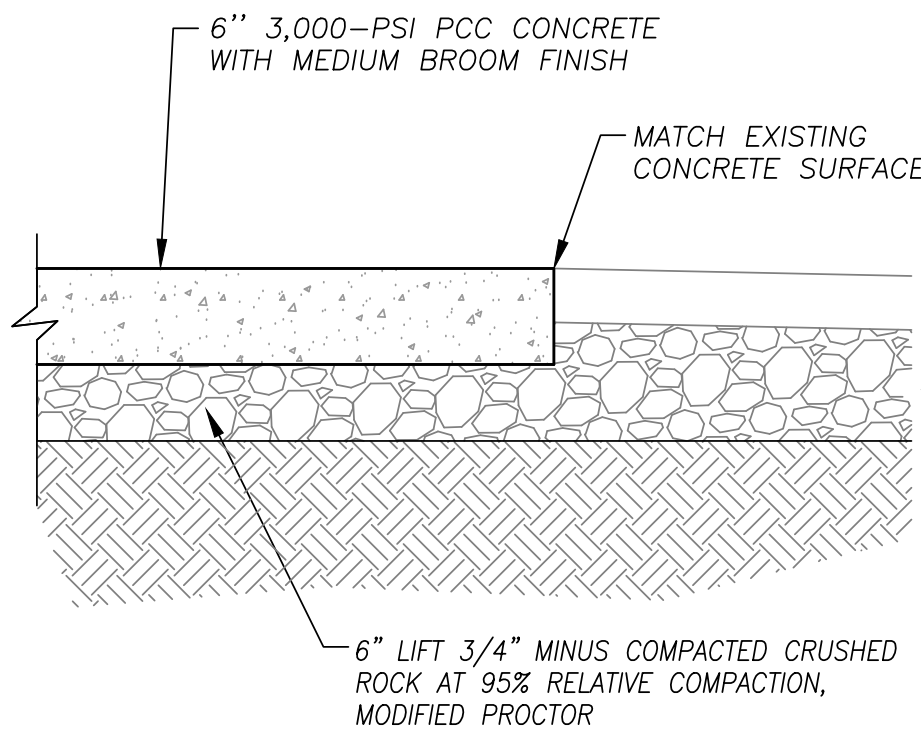

CONCRETE SLAB
SCALE: NONE

